


UTAH MUSEUM OF NATURAL HISTORY

UNIVERSITY OF UTAH, SALT LAKE CITY, UTAH

Exhibit Construction

Owner UMNH 1390 East President's Circle Salt Lake City, Utah 84112 801.581.6927 tel.	Design Architect Polishek Partnership Architects LLP 320 West 13th Street New York, New York 212.807.7171 tel.	Architect of Record Gilles Stransky Brems Smith 375 West 200 South Salt Lake City, Utah 801.521.8600 tel.	Structural Engineer Leslie E. Robertson Associates 30 Broad Street New York, New York 10004 212.750.9000 tel.	Mechanical/Plumbing/FP Engineer Colvin Engineering Associates, Inc. 244 West 300 North Salt Lake City, Utah 84103 801.322.2400 tel.	Electrical/AV Engineer Spectrum Engineers 175 South Main Street Salt Lake City, Utah 84111 800.678.7077 tel.	Landscape Architect Design Workshop, Inc. 1796 Prospector Avenue Park City, Utah 84060 435.655.0915 tel.	Lighting Branston Partnership 122 West 26th Street New York, NY 10001 212.924.4050 tel.	Audio Visual BBI Engineering, Inc. 241 Quint Street San Francisco, CA 94124 415.685.9555 tel.	Exhibition Planner and Designer Ralph Appelbaum Associates 88 Pine Street New York, New York 10005 212.334.8200 tel.
---	---	--	--	--	---	---	--	--	---

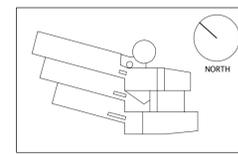


Key Plan

FD WS2rev	Sept.22, 2008
FD WS2	Sept.9, 2008
100% DD	June 2, 2008
XG 60% CD	May 5, 2008
WS9	March, 26, 2008
WS8	Feb. 20, 2008
WS7	Dec. 18, 2007
50% DD	Sept. 18, 2007
WS6	July 11, 2007
WS5	May 23, 2007
WS4	April 12, 2007
No. / Issue Name / Date	

Sheet Title	Level 5 AV Plan
Date	Dec. 19, 2008
Scale*	1/16"=1'-0"
No. / Issue Name / Date	

Project No.	0275
Sheet No.	AV-L5

*Note: Scale Given for Full Size Drawing Sheet (22" x 34")

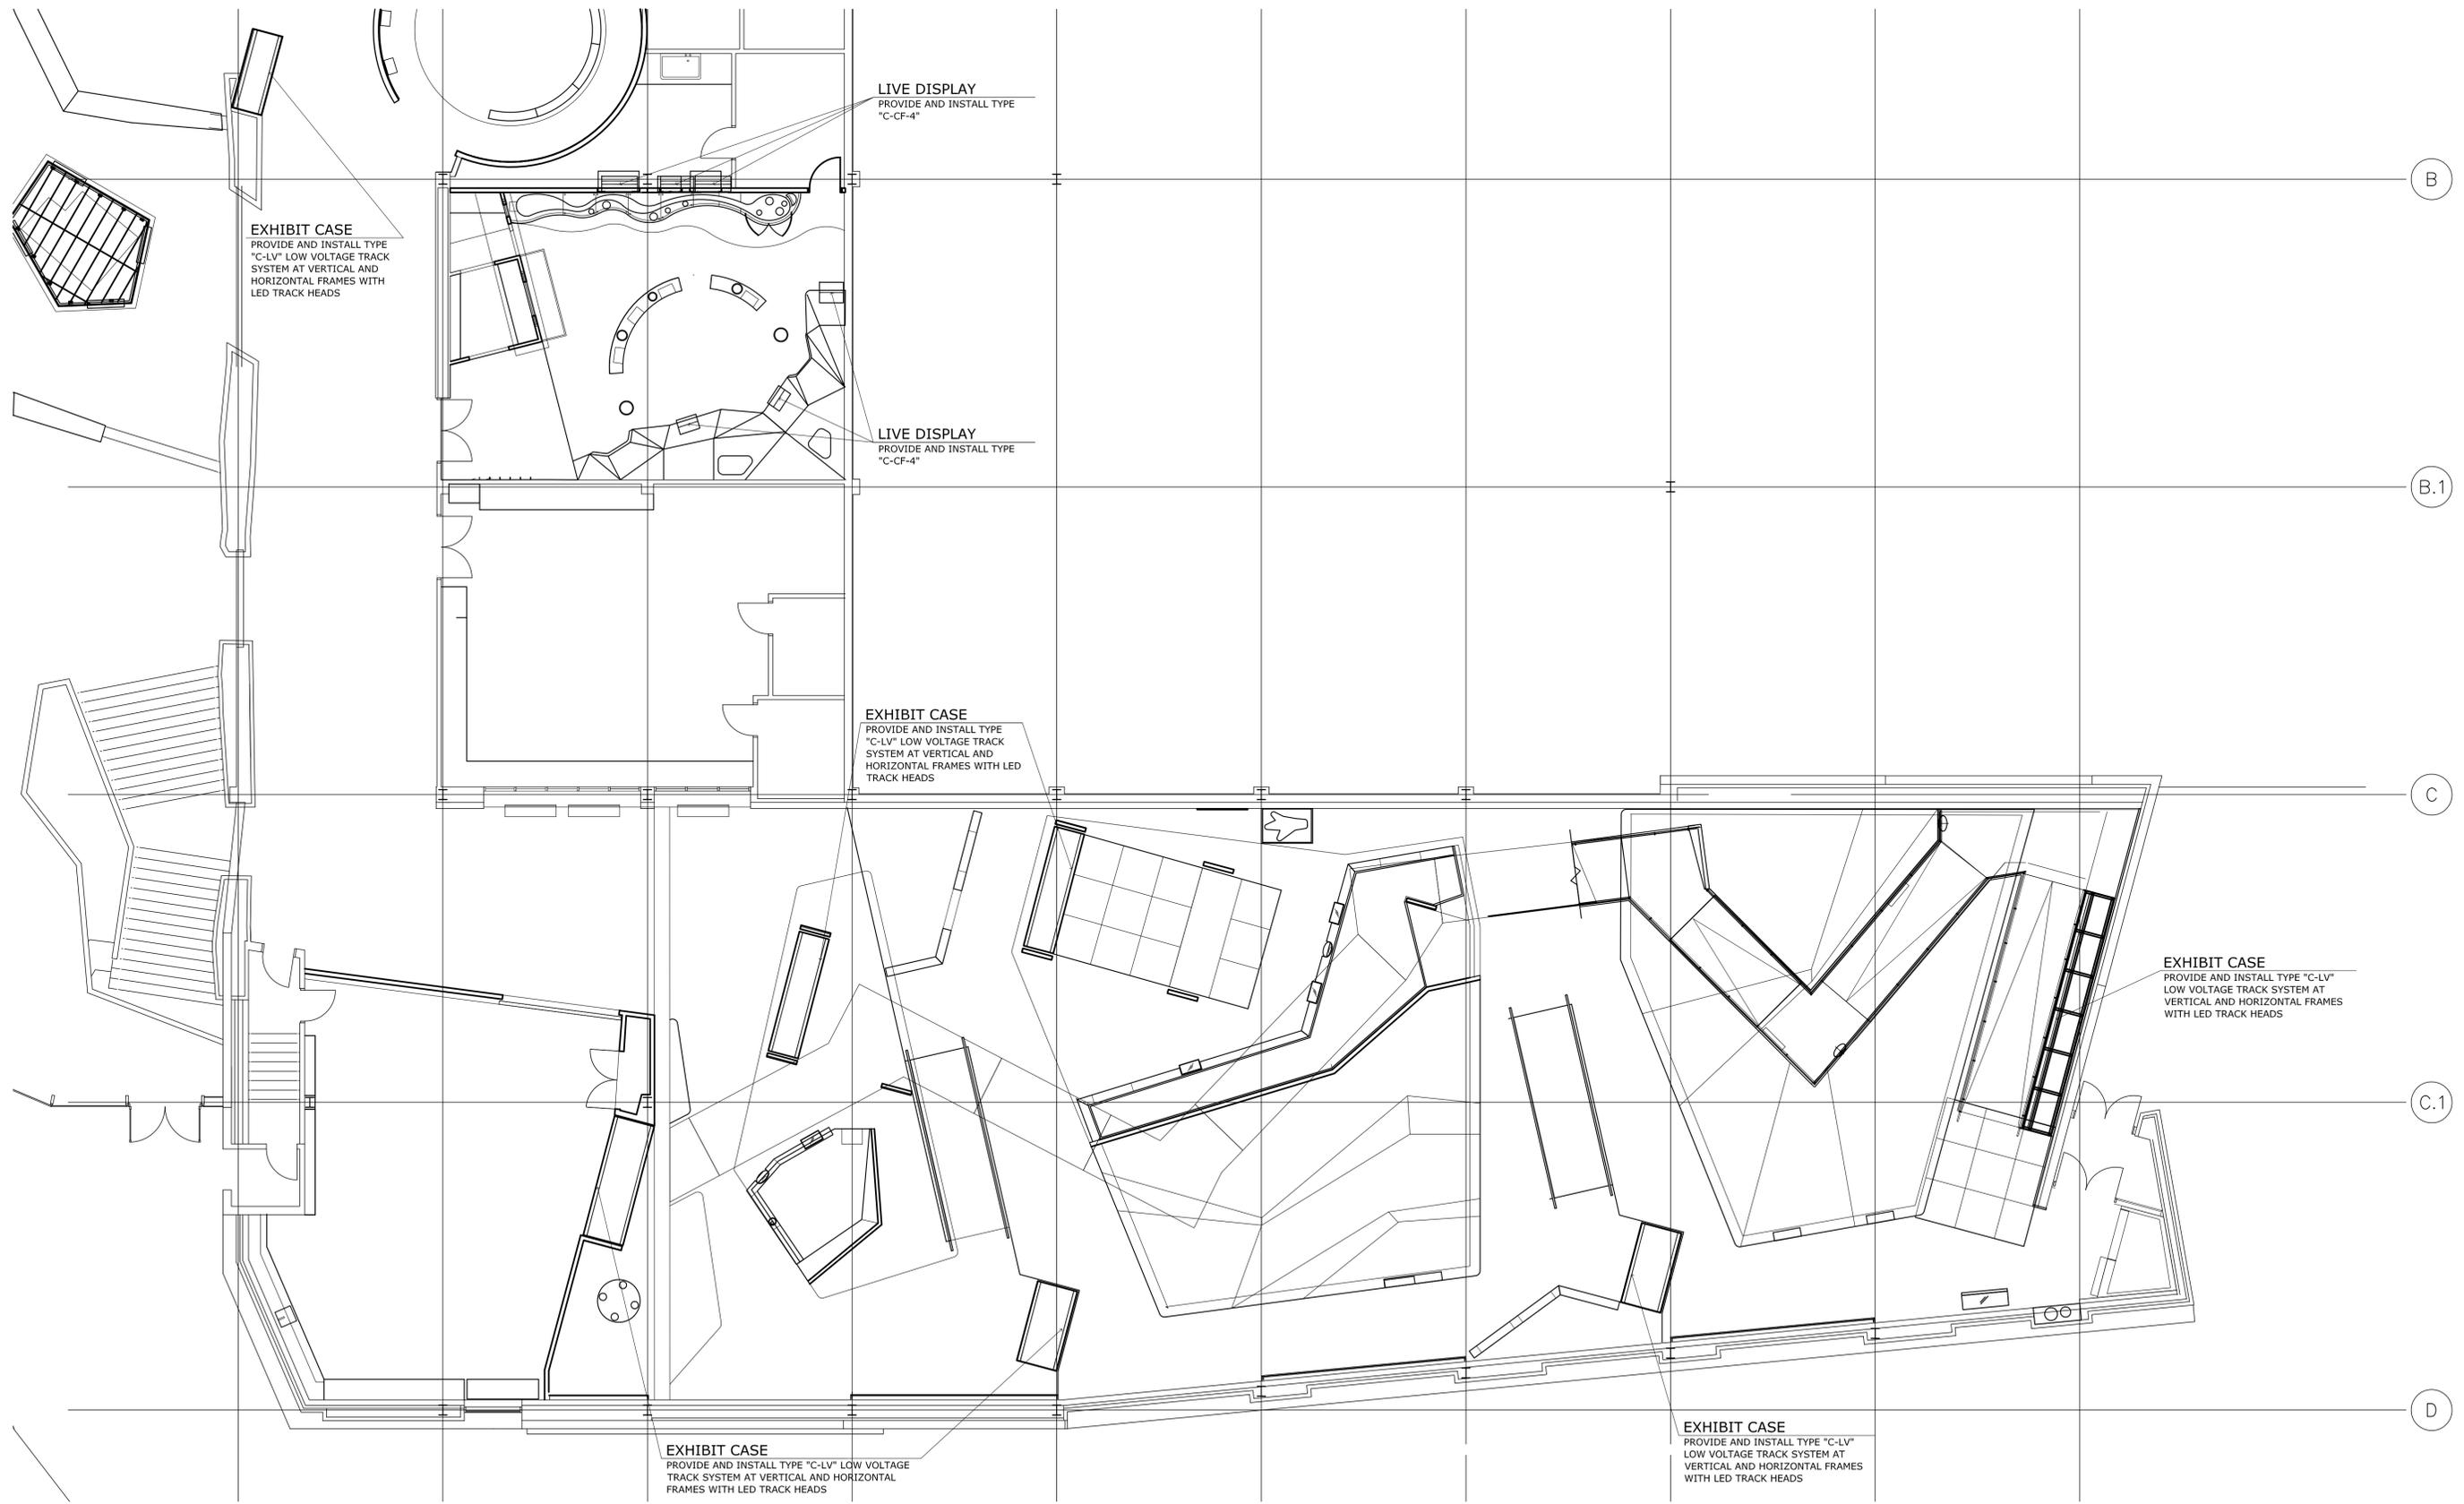


UTAH MUSEUM OF NATURAL HISTORY

UNIVERSITY OF UTAH, SALT LAKE CITY, UTAH

Exhibit Construction

Owner UMNH 1390 East President's Circle Salt Lake City, Utah 84112 801.581.6927 tel.	Design Architect Polshak Partnership Architects LLP 320 West 13th Street New York, New York 212.807.7171 tel.	Architect of Record Giles Stransky Brems Smith 375 West 200 South Salt Lake City, Utah 801.521.8600 tel.	Structural Engineer Leslie E. Robertson Associates 30 Broad Street New York, New York 10004 212.750.9000 tel.	Mechanical/Plumbing/Fire Protection Celanese Engineering Associates, Inc. 244 West 300 North Salt Lake City, Utah 84103 801.322.2400 tel.	Electrical/AV Engineer Spectrum Engineers 175 South Main Street Salt Lake City, Utah 84111 800.678.7077 tel.	Landscape Architect Design Workshop, Inc. 1796 Prospector Avenue Park City, Utah 84060 435.655.0915 tel.	Exhibition Planner and Ralph Appelbaum Associates 88 Pine Street New York, New York 10005 212.334.8200 tel.	Lighting Designer Brandston Partnership Inc 122 West 26th Street New York, New York 10001 212.924.4050 tel.
---	--	---	--	--	---	---	--	--

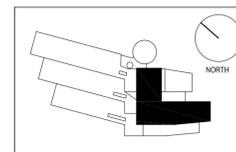

Key Plan

80% FD	Dec. 19, 2008
100% DD	June 2, 2008
XG 60% CD	May 5, 2008
WS9	March 26, 2008
WS8	Feb. 20, 2008
WS7	Dec. 18, 2007
50% DD	Sept. 18, 2007
WS6	July 11, 2007
WS5	May 23, 2007
WS4	April 12, 2007

No. / Issue Name / Date

No. / Issue Name / Date

Sheet Title
Level 2 Lighting Plan


Date
Dec. 19, 2008

Project No.
0275


Scale*
1/8"=1'-0"

Sheet No.
LX-L2-1.00

*Note: Scale Given for Full Size Drawing Sheet (22" x 34")

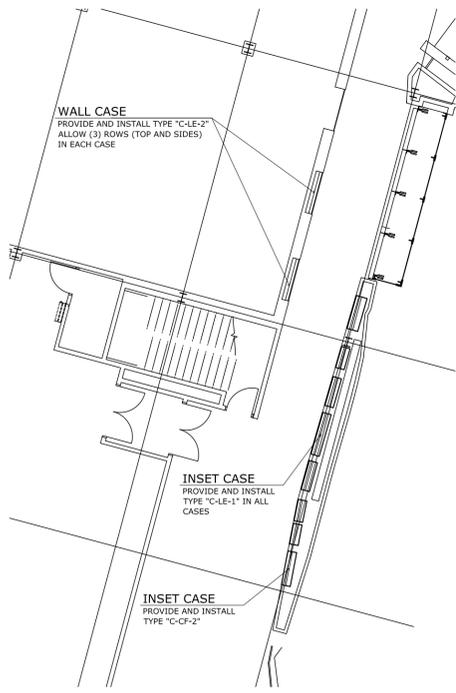

MINERAL HALL

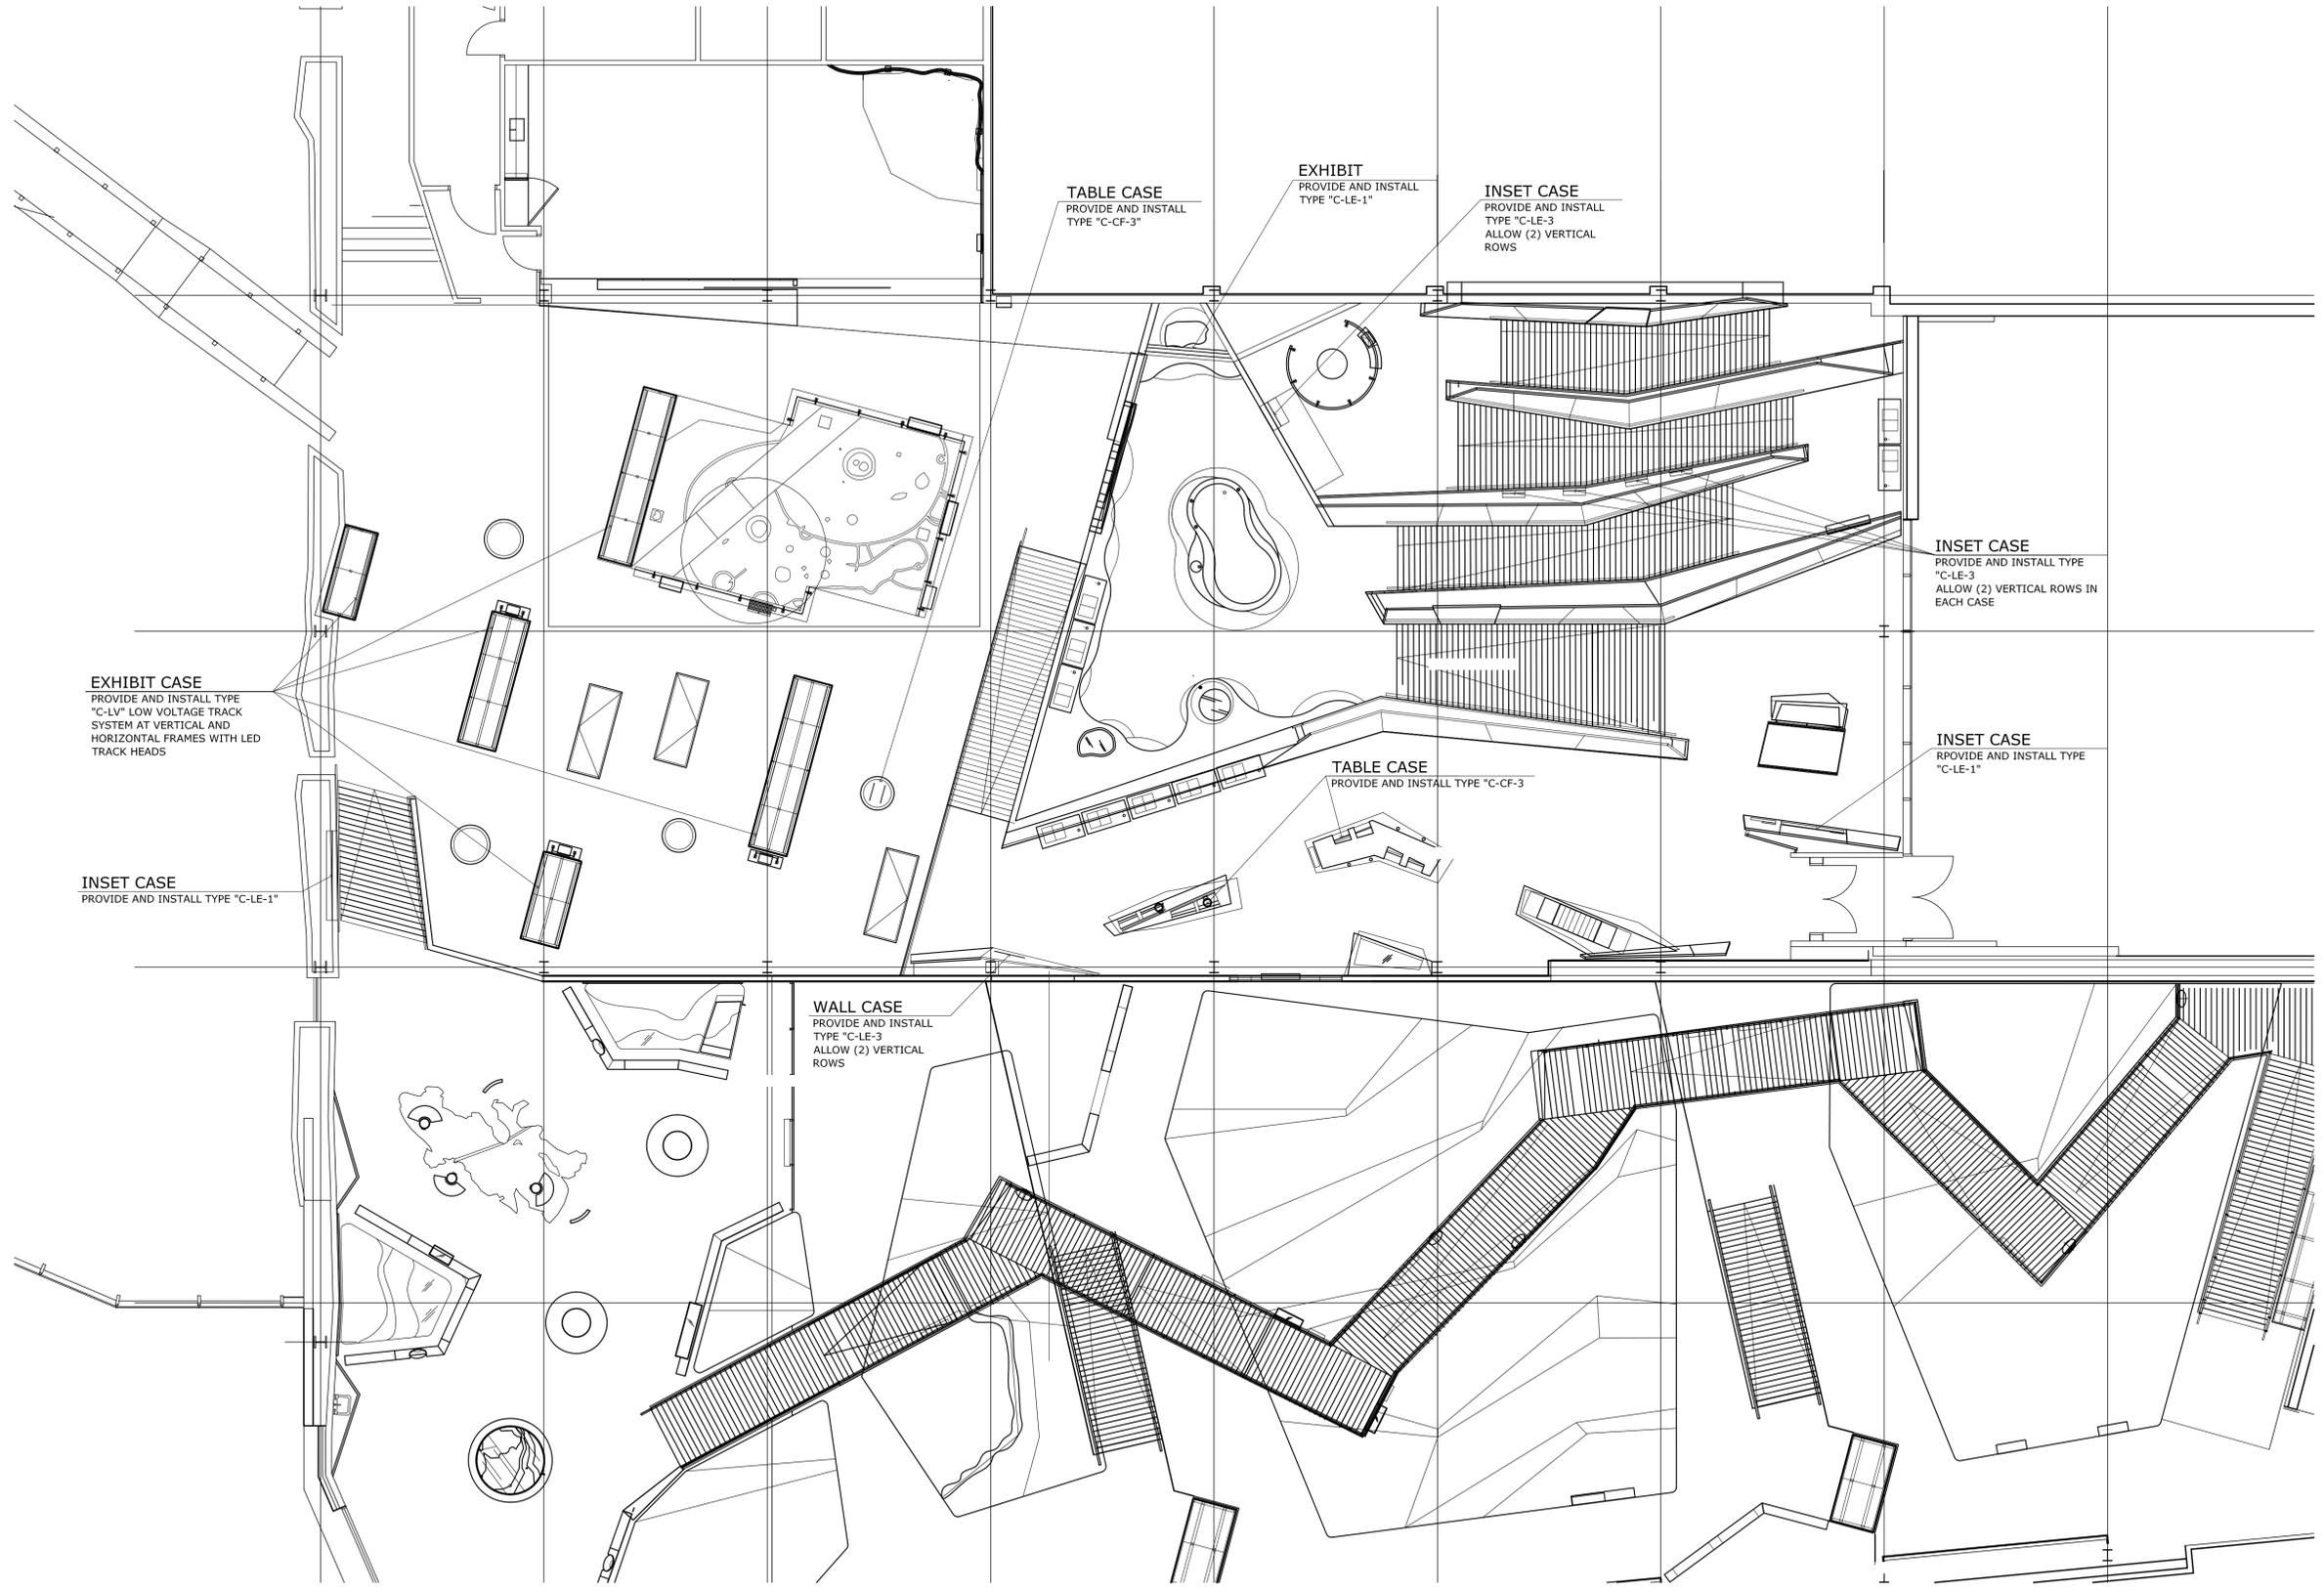


UTAH MUSEUM OF NATURAL HISTORY

UNIVERSITY OF UTAH, SALT LAKE CITY, UTAH

Owner UMNH 1300 East President's Circle Salt Lake City, Utah 84112 801.581.6927 tel.	Design Architect Polshak Partnership Architects LLP 320 West 10th Street New York, New York 212.807.7171 tel.	Architect of Record Coffey Stansbury Evans Smith 375 West 200 South Salt Lake City, Utah 801.521.8600 tel.	Structural Engineer Leslie E. Robertson Associates 30 Broad Street New York, New York 10004 212.750.9000 tel.	Mechanical/Plumbing/Fire Protection Covari Engineering Associates, Inc. 244 West 300 North Salt Lake City, Utah 84103 801.322.2400 tel.	Electrical/AV Engineer Spectrum Engineers 175 South Main Street Salt Lake City, Utah 84111 800.678.7077 tel.	Landscape Architect Design Workshop, Inc. 1796 Prospector Avenue Park City, Utah 84060 435.655.0915 tel.	Exhibition Planner and Retail Merchandising Ralph Appelbaum Associates 88 Pine Street New York, New York 10005 212.334.8200 tel.	Lighting Designer Brandston Partnership Inc 122 West 26th Street New York, New York 10001 212.924.4050 tel.
---	--	---	--	--	---	---	---	--

Exhibit Construction

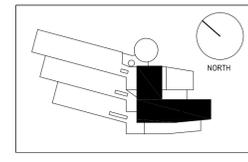

80% FD	Dec. 19, 2008
100% DD	June 2, 2008
XG 60% CD	May 5, 2008
WS9	March 26, 2008
WS8	Feb. 20, 2008
WS7	Dec. 18, 2007
50% DD	Sept. 18, 2007
WS6	July 11, 2007
WS5	May 23, 2007
WS4	April 12, 2007

No. / Issue Name / Date


No. / Issue Name / Date

Sheet Title
Level 3 Lighting Plan

Date Dec. 19, 2008	Project No. 0275
Scale* 1/8"=1'-0"	Sheet No. LX-L3-1.00

*Note: Scale Given for Full Size Drawing Sheet (22" x 34")

NOTE: All fixtures in RCP are in GC scope and are shown for reference only

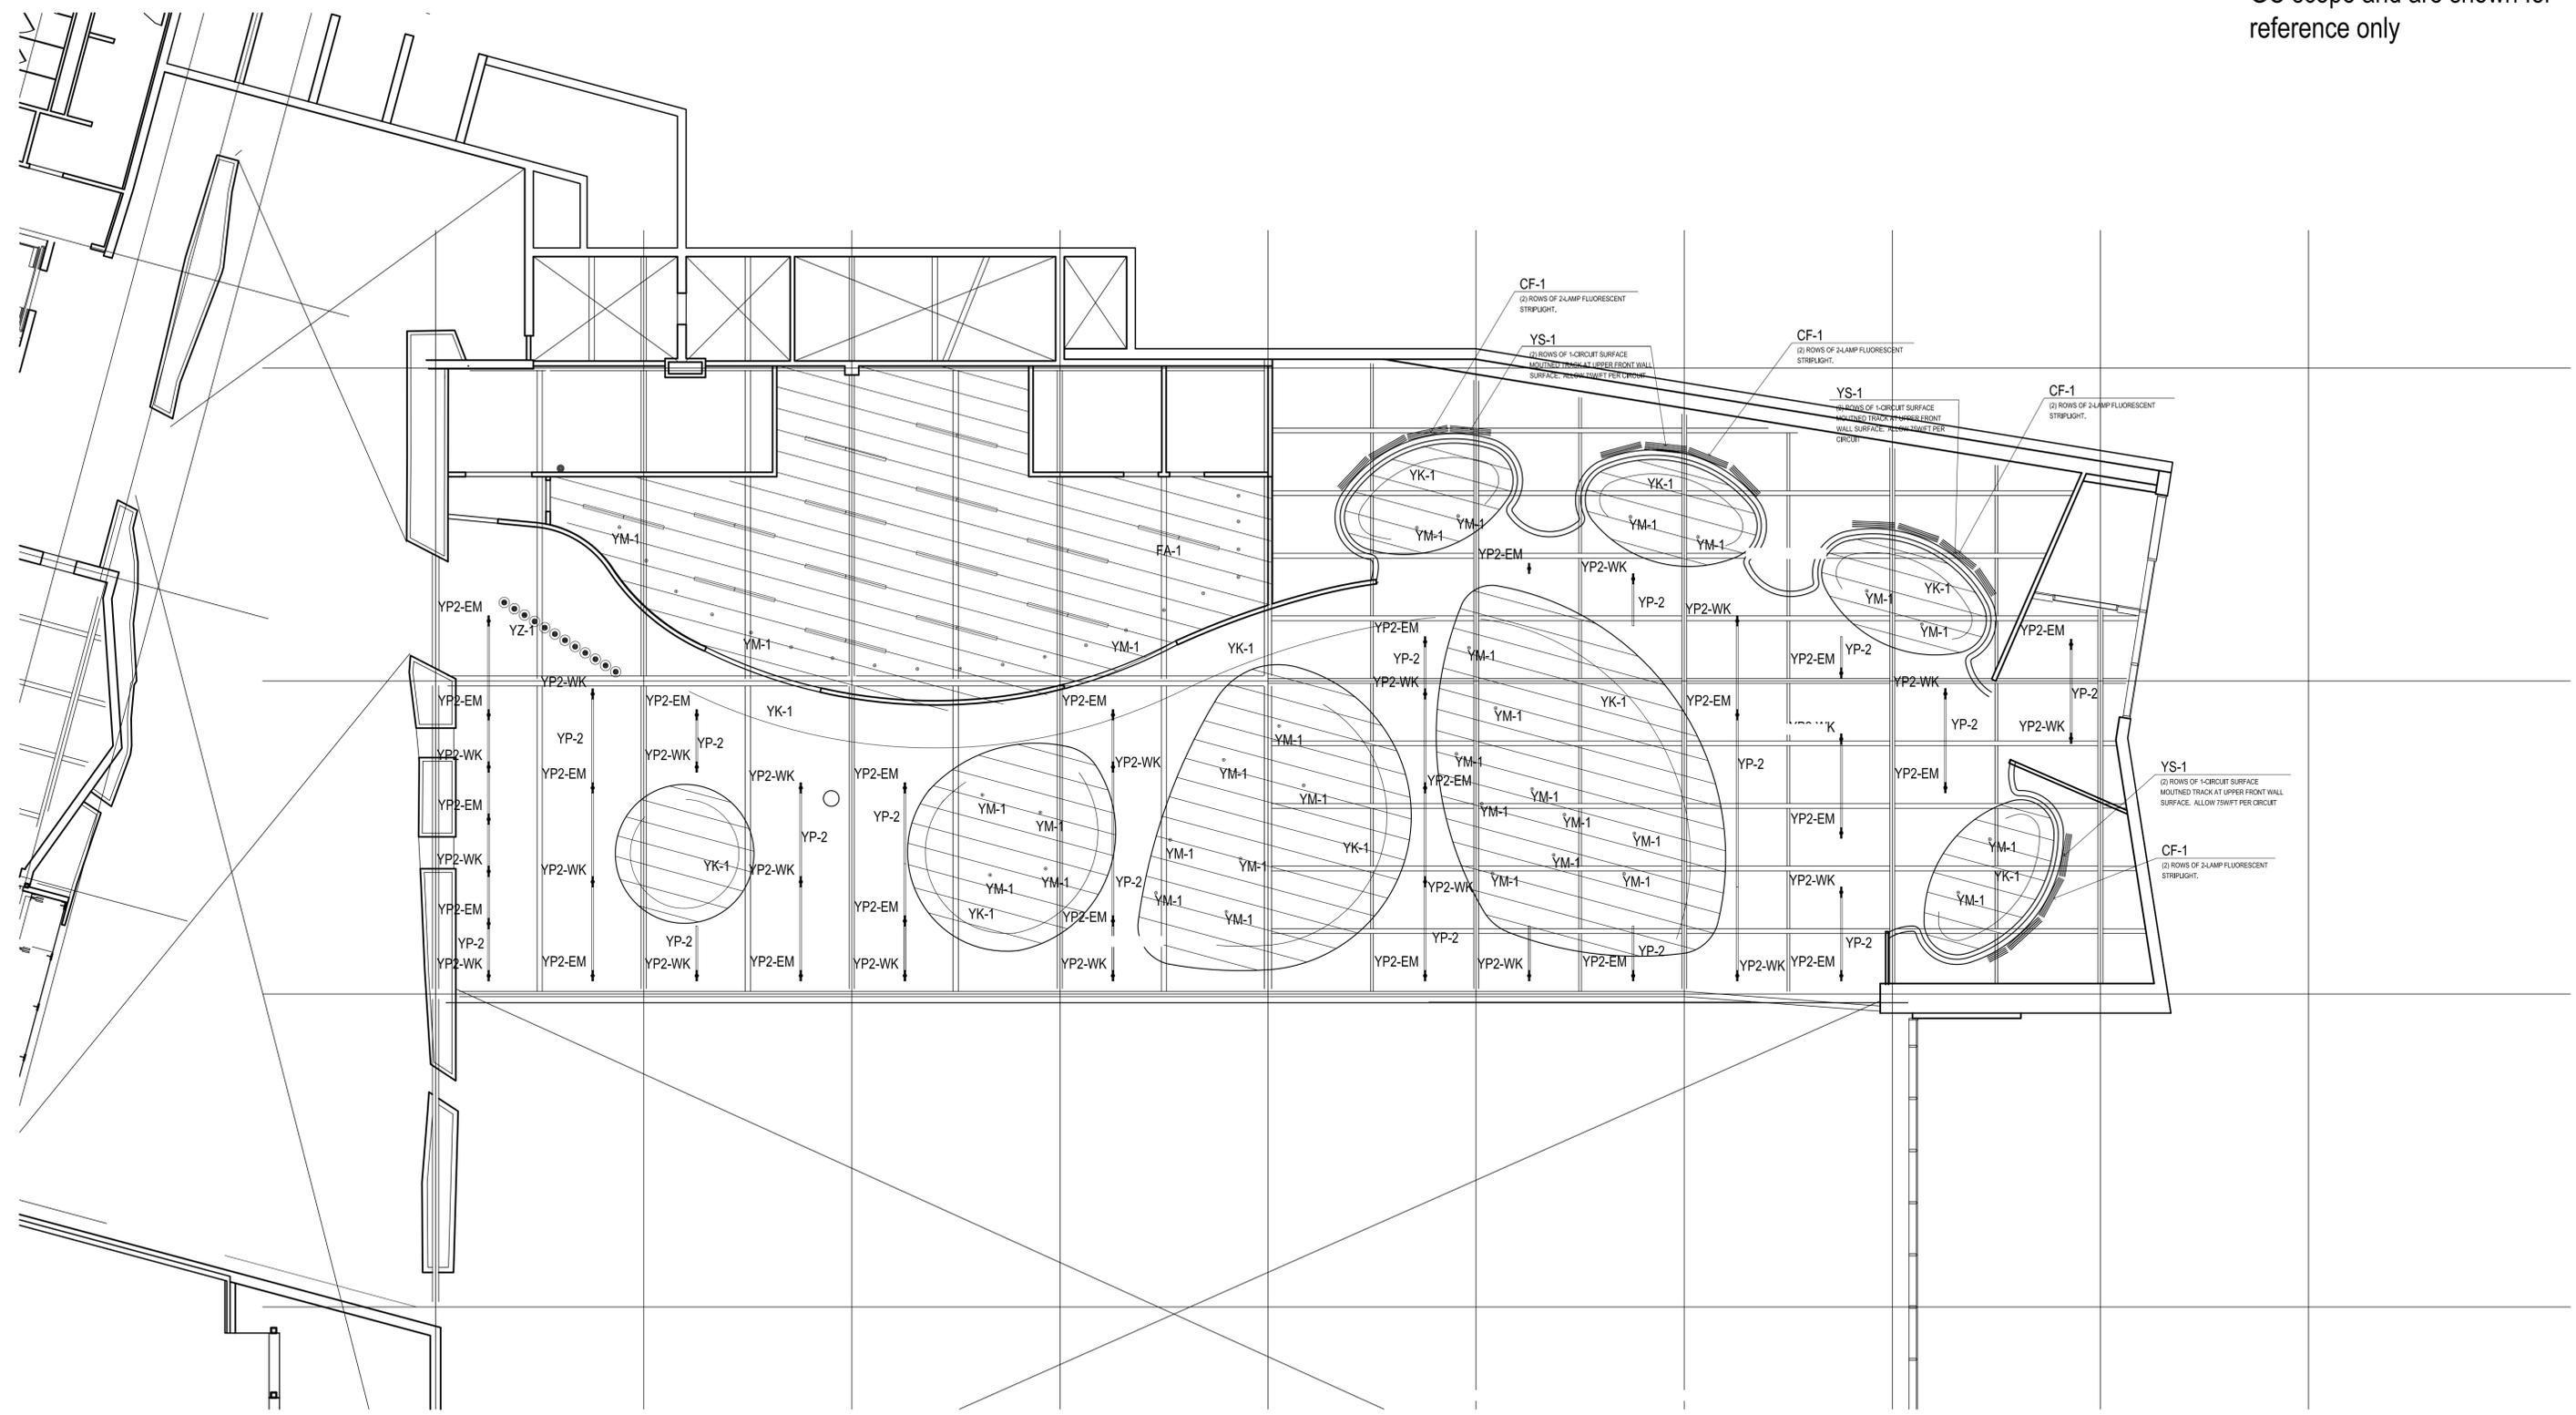


UTAH MUSEUM OF NATURAL HISTORY

UNIVERSITY OF UTAH, SALT LAKE CITY, UTAH

Exhibit Construction

Owner UMNH 1390 East President's Circle Salt Lake City, Utah 84112 801.581.6927 tel.	Design Architect Polshak Partnership Architects LLP 320 West 13th Street New York, New York 212.807.7171 tel.	Architect of Record Gillespie Scharf Smith 30 Broad Street Salt Lake City, Utah 801.521.8600 tel.	Structural Engineer Leslie E. Robertson Associates 30 Broad Street New York, New York 10004 212.750.9000 tel.	Mechanical/Plumbing/Fire Protection Cajigas Engineering Associates, Inc. 244 West 300 North Salt Lake City, Utah 84103 801.322.2400 tel.	Electrical/AV Engineer Spectrum Engineers 175 South Main Street Salt Lake City, Utah 84111 800.678.7077 tel.	Landscape Architect Design Workshop, Inc. 1796 Prospector Avenue Park City, Utah 84060 435.655.0915 tel.	Exhibition Planner and Rabinowitz Associates 88 Pine Street New York, New York 10005 212.334.8200 tel.	Lighting Designer Brandston Partnership Inc 122 West 26th Street New York, New York 10001 212.924.4050 tel.
---	--	--	--	---	---	---	---	--

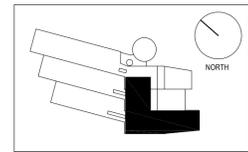

Key Plan

80% FD	Dec. 19, 2008
100% DD	June 2, 2008
XG 60% CD	May 5, 2008
WS9	March 26, 2008
WS8	Feb. 20, 2008
WS7	Dec. 18, 2007
50% DD	Sept. 18, 2007
WS6	July 11, 2007
WS5	May 23, 2007
WS4	April 12, 2007


No. / Issue Name / Date

No. / Issue Name / Date

Sheet Title
Level 4 RCP

Date	Project No.
Dec. 19, 2008	0275
Scale*	Sheet No.
1/8"=1'-0"	LX-L4-0.01

*Note: Scale Given for Full Size Drawing Sheet (22" x 34")

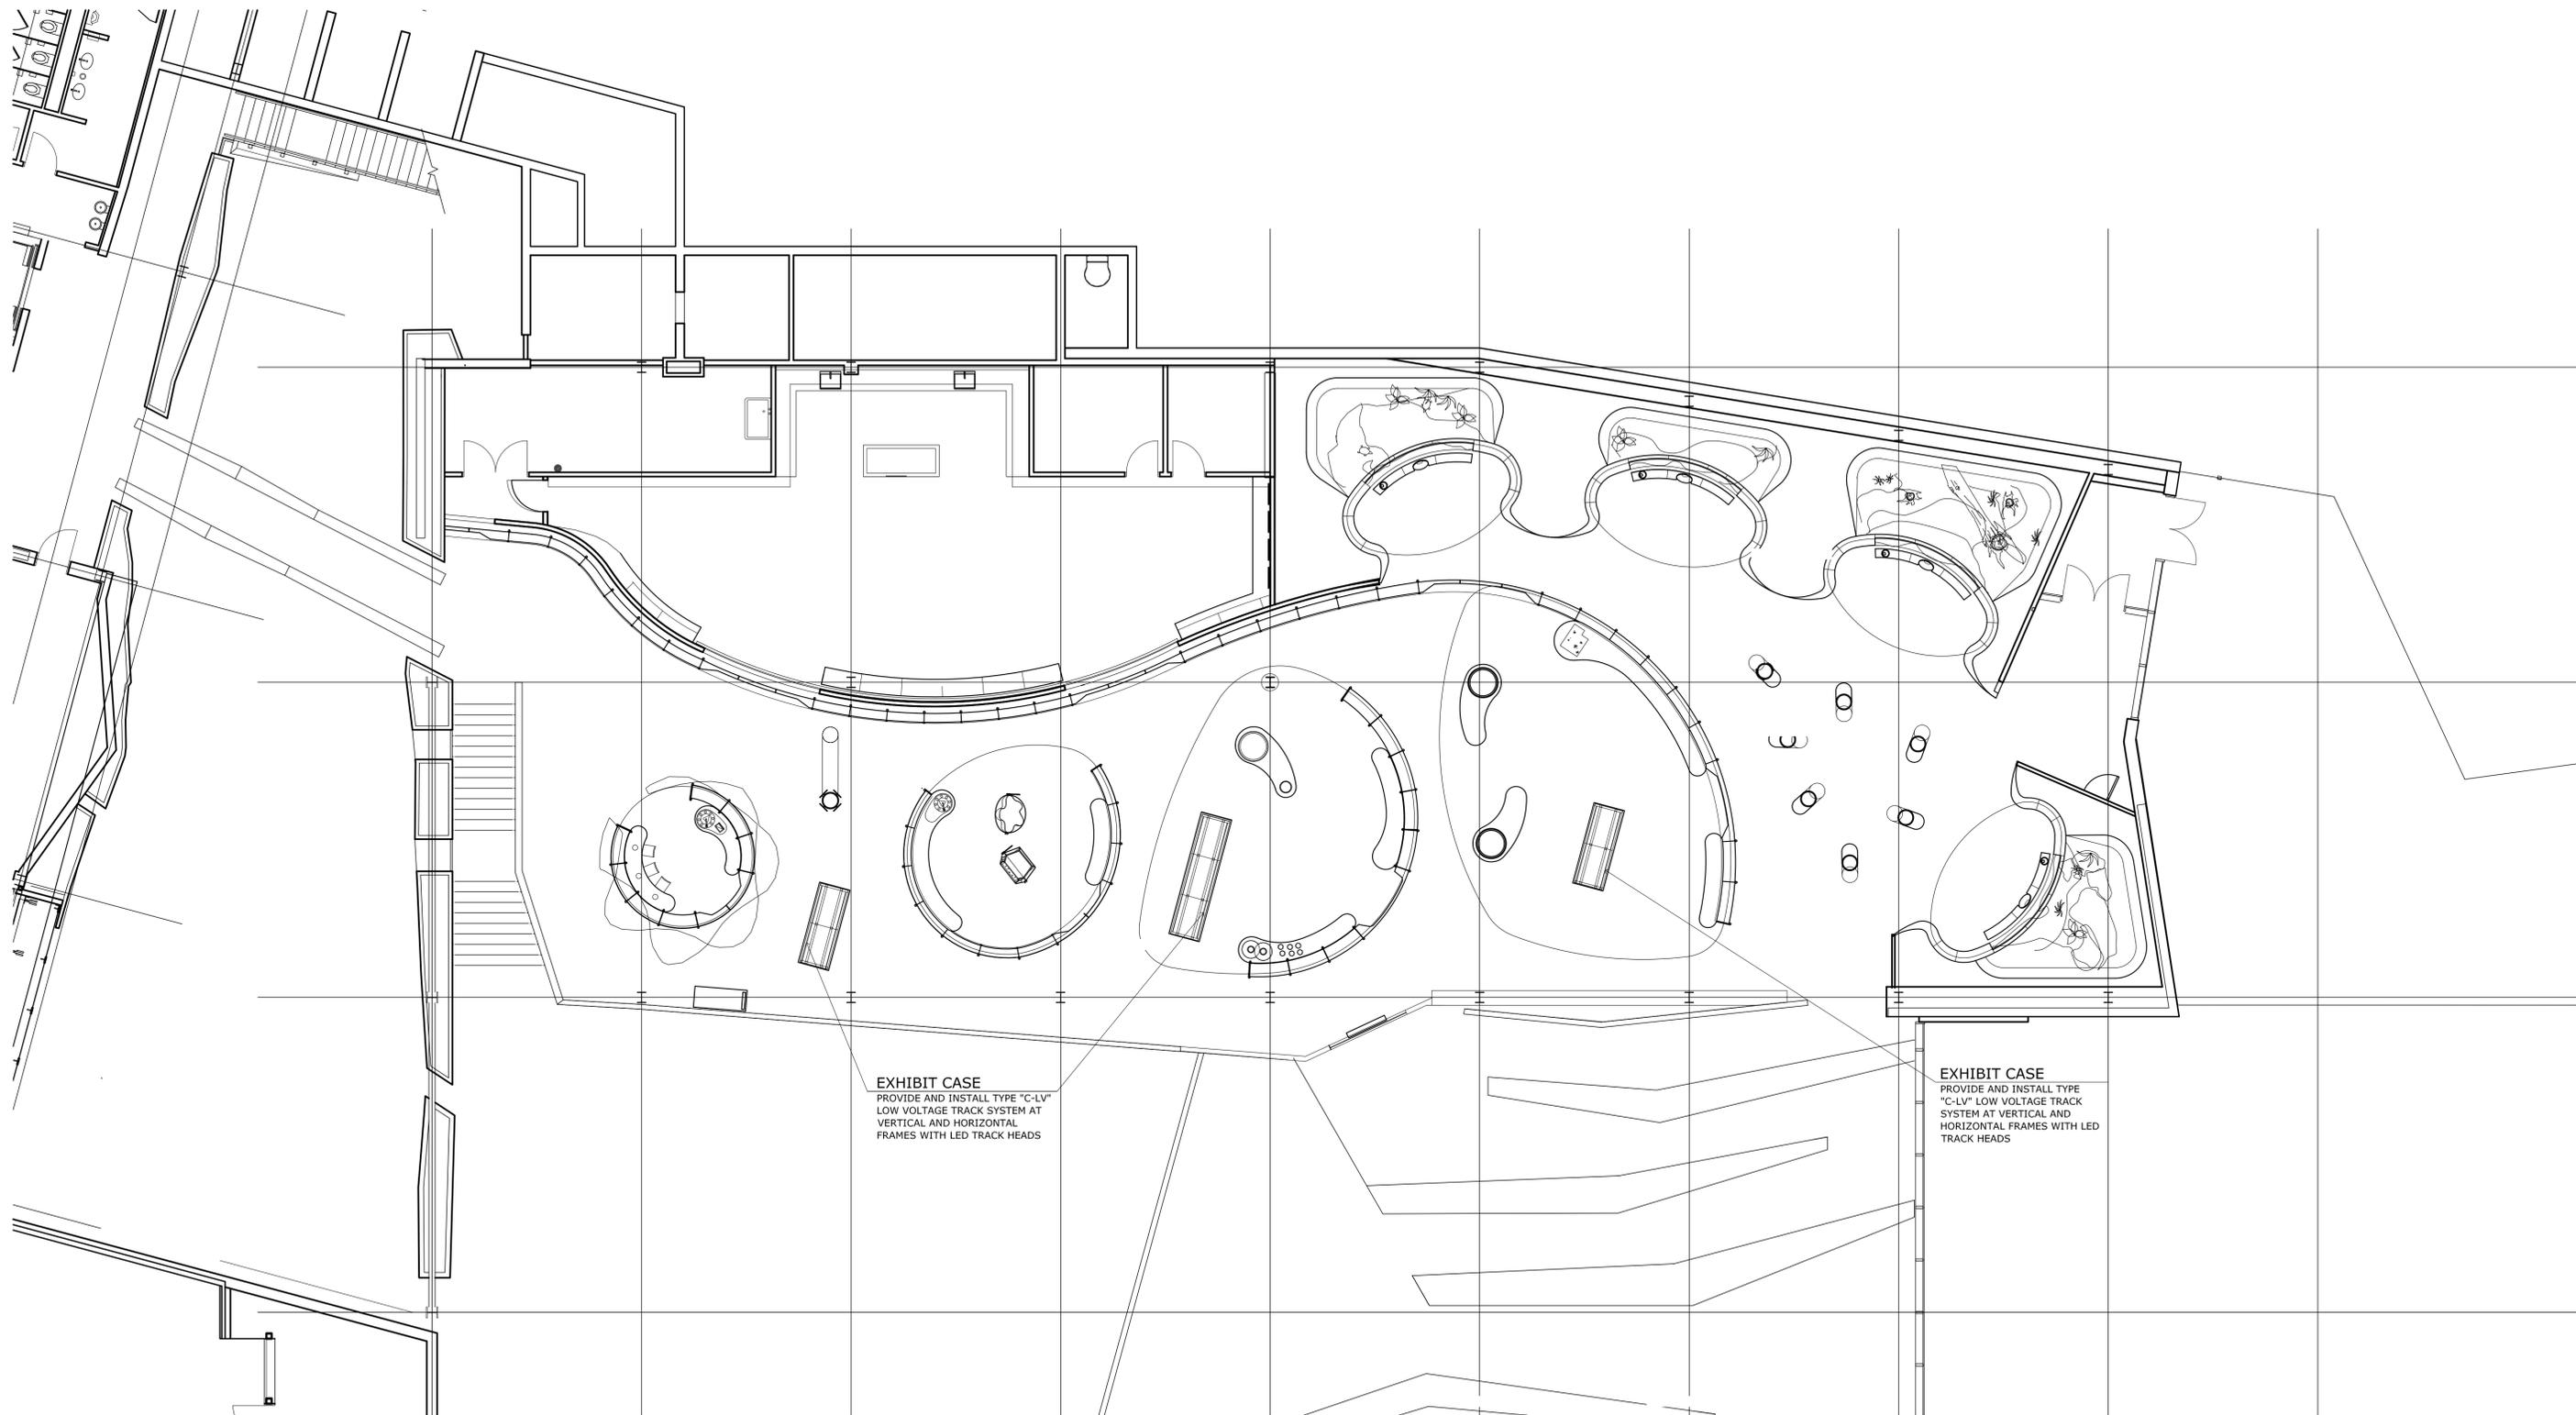


UTAH MUSEUM OF NATURAL HISTORY

UNIVERSITY OF UTAH, SALT LAKE CITY, UTAH

Owner UMNH 1390 East President's Circle Salt Lake City, Utah 84112 801.581.6927 tel.	Design Architect Polshak Partnership Architects LLP 320 West 13th Street New York, New York 212.807.7171 tel.	Architect of Record Rafael Aronovitch Architects 375 West 200 South Salt Lake City, Utah 801.521.8600 tel.	Structural Engineer Leslie E. Robertson Associates 30 Broad Street New York, New York 10004 212.750.9000 tel.	Mechanical/Plumbing/Fire Protection Cohen Engineering Associates, Inc. 244 West 300 North Salt Lake City, Utah 84103 801.322.2400 tel.	Electrical/AV Engineer Spectrum Engineers 175 South Main Street Salt Lake City, Utah 84111 800.678.7077 tel.	Landscape Architect Design Workshop, Inc. 1798 Prospector Avenue Park City, Utah 84060 435.655.0915 tel.	Exhibition Planner and Rafael Aronovitch Associates 88 Pine Street New York, New York 10005 212.334.8200 tel.	Lighting Designer Brandston Partnership Inc 122 West 26th Street New York, New York 10001 212.924.4050 tel.
---	--	---	--	---	---	---	--	--

Exhibit Construction

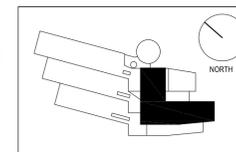

Key Plan

80% FD	Dec. 19, 2008
100% DD	June 2, 2008
XG 60% CD	May 5, 2008
WS9	March 26, 2008
WS8	Feb. 20, 2008
WS7	Dec. 18, 2007
50% DD	Sept. 18, 2007
WS6	July 11, 2007
WS5	May 23, 2007
WS4	April 12, 2007

No. / Issue Name / Date



No. / Issue Name / Date

Sheet Title
Level 4 Lighting Plan

Date
Dec. 19, 2008
Scale*
1/8"=1'-0"

Project No.
0275
Sheet No.
LX-L4-1.00

*Note: Scale Given for Full Size Drawing Sheet (22" x 34")

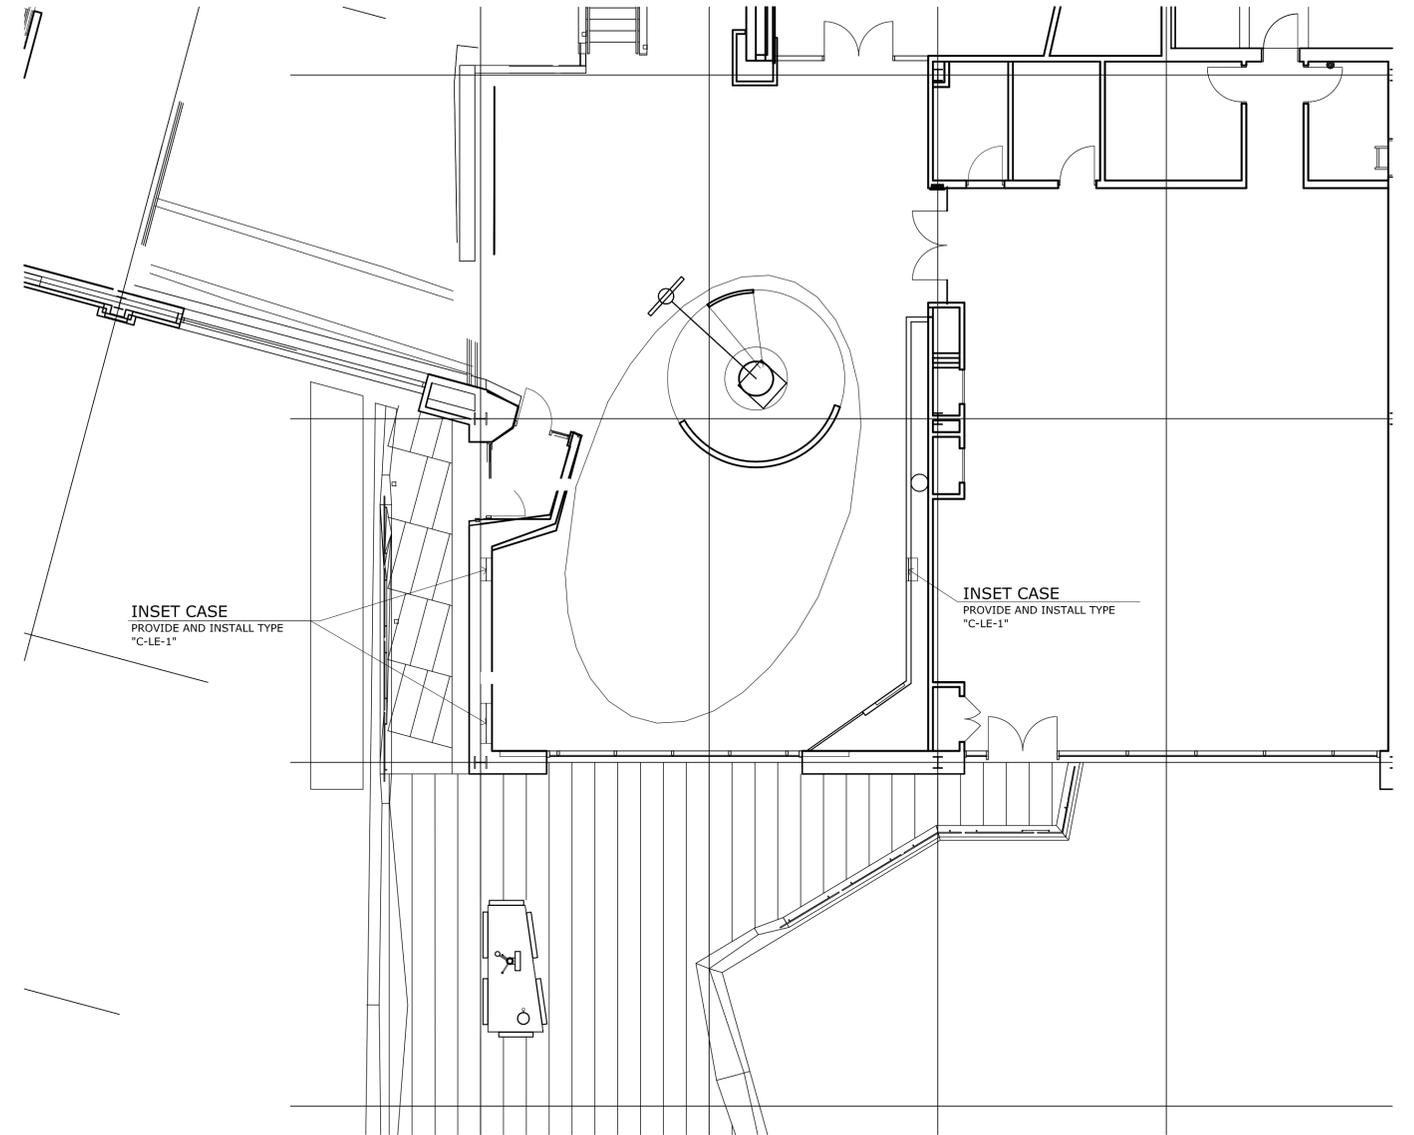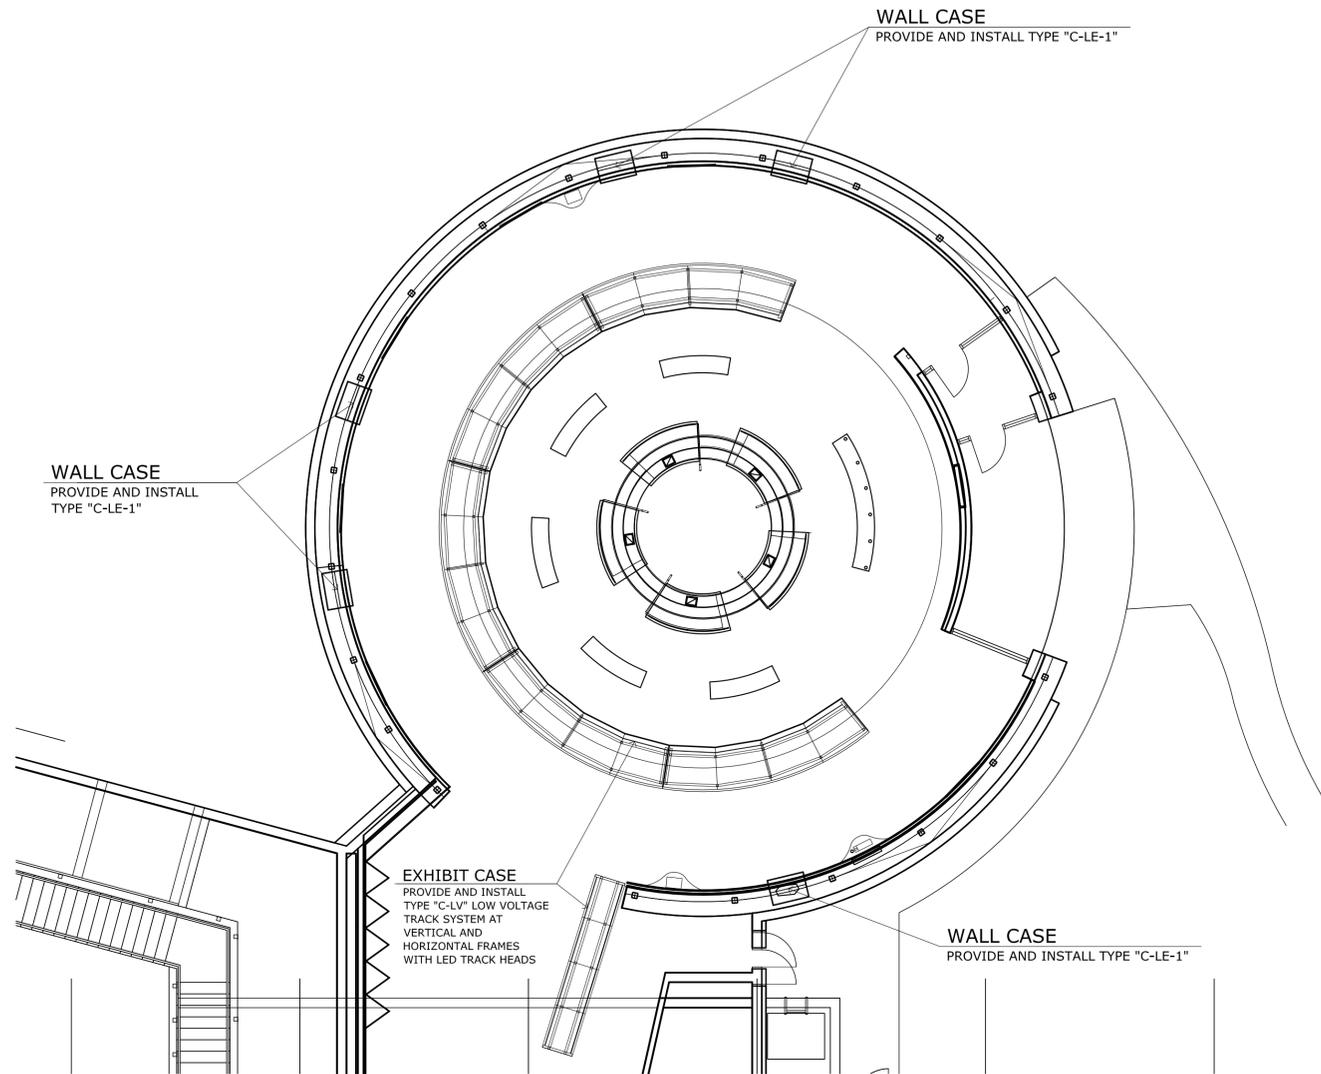


UTAH MUSEUM OF NATURAL HISTORY

UNIVERSITY OF UTAH, SALT LAKE CITY, UTAH

Owner UMNH 1390 East President's Circle Salt Lake City, Utah 84112 801.581.6927 tel.	Design Architect Polshak Partnership Architects LLP 320 West 13th Street New York, New York 212.807.7171 tel.	Architect of Record Gillespie + Partners 375 West 200 South Salt Lake City, Utah 801.521.8600 tel.	Structural Engineer Leslie E. Robertson Associates 30 Broad Street New York, New York 10004 212.750.9000 tel.	Mechanical/Plumbing/Fire Protection Coligni Engineering Associates, Inc. 244 West 300 North Salt Lake City, Utah 84103 801.322.2400 tel.	Electrical/AV Engineer Spectrum Engineers 175 South Main Street Salt Lake City, Utah 84111 800.678.7077 tel.	Landscape Architect Design Workshop, Inc. 1796 Prospector Avenue Park City, Utah 84060 435.655.0915 tel.	Exhibition Planner and Rabinowitz Associates 88 Pine Street New York, New York 10005 212.334.8200 tel.	Lighting Designer Brandston Partnership Inc 122 West 26th Street New York, New York 10001 212.924.4050 tel.
---	--	---	--	---	---	---	---	--

Exhibit Construction

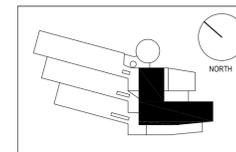

Key Plan

80% FD	Dec. 19, 2008
100% DD	June 2, 2008
XG 60% CD	May 5, 2008
WS9	March 26, 2008
WS8	Feb. 20, 2008
WS7	Dec. 18, 2007
50% DD	Sept. 18, 2007
WS6	July 11, 2007
WS5	May 23, 2007
WS4	April 12, 2007

No. / Issue Name / Date

No. / Issue Name / Date

Sheet Title
Level 5 Lighting Plan


Date
Dec. 19, 2008

Scale*
1/8"=1'-0"

Project No.
0275

Sheet No.
LX-L5-1.00

*Note: Scale Given for Full Size Drawing Sheet (22" x 34")

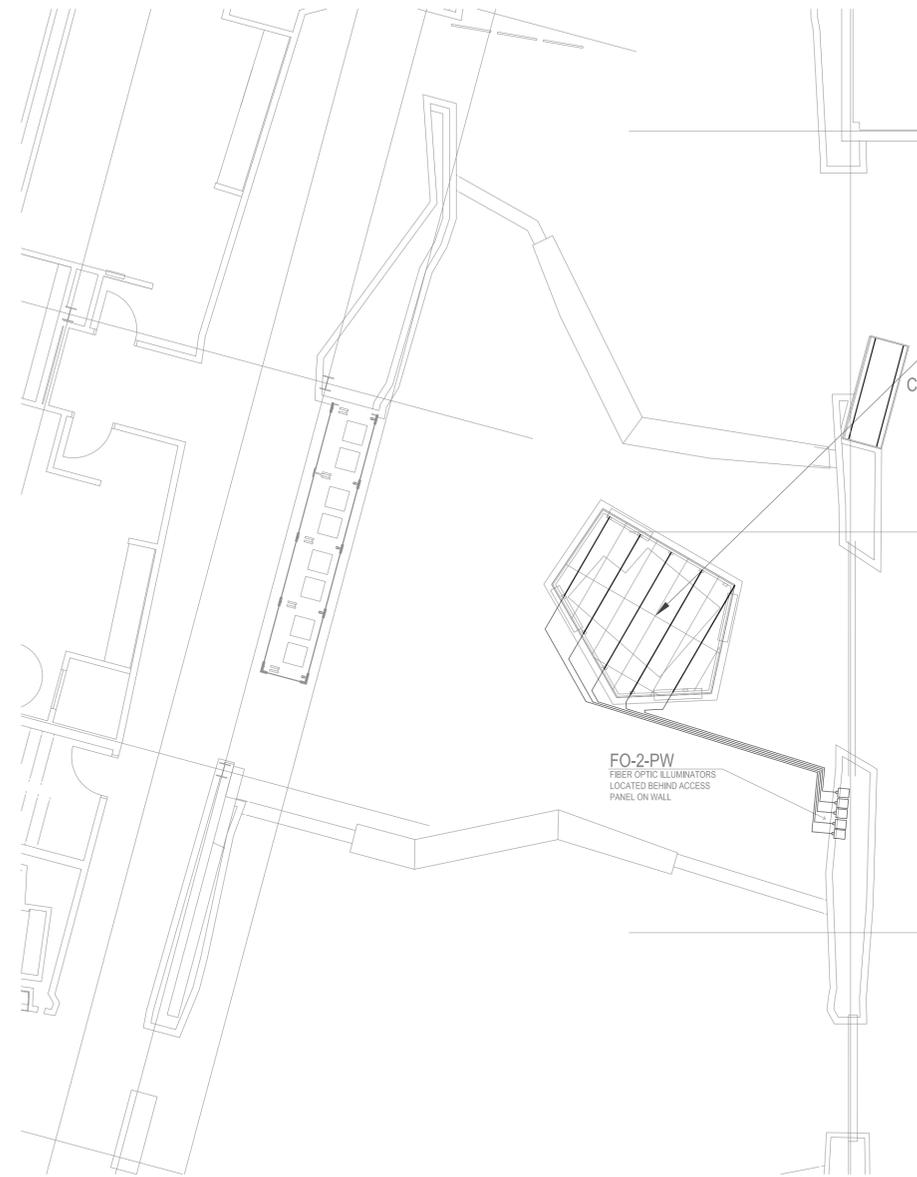

'FO2-PW' (FO-200) - ADD ALTERNATE
 SIDE-EMITTING FIBEROPTIC SYSTEM MOUNTED AT
 FLOOR FRAME UNDERSIDE WITH REMOTE METAL
 HALIDE ILLUMINATORS

PURCHASED AND INSTALLED BY GC

FO-2-PW
 FIBER OPTIC ILLUMINATORS
 LOCATED BEHIND ACCESS
 PANEL ON WALL


C-L

UTAH MUSEUM OF NATURAL HISTORY

UNIVERSITY OF UTAH, SALT LAKE CITY, UTAH

Owner UMNH 1300 East President's Circle Salt Lake City, Utah 84112 801.581.6927 tel.	Design Architect Polshak Partnership Architects LLP 320 West 13th Street New York, New York 212.807.7171 tel.	Architect of Record Giffels Stransky Brems Smith 375 West 200 South Salt Lake City, Utah 801.521.8600 tel.	Structural Engineer Leslie E. Robertson Associates 30 Broad Street New York, New York 10004 212.750.9000 tel.	Mechanical/Plumbing/Fire Protection Cajigas Engineering Associates, Inc. 244 West 300 North Salt Lake City, Utah 84103 801.322.2400 tel.	Electrical/AV Engineer Spectrum Engineers 175 South Main Street Salt Lake City, Utah 84111 800.678.7077 tel.	Landscape Architect Design Workshop, Inc. 1796 Prospector Avenue Park City, Utah 84060 435.655.0915 tel.	Exhibition Planner and Rabin Rabinbaum Associates 88 Pine Street New York, New York 10005 212.334.8200 tel.	Lighting Designer Brandston Partnership Inc 122 West 26th Street New York, New York 10001 212.924.4050 tel.
---	--	---	--	---	---	---	--	--

Exhibit Construction

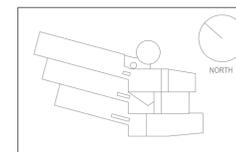

Key Plan

80% FD	Dec. 19, 2008
100% DD	June 2, 2008
XG 60% CD	May 5, 2008
WS9	March 26, 2008
WS8	Feb. 20, 2008
WS7	Dec. 18, 2007
50% DD	Sept. 18, 2007
WS6	July 11, 2007
WS5	May 23, 2007
WS4	April 12, 2007

No. / Issue Name / Date

No. / Issue Name / Date

Sheet Title
**Level 1 Partial Plan:
 Trailhead**


Date
 Dec. 19, 2008

Scale*
 1/8"=1'-0"

Project No.
 0275

Sheet No.
LX1-TH-1.00

*Note: Scale Given for Full Size Drawing Sheet (22" x 34")

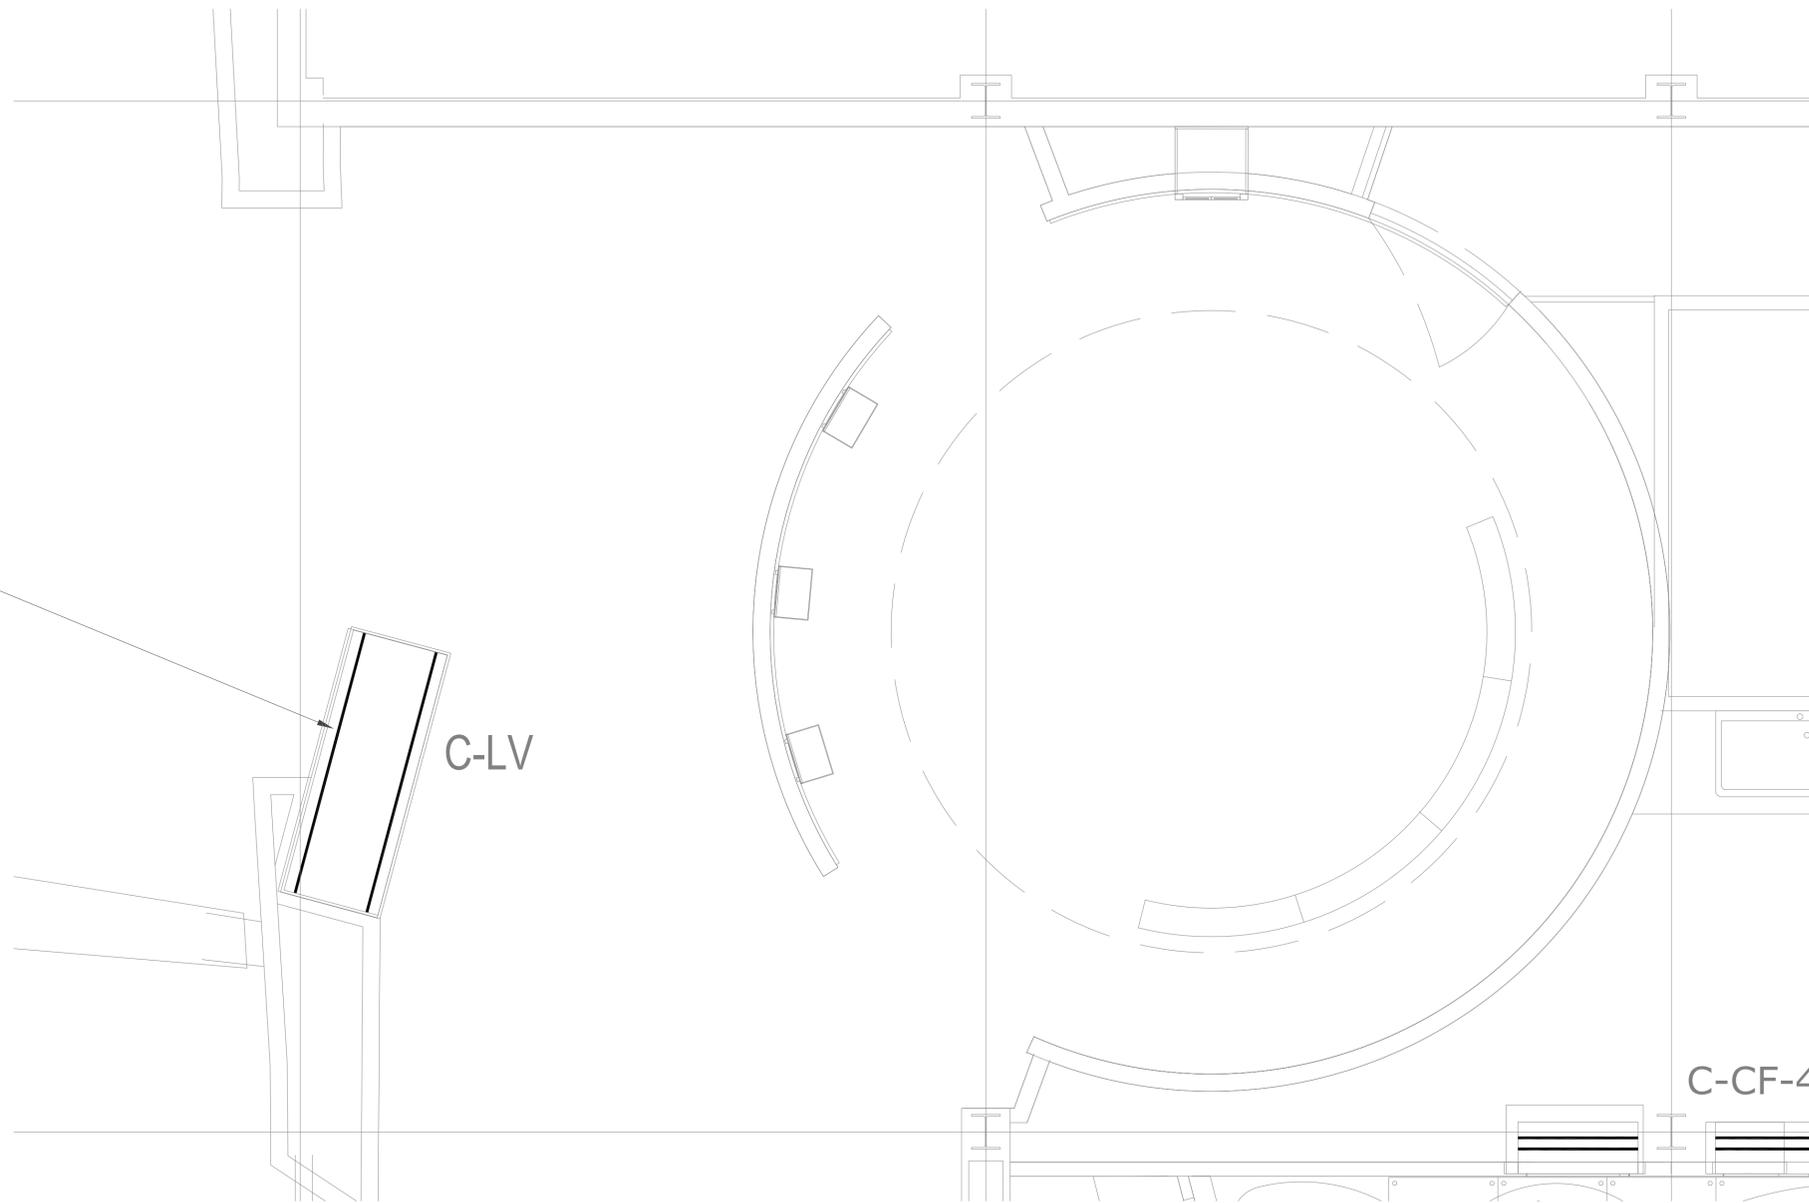

'C-LV'
 LOW VOLTAGE TRACK SYSTEM MOUNTED TO
 CASE FRAMES WITH LED TRACK HEADS AND
 REMOTE TRANSFORMERS
 PURCHASED AND INSTALLED BY XC

C-LV


C-CF-4

UTAH MUSEUM OF NATURAL HISTORY

UNIVERSITY OF UTAH, SALT LAKE CITY, UTAH

Owner UMNH 1300 East President's Circle Salt Lake City, Utah 84112 801.581.6927 tel.	Design Architect Polshak Partnership Architects LLP 320 West 13th Street New York, New York 212.807.7171 tel.	Architect of Record Sternberg Architects 375 West 200 South Salt Lake City, Utah 801.521.8600 tel.	Structural Engineer Leslie E. Robertson Associates 30 Broad Street New York, New York 10004 212.750.9000 tel.	Mechanical/Plumbing/Fire Protection Cajigas Engineering Associates, Inc. 244 West 300 North Salt Lake City, Utah 84103 801.322.2400 tel.	Electrical/AV Engineer Spectrum Engineers 175 South Main Street Salt Lake City, Utah 84111 800.678.7077 tel.	Landscape Architect Design Workshop, Inc. 1796 Prospector Avenue Park City, Utah 84060 435.655.0915 tel.	Exhibition Planner and Rabin & Rabin Associates 88 Pine Street New York, New York 10005 212.334.8200 tel.	Lighting Designer Brandston Partnership Inc 122 West 26th Street New York, New York 10001 212.924.4050 tel.
---	--	---	--	---	---	---	--	--

Exhibit Construction

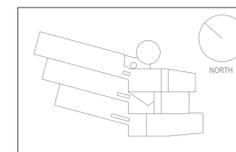

Key Plan

80% FD	Dec. 19, 2008
100% DD	June 2, 2008
XG 60% CD	May 5, 2008
WS9	March 26, 2008
WS8	Feb. 20, 2008
WS7	Dec. 18, 2007
50% DD	Sept. 18, 2007
WS6	July 11, 2007
WS5	May 23, 2007
WS4	April 12, 2007


No. / Issue Name / Date

No. / Issue Name / Date

Sheet Title
 Level 2 Partial Plan:
 Utah Futures Observatory/Mineral Hall

Date Dec. 19, 2008	Project No. 0275
Scale* 1/4"=1'-0"	Sheet No. LX2-UF-1.00

*Note: Scale Given for Full Size Drawing Sheet (22" x 34")

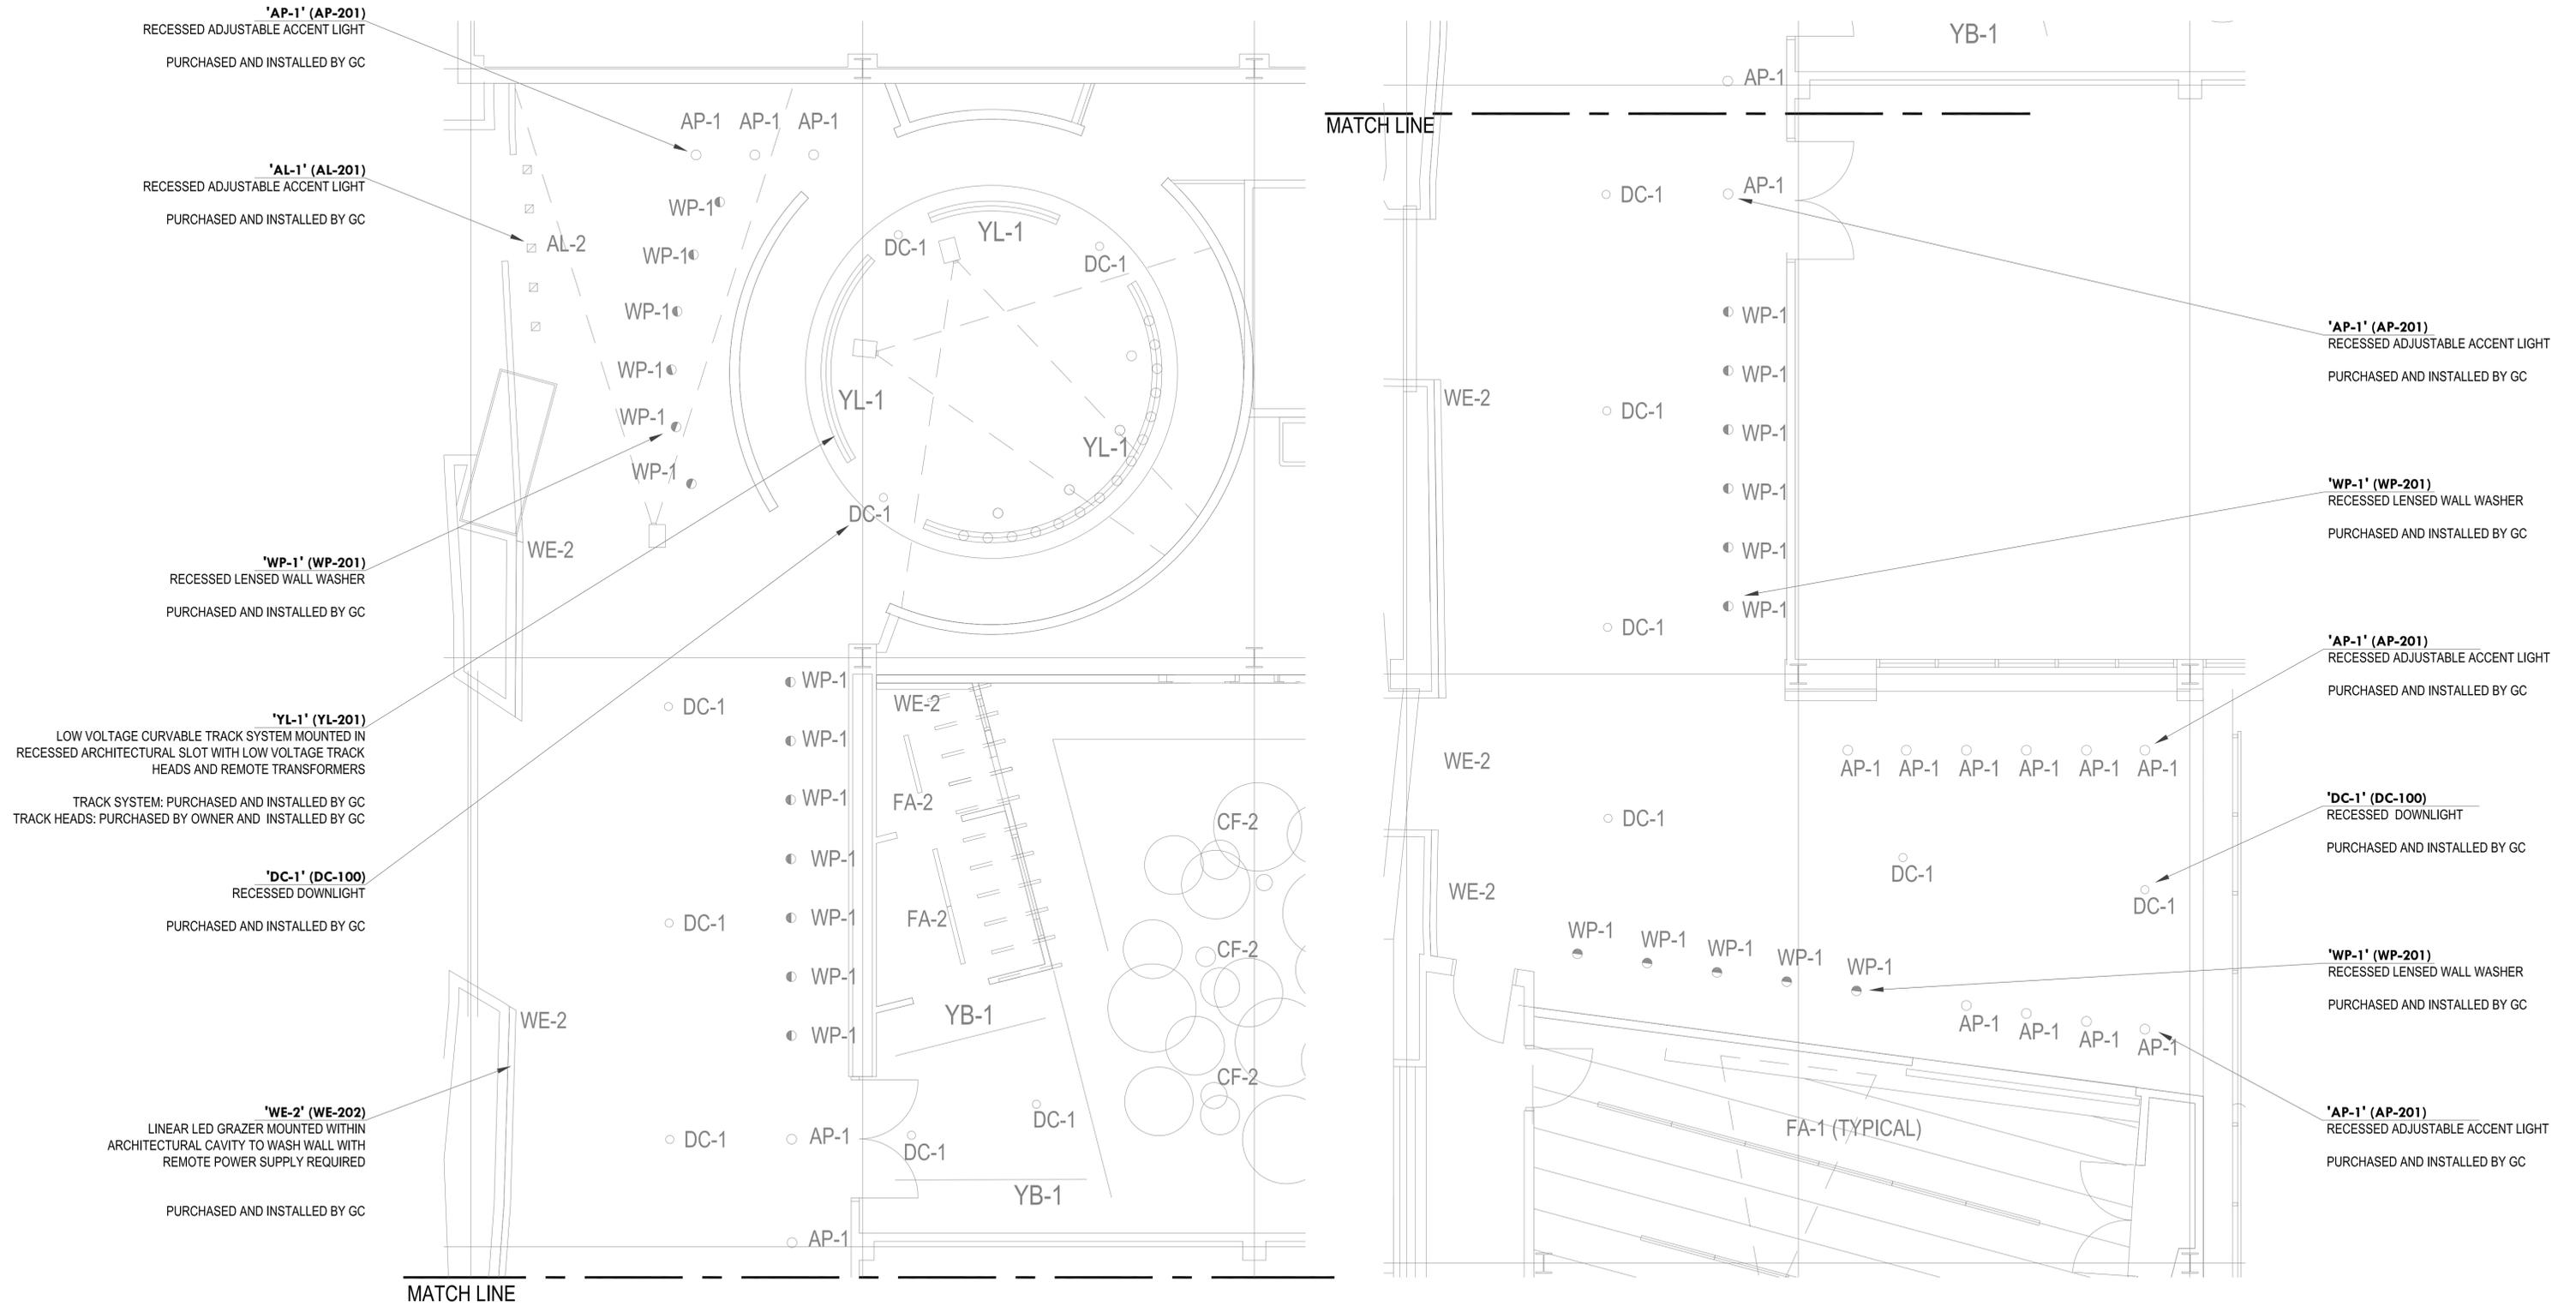


UTAH MUSEUM OF NATURAL HISTORY

UNIVERSITY OF UTAH, SALT LAKE CITY, UTAH

Owner UMNH 1300 East President's Circle Salt Lake City, Utah 84112 801.581.6927 tel.	Design Architect Polshak Partnership Architects LLP 320 West 13th Street New York, New York 212.807.7171 tel.	Architect of Record Srinivasa Brams Smith 375 West 200 South Salt Lake City, Utah 801.521.8600 tel.	Structural Engineer Leslie E. Robertson Associates 30 Broad Street New York, New York 10004 212.750.9000 tel.	Mechanical/Plumbing/Fire Protection Colijn Engineering Associates, Inc. 244 West 300 North Salt Lake City, Utah 84103 801.322.2400 tel.	Electrical/AV Engineer Spectrum Engineers 175 South Main Street Salt Lake City, Utah 84111 800.678.7077 tel.	Landscape Architect Design Workshop, Inc. 1796 Prospector Avenue Park City, Utah 84060 435.655.0915 tel.	Exhibition Planner and Rabin & Rabin Associates 88 Pine Street New York, New York 10005 212.334.8200 tel.	Lighting Designer Brandston Partnership Inc 122 West 26th Street New York, New York 10001 212.924.4050 tel.
---	--	--	--	--	---	---	--	--

Exhibit Construction

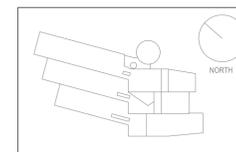

Key Plan

80% FD	Dec. 19, 2008
100% DD	June 2, 2008
XG 60% CD	May 5, 2008
WS9	March 26, 2008
WS8	Feb. 20, 2008
WS7	Dec. 18, 2007
50% DD	Sept. 18, 2007
WS6	July 11, 2007
WS5	May 23, 2007
WS4	April 12, 2007


No. / Issue Name / Date

No. / Issue Name / Date

Sheet Title	
Level 2 Partial RCP: Utah Futures Observatory/Mineral Hall	
Date	Project No.
Dec. 19, 2008	0275
Scale*	Sheet No.
1/4"=1'-0"	LX2-UF-1.02

*Note: Scale Given for Full Size Drawing Sheet (22" x 34")

'NF-1' (NF-200)
 SURFACE MOUNTED FLUORESCENT UNDER CABINET LIGHT
 PURCHASED AND INSTALLED BY GC

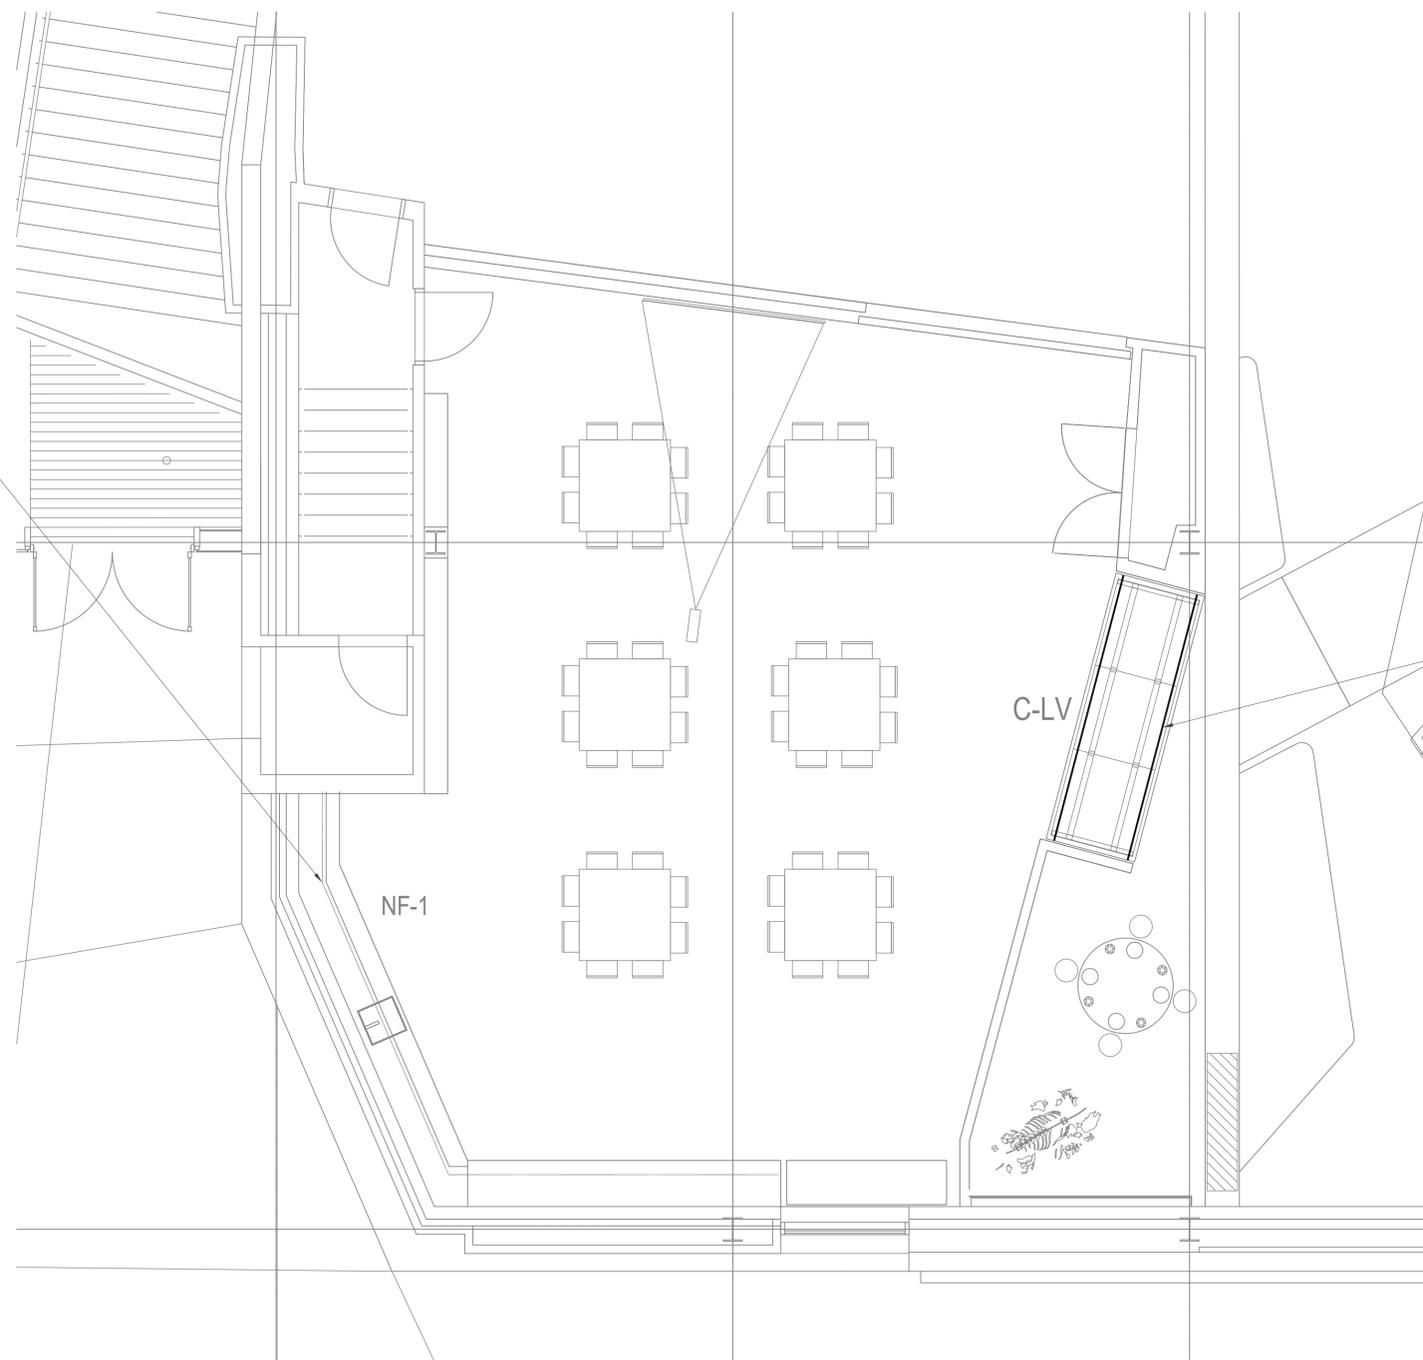


'C-LV'
 LOW VOLTAGE TRACK SYSTEM MOUNTED TO CASE FRAMES WITH LED
 TRACK HEADS AND REMOTE TRANSFORMERS
 PURCHASED AND INSTALLED BY XC

UTAH MUSEUM OF NATURAL HISTORY

UNIVERSITY OF UTAH, SALT LAKE CITY, UTAH

Exhibit Construction

Owner UMNH 1390 East President's Circle Salt Lake City, Utah 84112 801.581.6927 tel.	Design Architect Polshak Partnership Architects LLP 320 West 13th Street New York, New York 212.807.7171 tel.	Architect of Record Sofsky Brems Smith 375 West 200 South Salt Lake City, Utah 801.521.8600 tel.	Structural Engineer Leslie E. Robertson Associates 30 Broad Street New York, New York 10004 212.750.9000 tel.	Mechanical/Plumbing/Fire Protection C&E Engineering Associates, Inc. 244 West 300 North Salt Lake City, Utah 84103 801.322.2400 tel.	Electrical/AV Engineer Spectrum Engineers 175 South Main Street Salt Lake City, Utah 84111 800.678.7077 tel.	Landscape Architect Design Workshop, Inc. 1796 Prospector Avenue Park City, Utah 84060 435.655.0915 tel.	Exhibition Planner and Rabinoff Associates 88 Pine Street New York, New York 10005 212.334.8200 tel.	Lighting Designer Brandston Partnership Inc 122 West 26th Street New York, New York 10001 212.924.4050 tel.
---	--	---	--	---	---	---	---	--

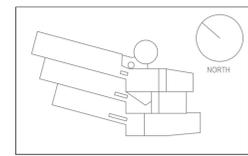

Key Plan

80% FD	Dec. 19, 2008
100% DD	June 2, 2008
XG 60% CD	May 5, 2008
WS9	March 26, 2008
WS8	Feb. 20, 2008
WS7	Dec. 18, 2007
50% DD	Sept. 18, 2007
WS6	July 11, 2007
WS5	May 23, 2007
WS4	April 12, 2007

No. / Issue Name / Date

No. / Issue Name / Date

Sheet Title
**Level 2 Partial Plan:
 Earth Lab**


Date
 Dec. 19, 2008

Scale*
 1/4"=1'-0"

Project No.
 0275

Sheet No.
LX2-EL-1.00

*Note: Scale Given for Full Size Drawing Sheet (22" x 34")

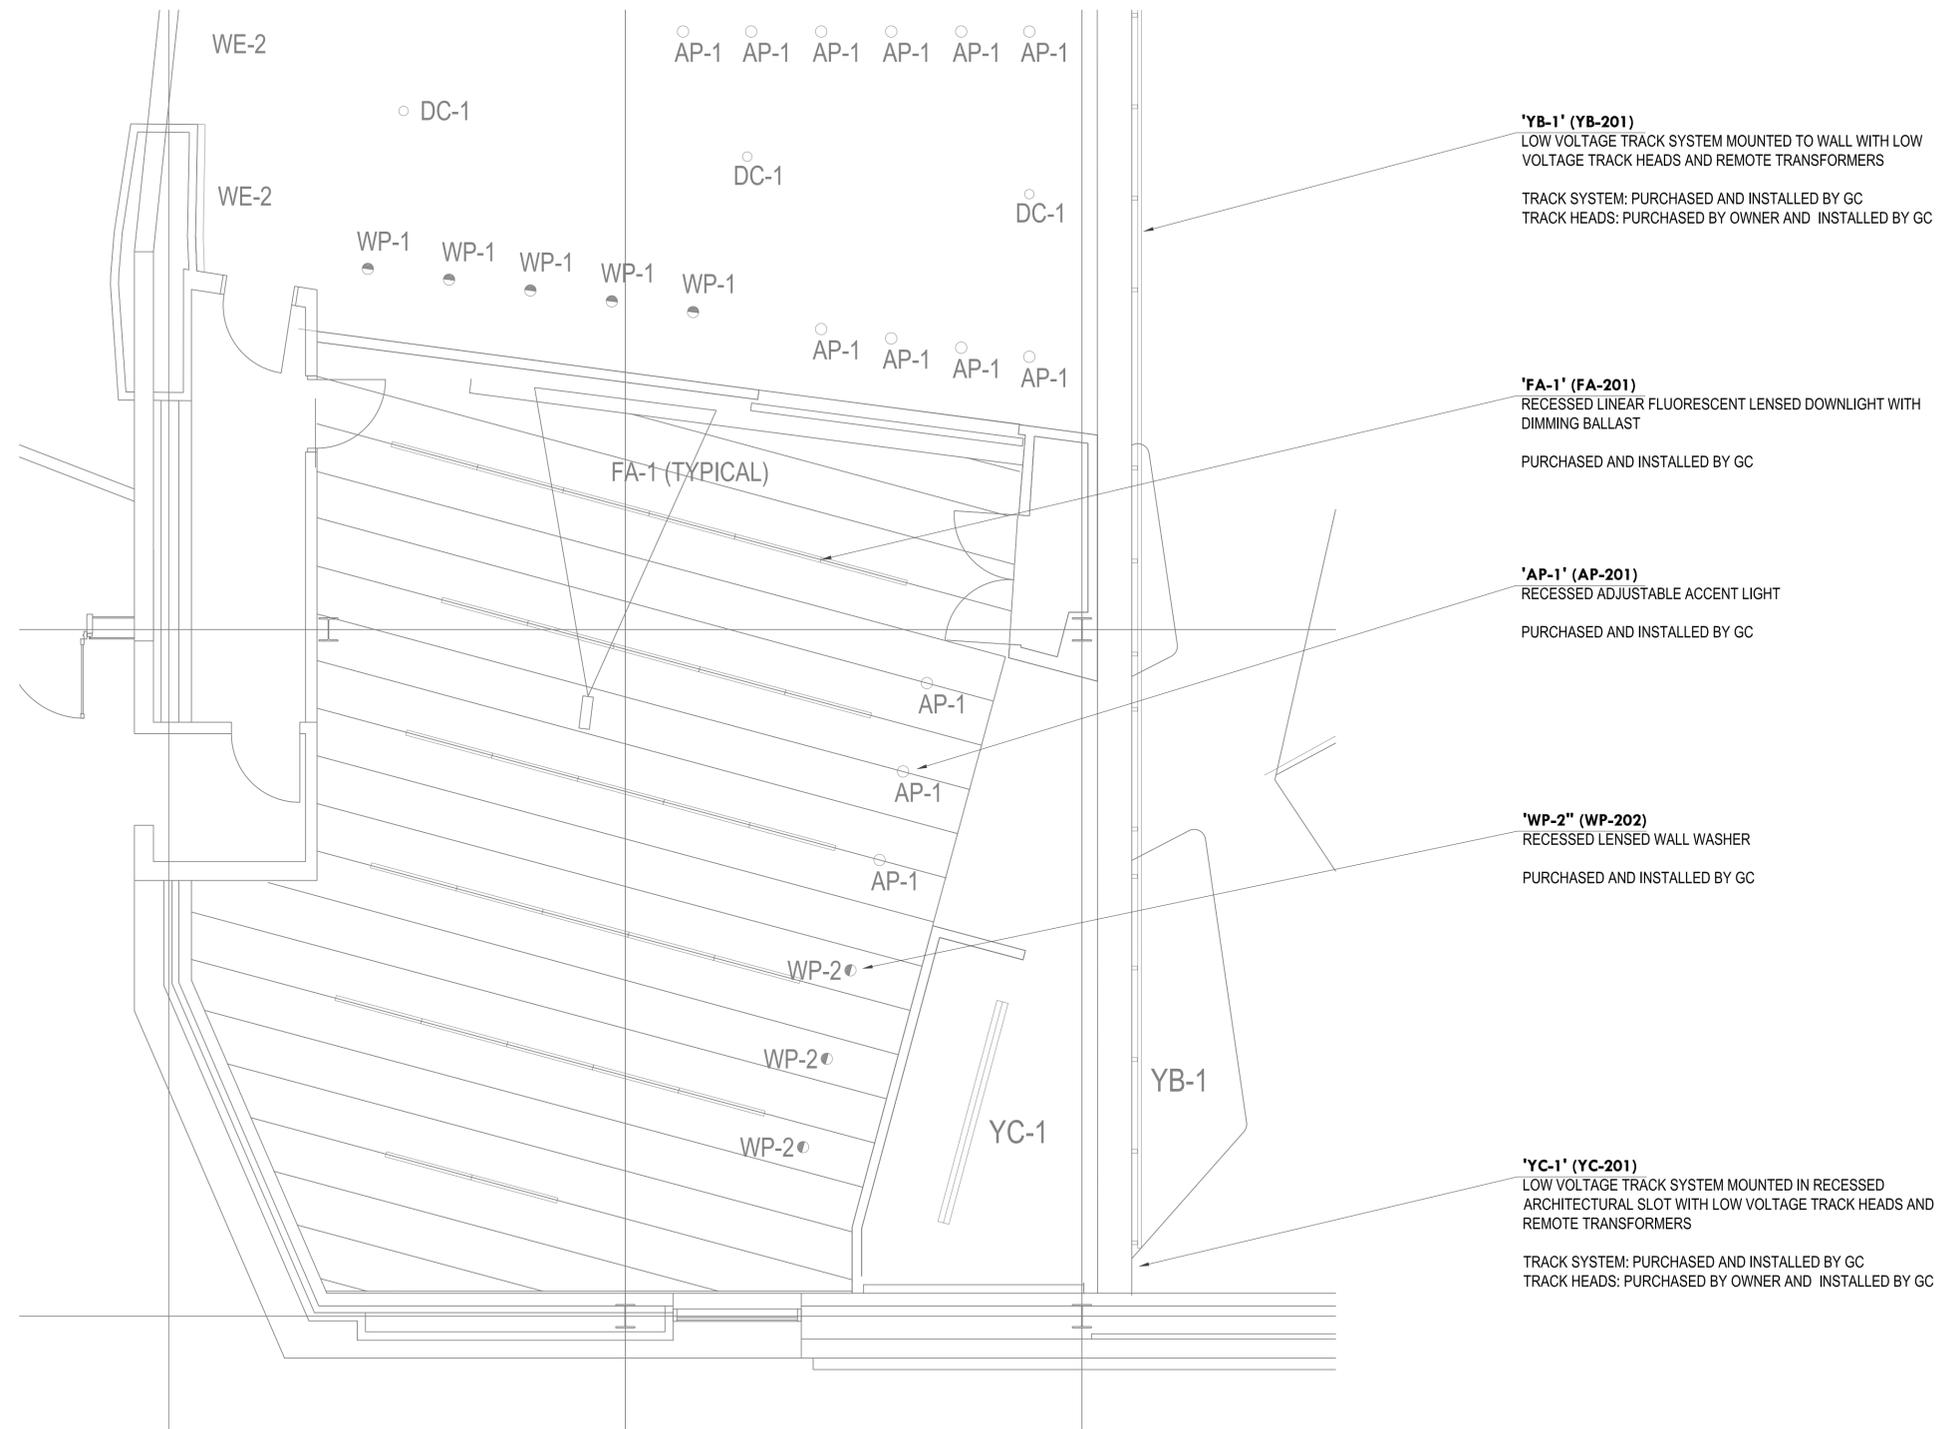


UTAH MUSEUM OF NATURAL HISTORY

UNIVERSITY OF UTAH, SALT LAKE CITY, UTAH

Owner UMNH 1390 East President's Circle Salt Lake City, Utah 84112 801.581.6927 tel.	Design Architect Polshak Partnership Architects LLP 320 West 13th Street New York, New York 212.807.7171 tel.	Architect of Record Stiles/Schinsky Brems Smith 375 West 200 South Salt Lake City, Utah 801.521.8600 tel.	Structural Engineer Leslie E. Robertson Associates 30 Broad Street New York, New York 10004 212.750.9000 tel.	Mechanical/Plumbing/Fire Protection Caldwell Engineering Associates, Inc. 244 West 300 North Salt Lake City, Utah 84103 801.322.2400 tel.	Electrical/AV Engineer Spectrum Engineers 175 South Main Street Salt Lake City, Utah 84101 800.678.7077 tel.	Landscape Architect Design Workshop, Inc. 1796 Prospector Avenue Park City, Utah 84060 435.655.0915 tel.	Exhibition Planner and Rabinowitz Associates 88 Pine Street New York, New York 10005 212.334.8200 tel.	Lighting Designer Brandston Partnership Inc 122 West 26th Street New York, New York 10001 212.924.4050 tel.
--	---	---	---	---	--	--	--	---

Exhibit Construction

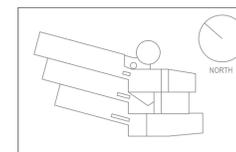

Key Plan

80% FD	Dec. 19, 2008
100% DD	June 2, 2008
XG 60% CD	May 5, 2008
WS9	March 26, 2008
WS8	Feb. 20, 2008
WS7	Dec. 18, 2007
50% DD	Sept. 18, 2007
WS6	July 11, 2007
WS5	May 23, 2007
WS4	April 12, 2007

No. / Issue Name / Date

No. / Issue Name / Date

Sheet Title
Level 2 Partial RCP:
Earth Lab


Date
Dec. 19, 2008

Scale*
1/4"=1'-0"


Project No.
0275

Sheet No.
LX2-EL-1.02

*Note: Scale Given for Full Size Drawing Sheet (22" x 34")

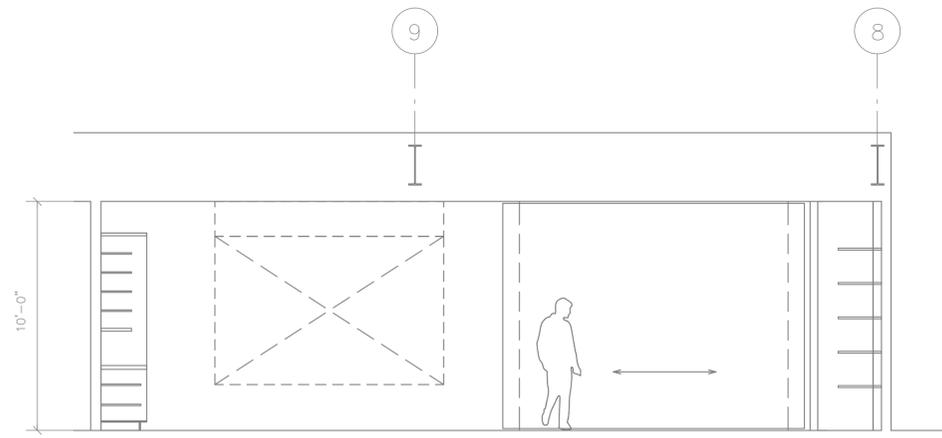


1 EAST ELEVATION
SCALE: 1/4" = 1'-0"

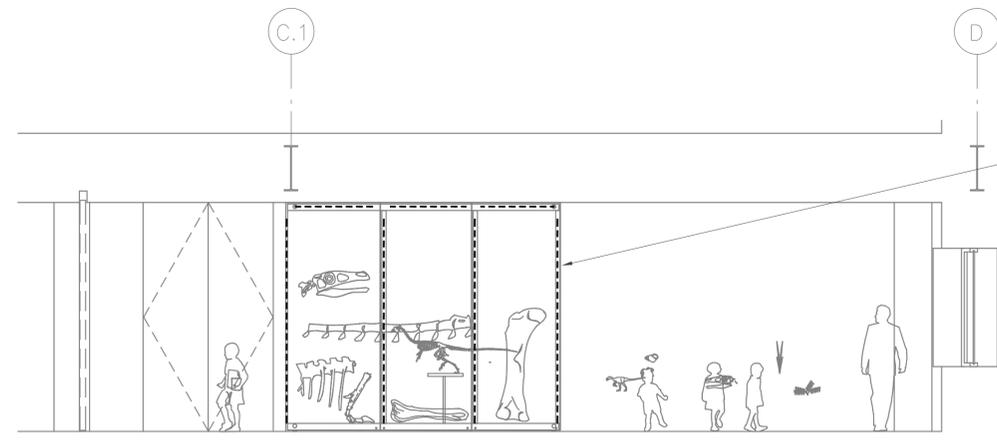

'C-LV'
LOW VOLTAGE TRACK SYSTEM MOUNTED TO
CASE FRAMES WITH LED TRACK HEADS AND
REMOTE TRANSFORMERS

PURCHASED AND INSTALLED BY XC


2 SOUTH ELEVATION
SCALE: 1/4" = 1'-0"

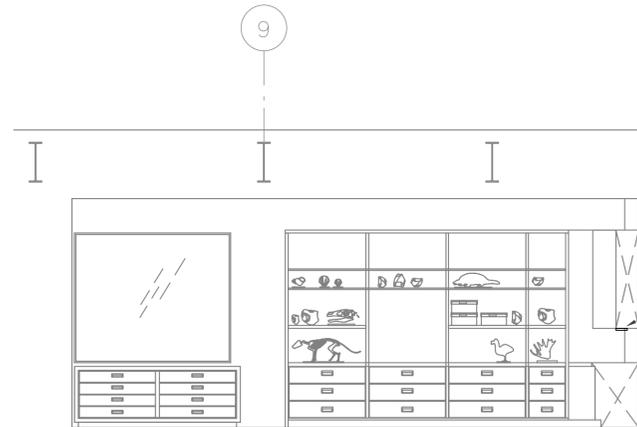

'NF-1' (NF-200)
SURFACE MOUNTED FLUORESCENT UNDER CABINET
LIGHT

PURCHASED AND INSTALLED BY GC

3 WEST ELEVATION
SCALE: 1/4" = 1'-0"

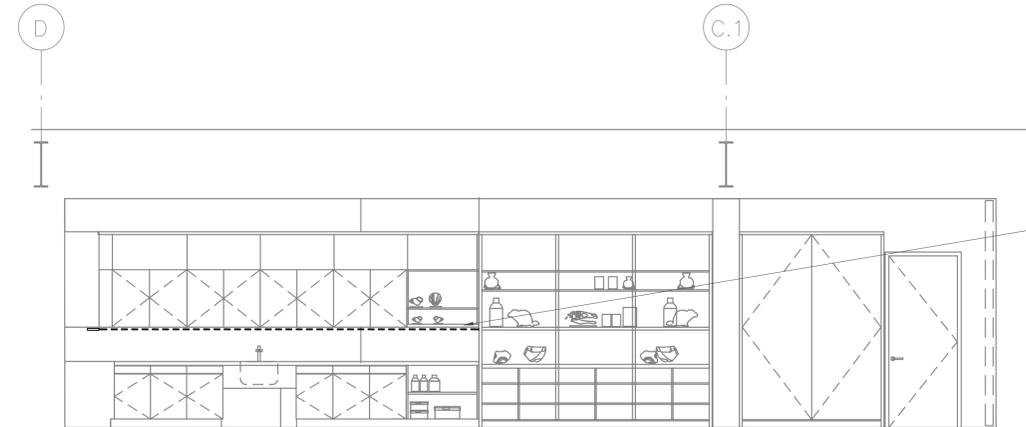

'NF-1' (NF-200)
SURFACE MOUNTED FLUORESCENT UNDER CABINET
LIGHT

PURCHASED AND INSTALLED BY GC


4 NORTH ELEVATION
SCALE: 1/4" = 1'-0"

UTAH MUSEUM OF NATURAL HISTORY

UNIVERSITY OF UTAH, SALT LAKE CITY, UTAH

Owner UMNH 1390 East President's Circle Salt Lake City, Utah 84112 801.581.6927 tel.	Design Architect Polshak Partnership Architects LLP 320 West 13th Street New York, New York 212.807.7171 tel.	Architect of Record Sofsky Brems Smith 375 West 200 South Salt Lake City, Utah 801.521.8600 tel.	Structural Engineer Leslie E. Robertson Associates 30 Broad Street New York, New York 10004 212.750.9000 tel.	Mechanical/Plumbing/Fire Protection Engineering Associates, Inc. 244 West 300 North Salt Lake City, Utah 84103 801.322.2400 tel.	Electrical/AV Engineer Spectrum Engineers 175 South Main Street Salt Lake City, Utah 84060 800.678.7077 tel.	Landscape Architect Design Workshop, Inc. 1796 Prospector Avenue Park City, Utah 84060 435.655.0915 tel.	Exhibition Planner and Graphic Designer Robert G. Baumbach Associates 88 Pine Street New York, New York 10005 212.334.8200 tel.	Lighting Designer Brandston Partnership Inc 122 West 26th Street New York, New York 10001 212.924.4050 tel.
--	---	---	---	--	--	--	--	---

Exhibit Construction

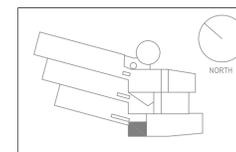

Key Plan

80% FD	Dec. 19, 2008
100% DD	June 2, 2008
XG 60% CD	May 5, 2008
WS9	March 26, 2008
WS8	Feb. 20, 2008
WS7	Dec. 18, 2007
50% DD	Sept. 18, 2007
WS6	July 11, 2007
WS5	May 23, 2007
WS4	April 12, 2007


No. / Issue Name / Date

No. / Issue Name / Date

Sheet Title
Level 2 Partial Plan:
Earth Lab

Date	Project No.
Dec. 19, 2008	0275
Scale*	Sheet No.
1/4"=1'-0"	LX2-EL-2.00

*Note: Scale Given for Full Size Drawing Sheet (22" x 34")

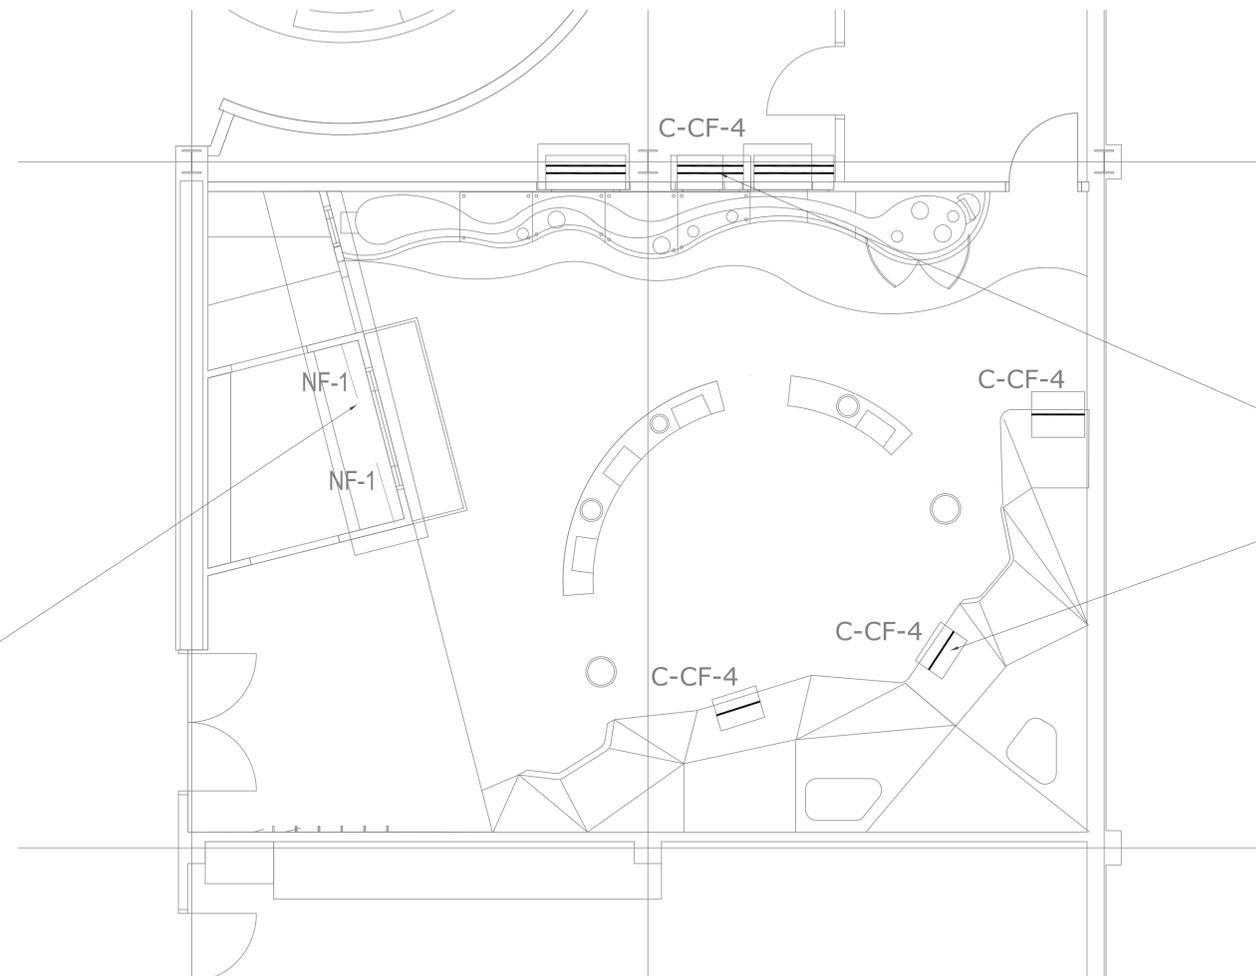

'NF-1' (NF-200)
 SURFACE MOUNTED FLUORESCENT UNDER CABINET LIGHT
 PURCHASED AND INSTALLED BY GC


'C-CF-4'
 FLUORESCENT CHANNELS MOUNTED WITHIN LIVE DISPLAY CASE
 PURCHASED AND INSTALLED BY XC

UTAH MUSEUM OF NATURAL HISTORY

UNIVERSITY OF UTAH, SALT LAKE CITY, UTAH

Owner UMNH 1390 East President's Circle Salt Lake City, Utah 84112 801.581.6927 tel.	Design Architect Polshak Partnership Architects LLP 320 West 13th Street New York, New York 212.807.7171 tel.	Architect of Record Sills/Sfransky Brems Smith 375 West 200 South Salt Lake City, Utah 801.521.8600 tel.	Structural Engineer Leslie E. Robertson Associates 30 Broad Street New York, New York 10004 212.750.9000 tel.	Mechanical/Plumbing/Fire Protection C/O H. E. Engineering Associates, Inc. 244 West 300 North Salt Lake City, Utah 84103 801.322.2400 tel.	Electrical/AV Engineer Spectrum Engineers 175 South Main Street Salt Lake City, Utah 84111 800.678.7077 tel.	Landscape Architect Design Workshop, Inc. 1796 Prospector Avenue Park City, Utah 84060 435.655.0915 tel.	Exhibition Planner and Ralph R. Gifford Associates 88 Pine Street New York, New York 10005 212.334.8200 tel.	Lighting Designer Brandston Partnership Inc 122 West 26th Street New York, New York 10001 212.924.4050 tel.
---	--	---	--	---	---	---	---	--

Exhibit Construction

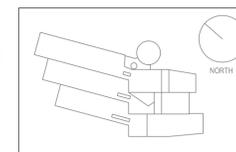

Key Plan

80% FD	Dec. 19, 2008
100% DD	June 2, 2008
XG 60% CD	May 5, 2008
WS9	March 26, 2008
WS8	Feb. 20, 2008
WS7	Dec. 18, 2007
50% DD	Sept. 18, 2007
WS6	July 11, 2007
WS5	May 23, 2007
WS4	April 12, 2007

No. / Issue Name / Date

No. / Issue Name / Date

Sheet Title
Level 2 Partial Plan:
'Our Backyard'/Children's Gallery


Date
 Dec. 19, 2008

Scale*
 1/4"=1'-0"

Project No.
 0275

Sheet No.
LX2-BY-1.00

*Note: Scale Given for Full Size Drawing Sheet (22" x 34")

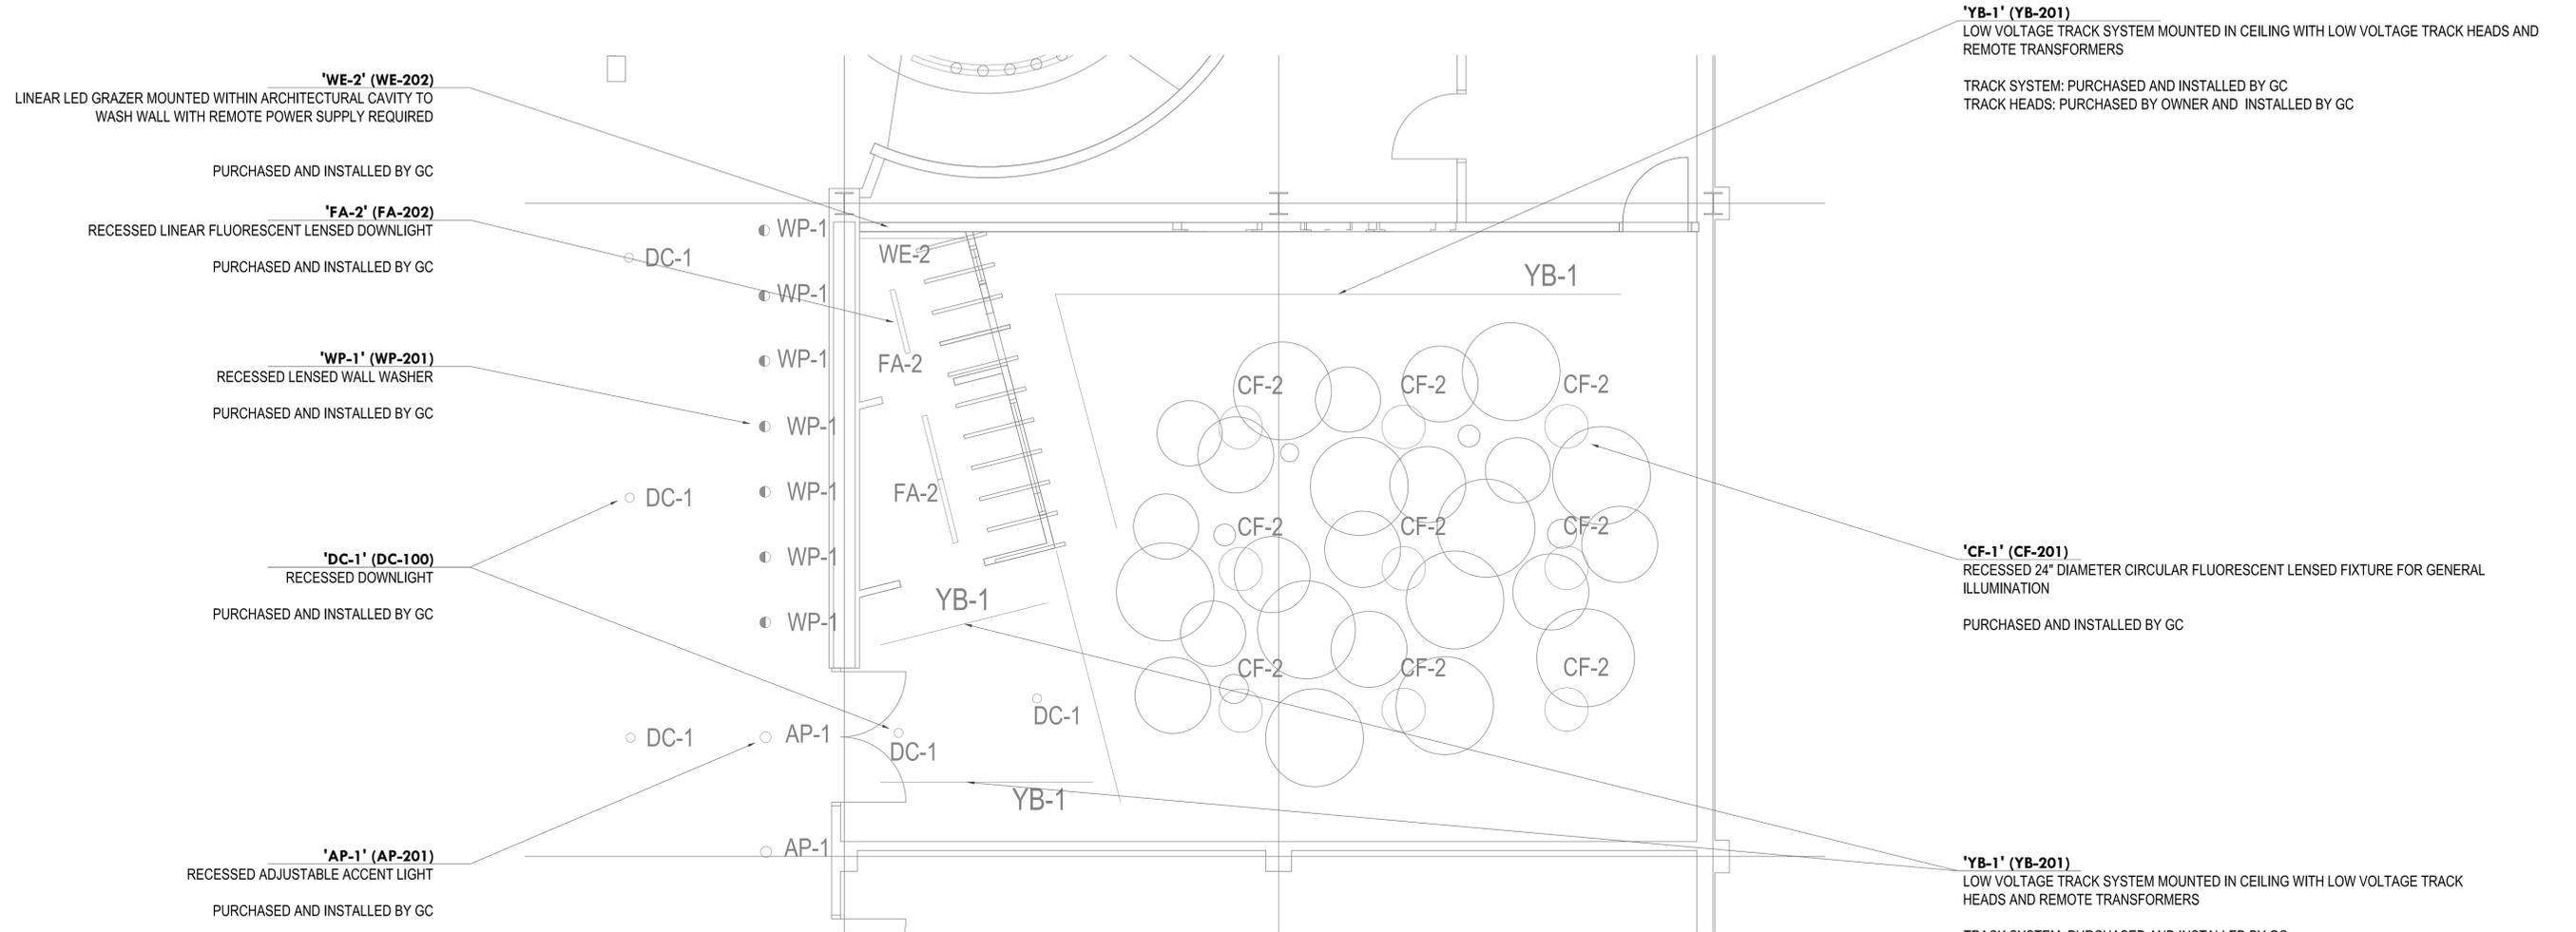

'WE-2' (WE-202)
LINEAR LED GRAZER MOUNTED WITHIN ARCHITECTURAL CAVITY TO WASH WALL WITH REMOTE POWER SUPPLY REQUIRED

PURCHASED AND INSTALLED BY GC

'FA-2' (FA-202)
RECESSED LINEAR FLUORESCENT LENSED DOWNLIGHT

PURCHASED AND INSTALLED BY GC

'WP-1' (WP-201)
RECESSED LENSED WALL WASHER

PURCHASED AND INSTALLED BY GC

'DC-1' (DC-100)
RECESSED DOWNLIGHT

PURCHASED AND INSTALLED BY GC

'AP-1' (AP-201)
RECESSED ADJUSTABLE ACCENT LIGHT

PURCHASED AND INSTALLED BY GC

'YB-1' (YB-201)
LOW VOLTAGE TRACK SYSTEM MOUNTED IN CEILING WITH LOW VOLTAGE TRACK HEADS AND REMOTE TRANSFORMERS

TRACK SYSTEM: PURCHASED AND INSTALLED BY GC
TRACK HEADS: PURCHASED BY OWNER AND INSTALLED BY GC

'CF-1' (CF-201)
RECESSED 24" DIAMETER CIRCULAR FLUORESCENT LENSED FIXTURE FOR GENERAL ILLUMINATION

PURCHASED AND INSTALLED BY GC

'YB-1' (YB-201)
LOW VOLTAGE TRACK SYSTEM MOUNTED IN CEILING WITH LOW VOLTAGE TRACK HEADS AND REMOTE TRANSFORMERS


TRACK SYSTEM: PURCHASED AND INSTALLED BY GC
TRACK HEADS: PURCHASED BY OWNER AND INSTALLED BY GC

UTAH MUSEUM OF NATURAL HISTORY

UNIVERSITY OF UTAH, SALT LAKE CITY, UTAH

Owner UMNH 1390 East President's Circle Salt Lake City, Utah 84112 801.581.6927 tel.	Design Architect Polshak Partnership Architects LLP 320 West 13th Street New York, New York 212.807.7171 tel.	Architect of Record Stefansky Brems Smith 375 West 200 South Salt Lake City, Utah 801.521.8600 tel.	Structural Engineer Leslie E. Robertson Associates 30 Broad Street New York, New York 10004 212.750.9000 tel.	Mechanical/Plumbing/Fire Protection C&E Engineering Associates, Inc. 244 West 300 North Salt Lake City, Utah 84103 801.322.2400 tel.	Electrical/AV Engineer Spectrum Engineers 175 South Main Street Salt Lake City, Utah 84111 800.678.7077 tel.	Landscape Architect Design Workshop, Inc. 1796 Prospector Avenue Park City, Utah 84060 435.655.0915 tel.	Exhibition Planner and Ralph Rappaport Associates 88 Pine Street New York, New York 10005 212.334.8200 tel.	Lighting Designer Brandston Partnership Inc 122 West 26th Street New York, New York 10001 212.924.4050 tel.
---	--	--	--	---	---	---	--	--

Exhibit Construction

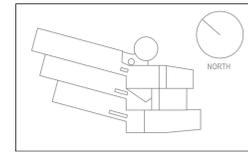

Key Plan





80% FD	Dec. 19, 2008
100% DD	June 2, 2008
XG 60% CD	May 5, 2008
WS9	March 26, 2008
WS8	Feb. 20, 2008
WS7	Dec. 18, 2007
50% DD	Sept. 18, 2007
WS6	July 11, 2007
WS5	May 23, 2007
WS4	April 12, 2007

No. / Issue Name / Date

No. / Issue Name / Date

Sheet Title	
Level 2 Partial RCP: 'Our Backyard'/Children's Gallery	
Date	Project No.
Dec. 19, 2008	0275
Scale*	Sheet No.
1/4"=1'-0"	LX2-BY-1.02

*Note: Scale Given for Full Size Drawing Sheet (22" x 34")

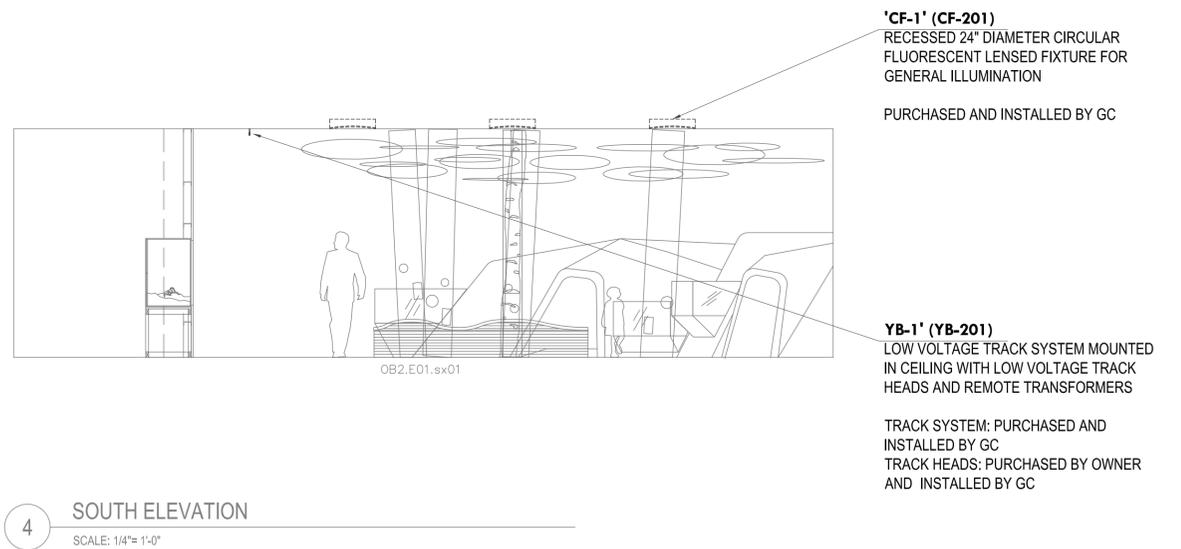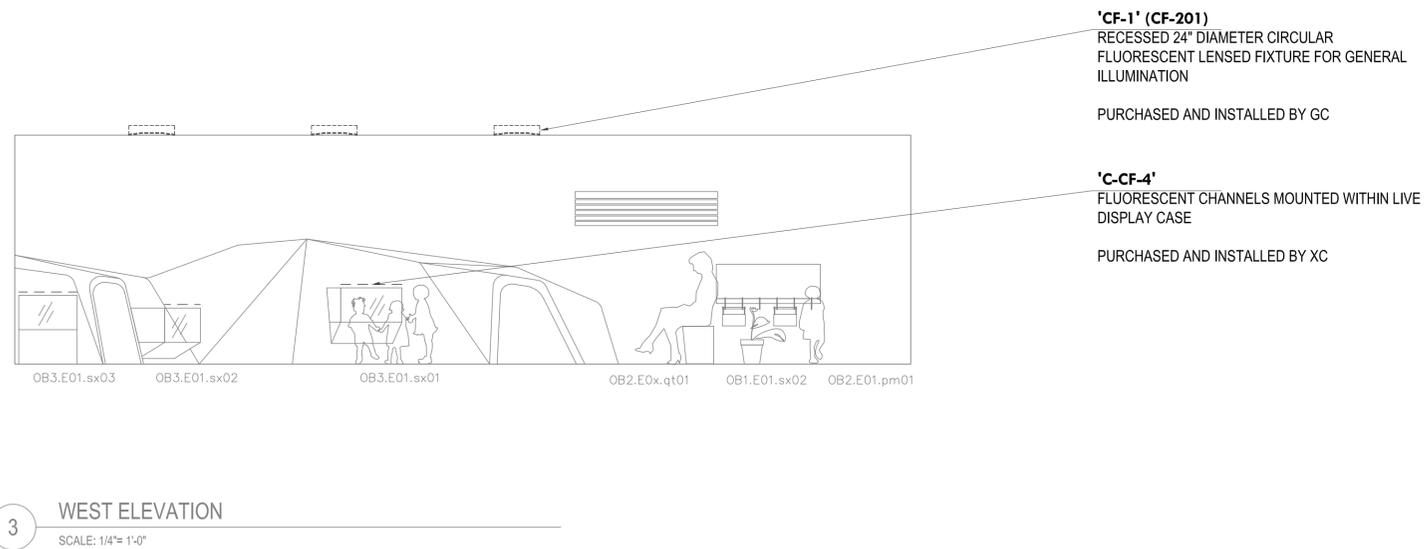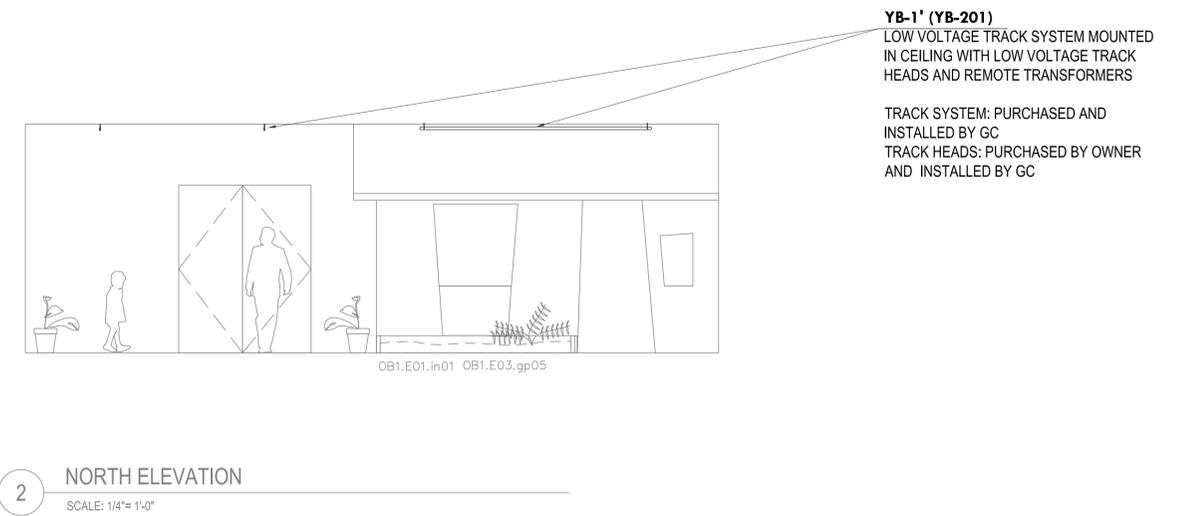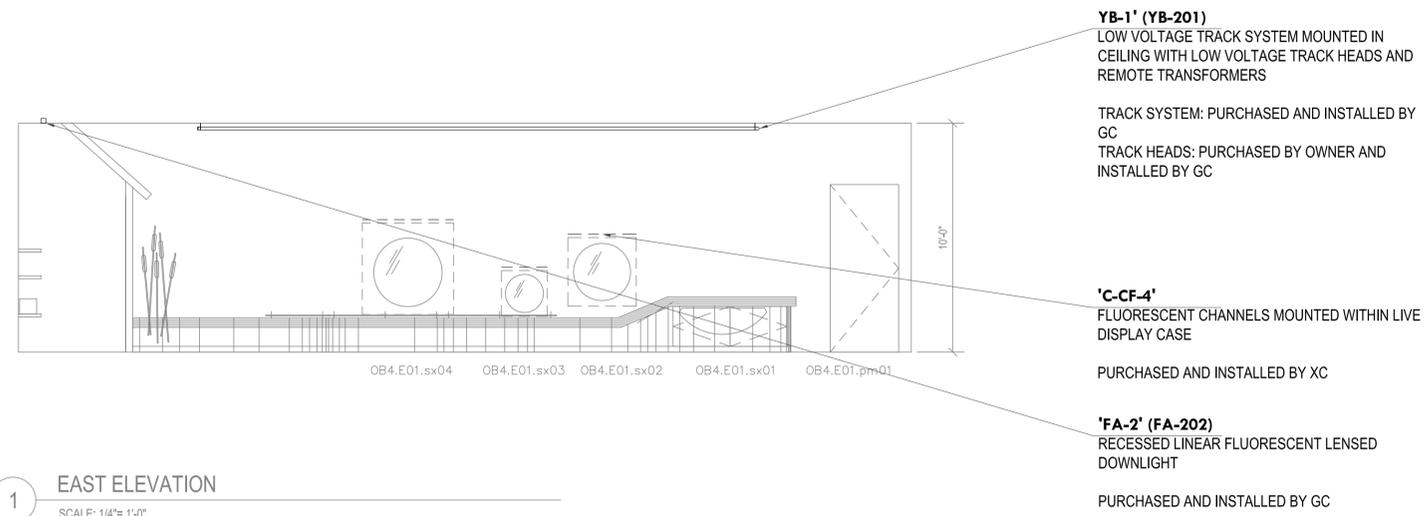


UTAH MUSEUM OF NATURAL HISTORY

UNIVERSITY OF UTAH, SALT LAKE CITY, UTAH

Owner UMNH 1390 East President's Circle Salt Lake City, Utah 84112 801.581.6927 tel.	Design Architect Polshak Partnership Architects LLP 320 West 13th Street New York, New York 212.807.7171 tel.	Architect of Record Siles Skansky Brems Smith 375 West 200 South Salt Lake City, Utah 801.521.8600 tel.	Structural Engineer Leslie E. Robertson Associates 30 Broad Street New York, New York 10004 212.750.9000 tel.	Mechanical/Plumbing/Fire Protection C&E Engineering Associates, Inc. 244 West 300 North Salt Lake City, Utah 84103 801.322.2400 tel.	Electrical/AV Engineer Spectrum Engineers 175 South Main Street Salt Lake City, Utah 84111 800.678.7077 tel.	Landscape Architect Design Workshop, Inc. 1796 Prospector Avenue Park City, Utah 84060 435.655.0915 tel.	Exhibition Planner and Ralph R. Gifford Associates 88 Pine Street New York, New York 10005 212.334.8200 tel.	Lighting Designer Brandston Partnership Inc 122 West 26th Street New York, New York 10001 212.924.4050 tel.
---	--	--	--	---	---	---	---	--

Exhibit Construction

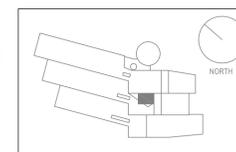

Key Plan

80% FD	Dec. 19, 2008
100% DD	June 2, 2008
XG 60% CD	May 5, 2008
WS9	March 26, 2008
WS8	Feb. 20, 2008
WS7	Dec. 18, 2007
50% DD	Sept. 18, 2007
WS6	July 11, 2007
WS5	May 23, 2007
WS4	April 12, 2007

No. / Issue Name / Date

No. / Issue Name / Date

Sheet Title
**Sections & Elevations:
'Our Backyard'/Children's Gallery**


Date
Dec. 19, 2008

Scale*
1/4"=1'-0"

Project No.
0275

Sheet No.
LX2-BY-2.00

*Note: Scale Given for Full Size Drawing Sheet (22" x 34")

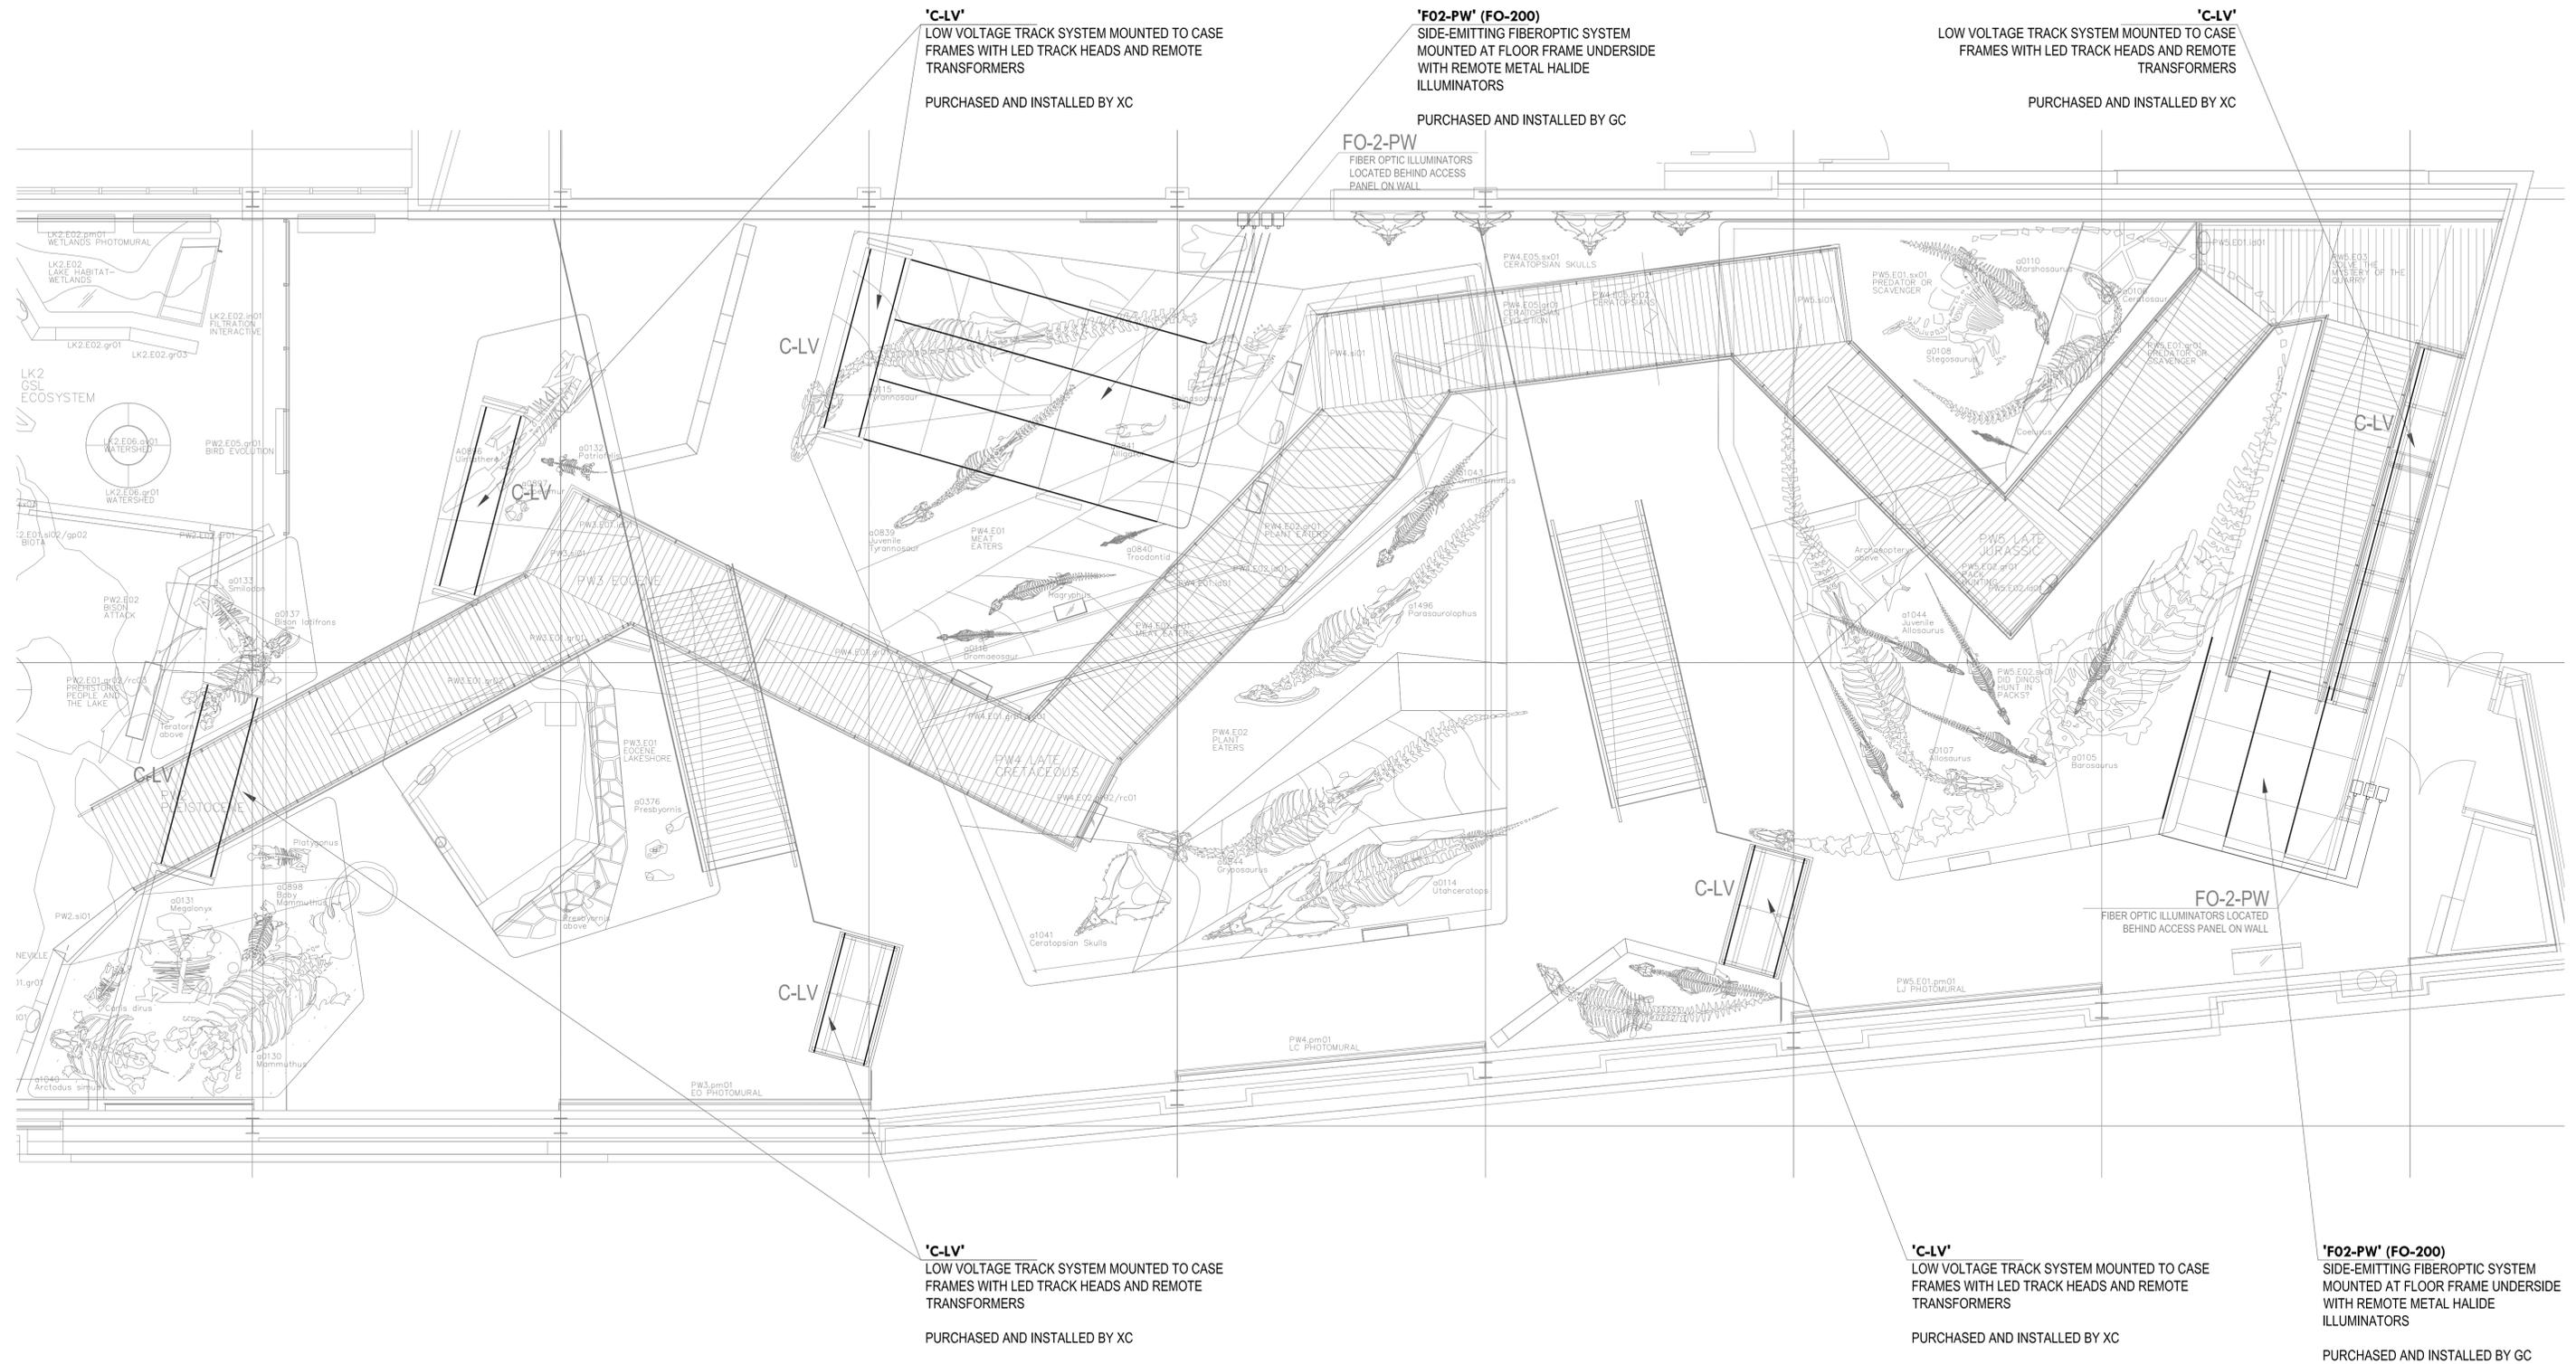


UTAH MUSEUM OF NATURAL HISTORY

UNIVERSITY OF UTAH, SALT LAKE CITY, UTAH

Owner UMNH 1390 East President's Circle Salt Lake City, Utah 84112 801.581.6927 tel.	Design Architect Polishek Partnership Architects LLP 320 West 13th Street New York, New York 212.807.7171 tel.	Architect of Record Giles Stransky Brems Smith 375 West 200 South Salt Lake City, Utah 801.521.8600 tel.	Structural Engineer Leslie E. Robertson Associates 30 Broad Street New York, New York 10004 212.750.9000 tel.	Mechanical/Plumbing/Fire Protection C&I Engineering Associates, Inc. 244 West 300 North Salt Lake City, Utah 84103 801.322.2400 tel.	Electrical/AV Engineer Spectrum Engineers 175 South Main Street Salt Lake City, Utah 84111 800.678.7077 tel.	Landscape Architect Design Workshop, Inc. 1796 Prospector Avenue Park City, Utah 84060 435.655.0915 tel.	Exhibition Planner and Ralph R. Baumbach Associates 88 Pine Street New York, New York 10005 212.334.8200 tel.	Lighting Designer Brandston Partnership Inc 122 West 26th Street New York, New York 10001 212.924.4050 tel.
--	--	--	---	--	--	--	---	---

Exhibit Construction

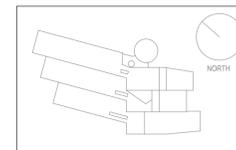

Key Plan

80% FD	Dec. 19, 2008
100% DD	June 2, 2008
XG 60% CD	May 5, 2008
WS9	March 26, 2008
WS8	Feb. 20, 2008
WS7	Dec. 18, 2007
50% DD	Sept. 18, 2007
WS6	July 11, 2007
WS5	May 23, 2007
WS4	April 12, 2007

No. / Issue Name / Date

No. / Issue Name / Date

Sheet Title
Level 2 Partial Plan:
Past Worlds Observatory


Date
Dec. 19, 2008

Scale*
1/8"=1'-0"

Project No.
0275

Sheet No.
LX2-PW-1.00

*Note: Scale Given for Full Size Drawing Sheet (22" x 34")

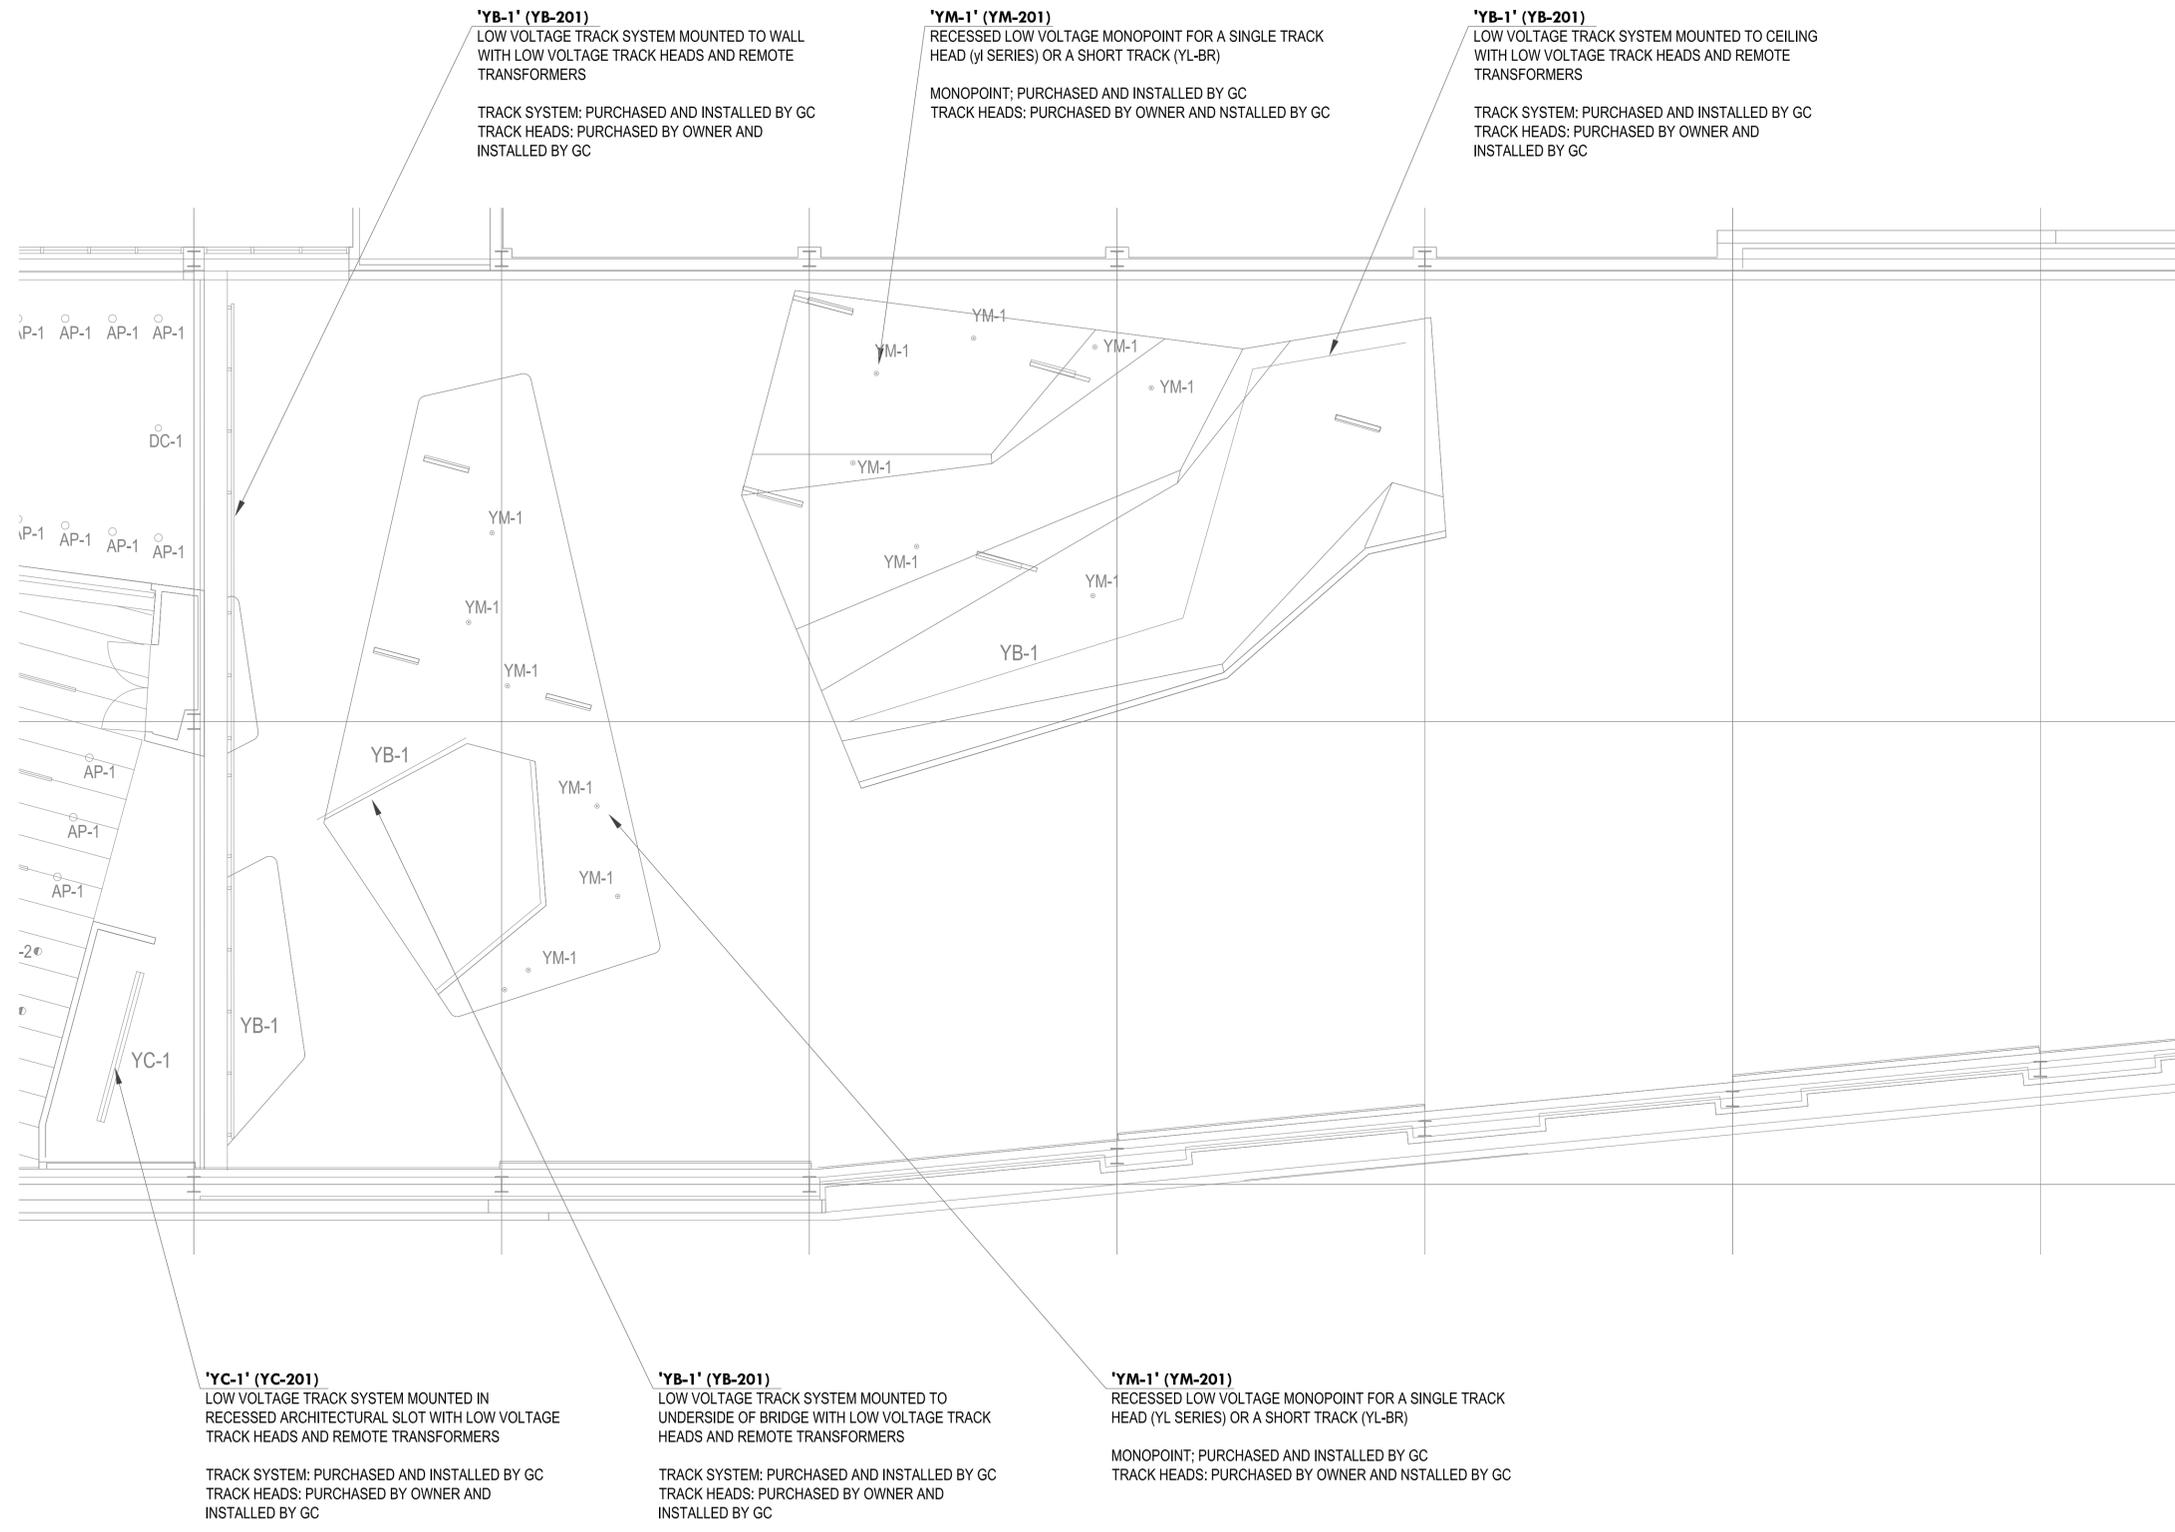


UTAH MUSEUM OF NATURAL HISTORY

UNIVERSITY OF UTAH, SALT LAKE CITY, UTAH

Owner UMNH 1390 East President's Circle Salt Lake City, Utah 84112 801.581.6927 tel.	Design Architect Polshek Partnership Architects LLP 320 West 13th Street New York, New York 212.607.7171 tel.	Architect of Record Gillies Stransky Brems Smith 375 West 200 South Salt Lake City, Utah 801.521.8600 tel.	Structural Engineer Leslie E. Robertson Associates 30 Broad Street New York, New York 10004 212.750.9000 tel.	Mechanical/Plumbing/Fire Protection Cowan Engineering Associates, Inc. 244 West 300 North Salt Lake City, Utah 84103 801.322.2400 tel.	Electrical/AV Engineer Spectrum Engineers 175 South Main Street Salt Lake City, Utah 84111 800.678.7077 tel.	Landscape Architect Design Workshop, Inc. 1796 Prospector Avenue Park City, Utah 84060 435.655.0915 tel.	Exhibition Planner and Ralph Appelbaum Associates 88 Pine Street New York, New York 10005 212.334.6200 tel.	Lighting Designer Brandston Partnership Inc 122 West 26th Street New York, New York 10001 212.924.4050 tel.
---	--	---	--	---	---	---	--	--

Exhibit Construction

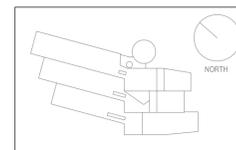

Key Plan

80% FD	Dec. 19, 2008
100% DD	June 2, 2008
XG 60% CD	May 5, 2008
WS9	March 26, 2008
WS8	Feb. 20, 2008
WS7	Dec. 18, 2007
50% DD	Sept. 18, 2007
WS6	July 11, 2007
WS5	May 23, 2007
WS4	April 12, 2007

No. / Issue Name / Date

No. / Issue Name / Date

Sheet Title	
Level 2 Partial RCP:	
Past Worlds Observatory	
Date	Project No.
Dec. 19, 2008	0275
Scale*	Sheet No.
1/8"=1'-0"	LX2-PW-1.02

*Note: Scale Given for Full Size Drawing Sheet (22" x 34")



'YP-BR' (YP-202)
 NOMINAL 10' LONG BRIDGE TRACK MOUNTED WHERE
 REQUIRED
 PURCHASED AND INSTALLED BY GC

'YP2-EM' (YP-203)
 15 INCH SEGMENTED TRACK WITH 100W HALOGEN
 FIXTURE FOR EMERGENCY LIGHTING. TRACK TO BE AT
 THE END OR IN LINE WITH YP-2 TRACK AND MOUNTED
 ON UNI-STRUT
 PURCHASED AND INSTALLED BY GC

'YP2-WK' (YP-204)
 15 INCH SEGMENT TRACK WITH 150W MH FIXTURE FOR
 WORK LIGHT. TRACK TO BE AT THE END OR IN LINE
 WITH YP-2 TRACK AND MOUNTED ON UNI-STRUT
 PURCHASED AND INSTALLED BY GC


'YP-2' (YP-201)
 SINGLE CIRCUIT TRACKS MOUNTED ON CONTINUOUS
 UNI-STRUT
 PURCHASED AND INSTALLED BY GC

UTAH MUSEUM OF NATURAL HISTORY

UNIVERSITY OF UTAH, SALT LAKE CITY, UTAH

Owner UMNH 1300 East President's Circle Salt Lake City, Utah 84112 801.581.6927 tel.	Design Architect Polshak Partnership Architects LLP 320 West 13th Street New York, New York 212.807.7171 tel.	Architect of Record Sfransky Brems Smith 375 West 200 South Salt Lake City, Utah 801.521.8600 tel.	Structural Engineer Leslie E. Robertson Associates 30 Broad Street New York, New York 10004 212.750.9000 tel.	Mechanical/Plumbing/Fire Protection Engineer Cajigas Engineering Associates, Inc. 244 West 300 North Salt Lake City, Utah 84103 801.322.2400 tel.	Electrical/AV Engineer Spectrum Engineers 175 South Main Street Salt Lake City, Utah 84111 800.678.7077 tel.	Landscape Architect Design Workshop, Inc. 1706 Prospector Avenue Park City, Utah 84060 435.655.0915 tel.	Exhibition Planner and Designer Rabin & Rabin Associates 88 Pine Street New York, New York 10005 212.334.8200 tel.	Lighting Designer Brandston Partnership Inc 122 West 26th Street New York, New York 10001 212.924.4050 tel.
---	--	---	--	--	---	---	---	--

Exhibit Construction

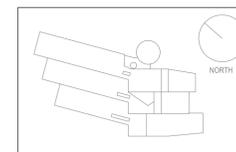

Key Plan

80% FD	Dec. 19, 2008
100% DD	June 2, 2008
XG 60% CD	May 5, 2008
WS9	March 26, 2008
WS8	Feb. 20, 2008
WS7	Dec. 18, 2007
50% DD	Sept. 18, 2007
WS6	July 11, 2007
WS5	May 23, 2007
WS4	April 12, 2007


No. / Issue Name / Date

No. / Issue Name / Date

Sheet Title
**Level 3 Partial RCP:
 Lake Observatory**

Date Dec. 19, 2008	Project No. 0275
Scale* 1/4"=1'-0"	Sheet No. LX3-LK-1.02

*Note: Scale Given for Full Size Drawing Sheet (22" x 34")

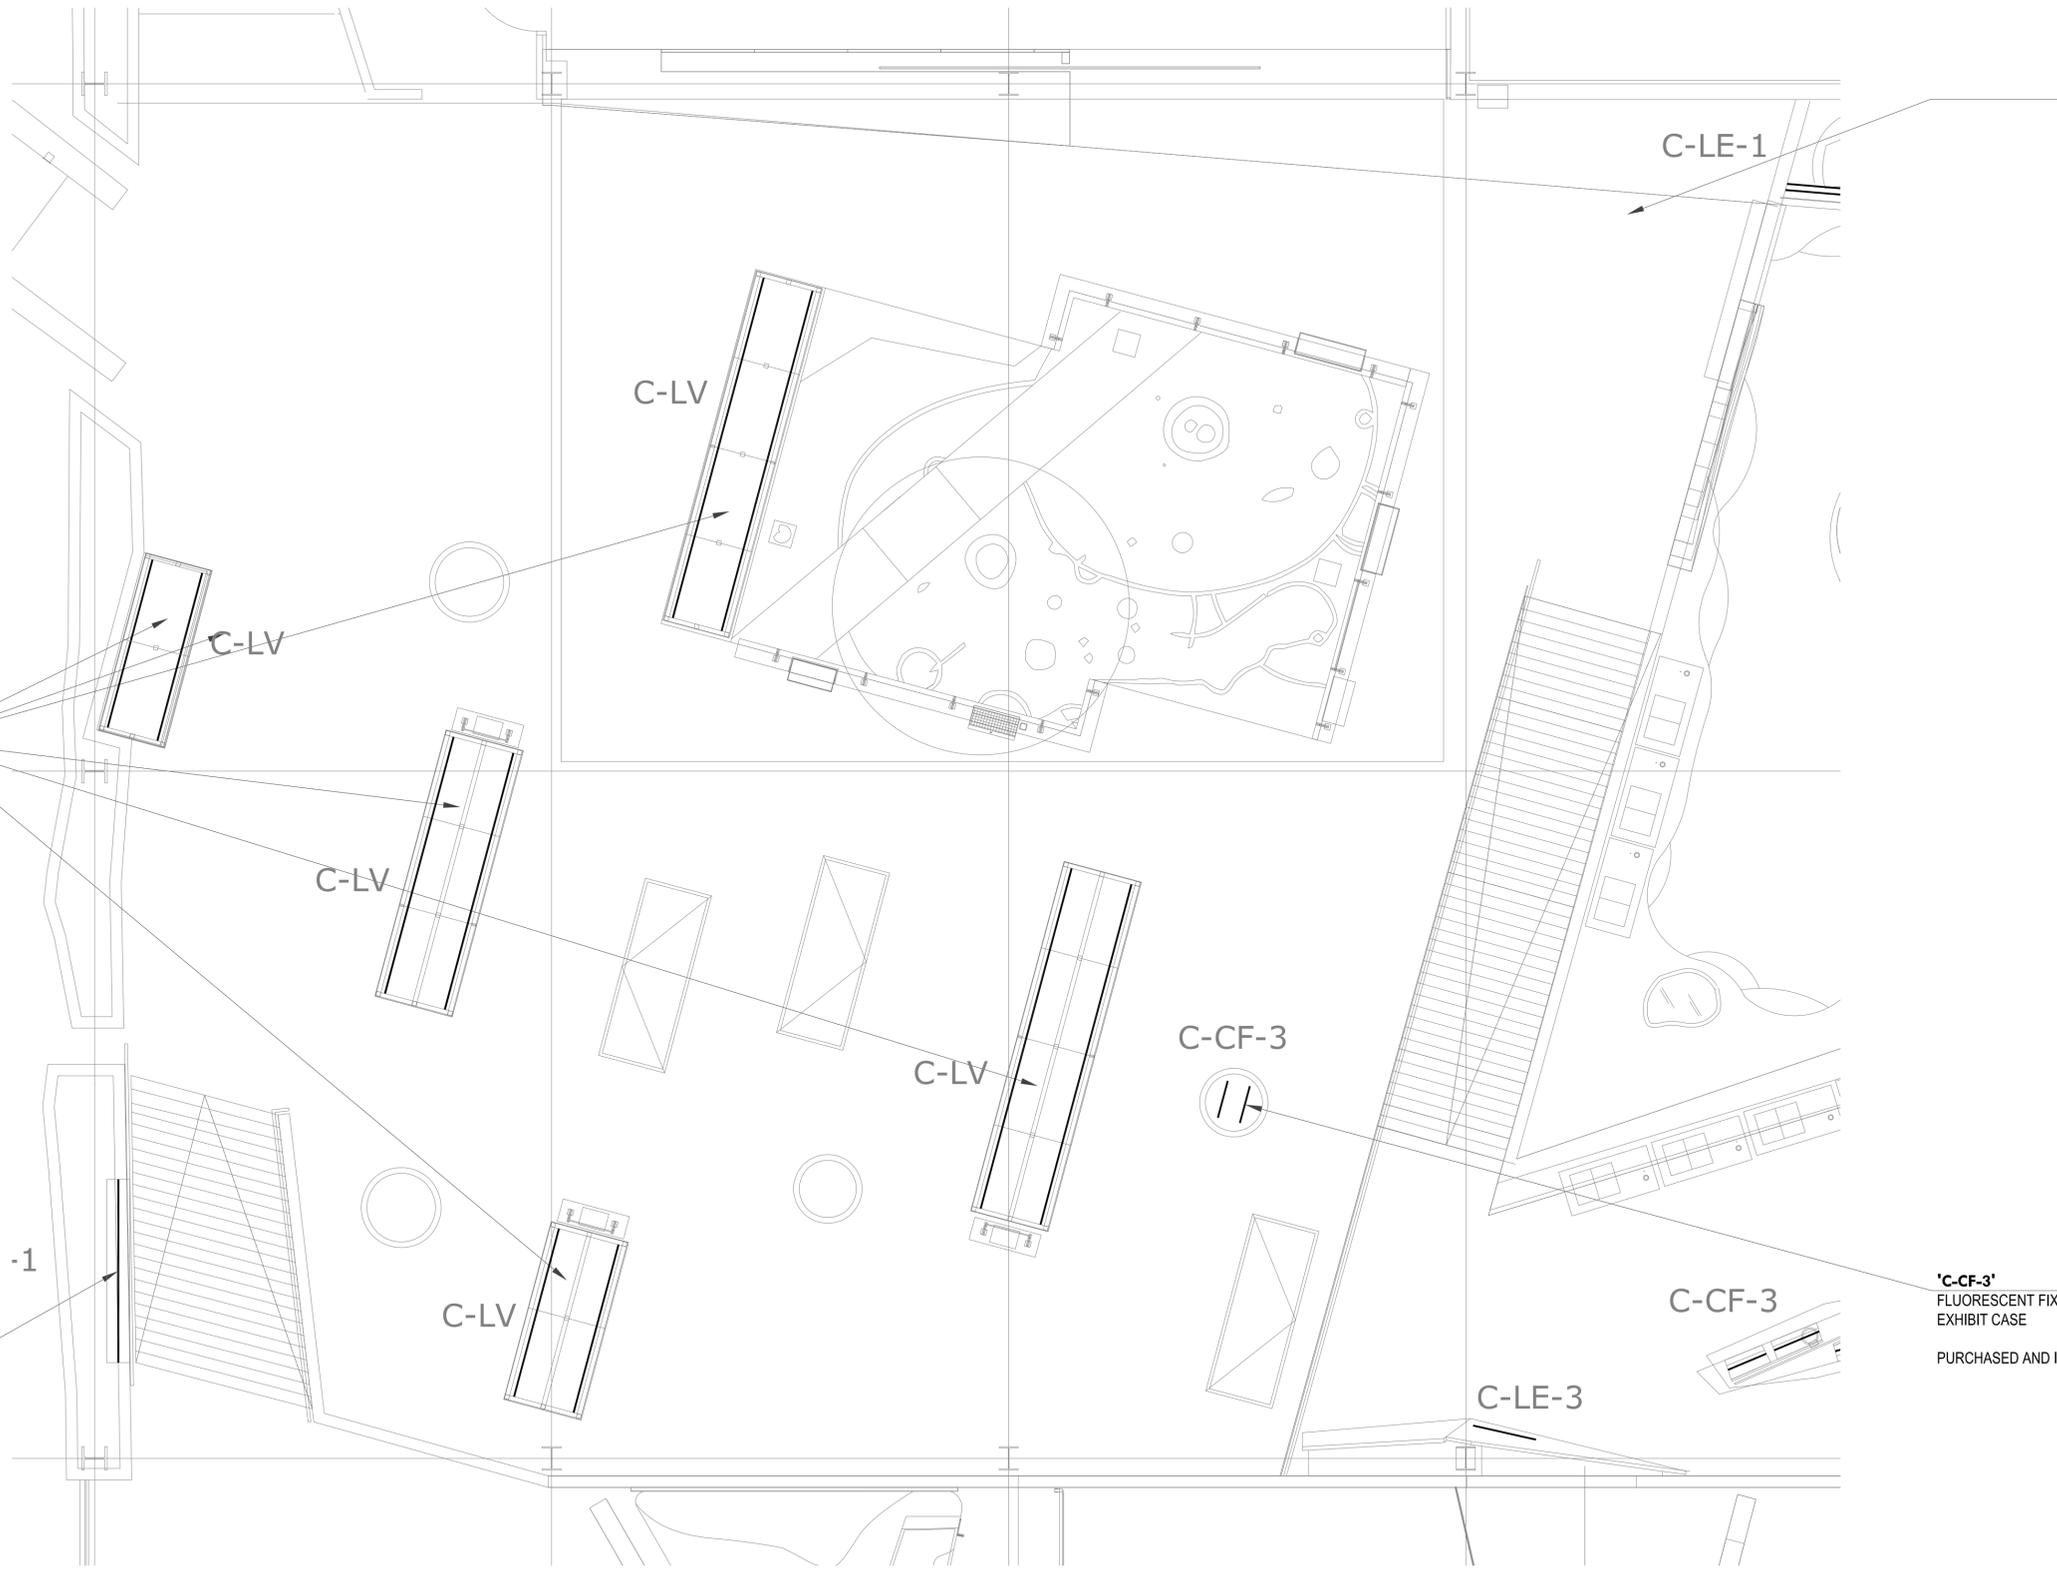

'C-LV'
 LOW VOLTAGE TRACK SYSTEM MOUNTED TO
 CASE FRAMES WITH LED TRACK HEADS AND
 REMOTE TRANSFORMERS
 PURCHASED AND INSTALLED BY XC

'C-LE-1'
 LINEAR LED FIXTURE MOUNTED IN INSET CASE WITH
 REMOTE POWER SUPPLY REQUIRED.
 PURCHASED AND INSTALLED BY XC


'C-CF-3'
 FLUORESCENT FIXTURE MOUNTED WITHIN TABLE
 EXHIBIT CASE
 PURCHASED AND INSTALLED BY XC

UTAH MUSEUM OF NATURAL HISTORY

UNIVERSITY OF UTAH, SALT LAKE CITY, UTAH

Exhibit Construction

Owner UMNH 1300 East President's Circle Salt Lake City, Utah 84112 801.581.6927 tel.	Design Architect Polshak Partnership Architects LLP 320 West 13th Street New York, New York 212.807.7171 tel.	Architect of Record Giles Stransky Brans Smith 375 West 200 South Salt Lake City, Utah 801.521.8600 tel.	Structural Engineer Leslie E. Robertson Associates 30 Broad Street New York, New York 10004 212.750.9000 tel.	Mechanical/Plumbing/Fire Protection Engineer Coligni Engineering Associates, Inc. 244 West 300 North Salt Lake City, Utah 84103 801.322.2400 tel.	Electrical/AV Engineer Spectrum Engineers 175 South Main Street Salt Lake City, Utah 84101 800.678.7077 tel.	Landscape Architect Design Workshop, Inc. 1706 Prospector Avenue Park City, Utah 84060 435.655.0915 tel.	Exhibition Planner and Designer Rabin Rabinbaum Associates 88 Pine Street New York, New York 10005 212.334.8200 tel.	Lighting Designer Brandston Partnership Inc 122 West 26th Street New York, New York 10001 212.924.4050 tel.
---	--	---	--	--	---	---	---	--

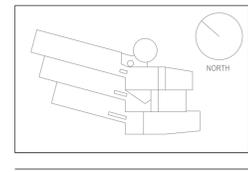

Key Plan

80% FD	Dec. 19, 2008
100% DD	June 2, 2008
XG 60% CD	May 5, 2008
WS9	March 26, 2008
WS8	Feb. 20, 2008
WS7	Dec. 18, 2007
50% DD	Sept. 18, 2007
WS6	July 11, 2007
WS5	May 23, 2007
WS4	April 12, 2007

No. / Issue Name / Date

No. / Issue Name / Date

Sheet Title
 Level 3 Partial Plan:
 First Peoples Observatory

Date
 Dec. 19, 2008
 Scale*
 1/4"=1'-0"

Project No.
 0275
 Sheet No.
 LX3-FP-1.00

*Note: Scale Given for Full Size Drawing Sheet (22" x 34")



'YP-3B' (YP-302)
SPECIAL EFFECT GOBO PROJECTOR C-CLAMP
MOUNTED TO IRON PIPE AND PERMANENTLY WIRED
PURCHASED AND INSTALLED BY GC

'YP2-EM' (YP-203)
15 INCH SEGMENTED TRACK WITH 100W HALOGEN
FIXTURE FOR EMERGENCY LIGHTING. TRACK TO BE AT
THE END OR IN LINE WITH YP-2 TRACK AND MOUNTED
ON UNI-STRUT
PURCHASED AND INSTALLED BY GC

'YP2-WK' (YP-204)
15 INCH SEGMENT TRACK WITH 150W MH FIXTURE FOR
WORK LIGHT. TRACK TO BE AT THE END OR IN LINE
WITH YP-2 TRACK AND MOUNTED ON UNI-STRUT
PURCHASED AND INSTALLED BY GC

'YP-2' (YP-201)
SINGLE CIRCUIT TRACKS MOUNTED ON CONTINUOUS
UNI-STRUT
PURCHASED AND INSTALLED BY GC


'YP-BR' (YP-202)
NOMINAL 10' LONG BRIDGE TRACK MOUNTED WHERE
REQUIRED
PURCHASED AND INSTALLED BY GC

UTAH MUSEUM OF NATURAL HISTORY

UNIVERSITY OF UTAH, SALT LAKE CITY, UTAH

Owner UMNH 1300 East President's Circle Salt Lake City, Utah 84112 801.581.6927 tel.	Design Architect Polshak Partnership Architects LLP 320 West 13th Street New York, New York 212.807.7171 tel.	Architect of Record Giles Stransky Brans Smith 375 West 200 South Salt Lake City, Utah 801.521.8600 tel.	Structural Engineer Leslie E. Robertson Associates 30 Broad Street New York, New York 10004 212.750.9000 tel.	Mechanical/Plumbing/Fire Protection Engineer Cajigas Engineering Associates, Inc. 244 West 300 North Salt Lake City, Utah 84103 801.322.2400 tel.	Electrical/AV Engineer Spectrum Engineers 175 South Main Street Salt Lake City, Utah 84111 800.678.7077 tel.	Landscape Architect Design Workshop, Inc. 1796 Prospector Avenue Park City, Utah 84060 435.655.0915 tel.	Exhibition Planner and Designer Rabin Rabinbaum Associates 88 Pine Street New York, New York 10005 212.334.8200 tel.	Lighting Designer Brandston Partnership Inc 122 West 26th Street New York, New York 10001 212.924.4050 tel.
---	--	---	--	--	---	---	---	--

Exhibit Construction

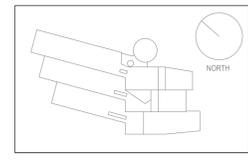

Key Plan

80% FD	Dec. 19, 2008
100% DD	June 2, 2008
XG 60% CD	May 5, 2008
WS9	March 26, 2008
WS8	Feb. 20, 2008
WS7	Dec. 18, 2007
50% DD	Sept. 18, 2007
WS6	July 11, 2007
WS5	May 23, 2007
WS4	April 12, 2007

No. / Issue Name / Date

No. / Issue Name / Date

Sheet Title
Level 3 Partial RCP:
First Peoples Observatory



Date
Dec. 19, 2008

Project No.
0275

Scale*
1/4"=1'-0"

Sheet No.
LX3-FP-1.02

*Note: Scale Given for Full Size Drawing Sheet (22" x 34")

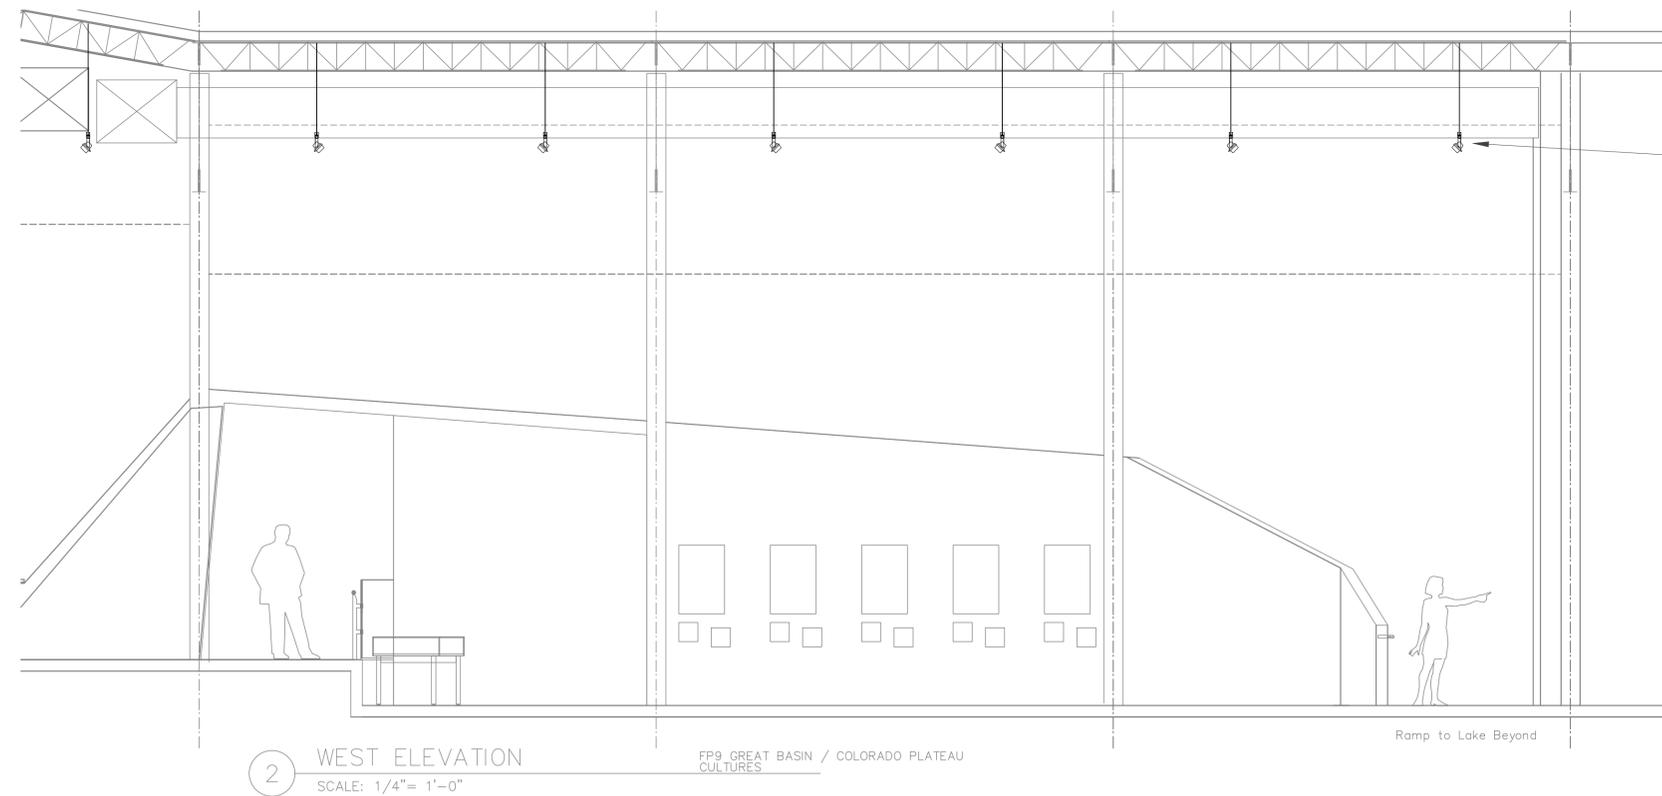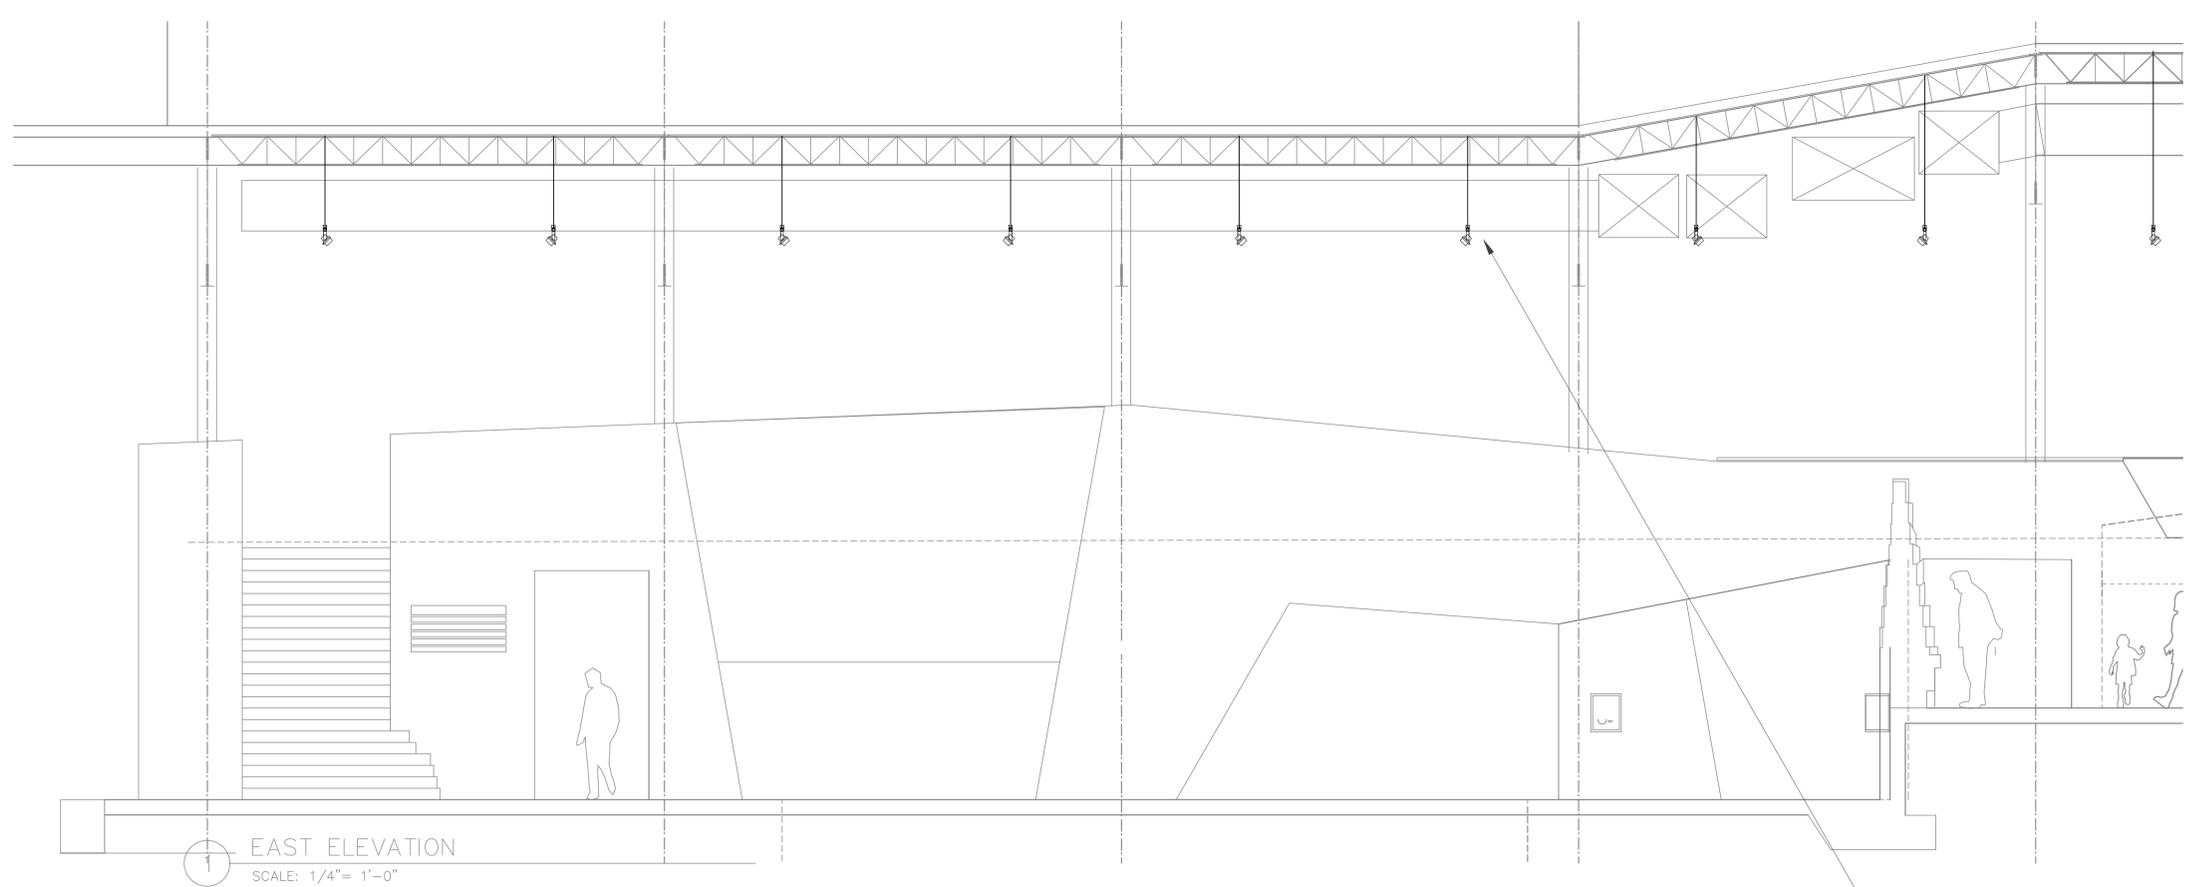

'YP-2' (YP-201)
SINGLE CIRCUIT TRACKS MOUNTED ON CONTINUOUS UNI-STRUT
PURCHASED AND INSTALLED BY GC

'YP2-EM' (YP-203)
15 INCH SEGMENTED TRACK WITH 100W HALOGEN FIXTURE FOR EMERGENCY LIGHTING. TRACK TO BE AT THE END OR IN LINE WITH YP-2 TRACK AND MOUNTED ON UNI-STRUT
PURCHASED AND INSTALLED BY GC


'YP2-WK' (YP-204)
15 INCH SEGMENT TRACK WITH 150W MH FIXTURE FOR WORK LIGHT. TRACK TO BE AT THE END OR IN LINE WITH YP-2 TRACK AND MOUNTED ON UNI-STRUT
PURCHASED AND INSTALLED BY GC

UTAH MUSEUM OF NATURAL HISTORY

UNIVERSITY OF UTAH, SALT LAKE CITY, UTAH

Exhibit Construction

Owner UMNH 1300 East President's Circle Salt Lake City, Utah 84112 801.581.6927 tel.	Design Architect Polshak Partnership Architects LLP 320 West 13th Street New York, New York 212.807.7171 tel.	Architect of Record Stefanovsky Brans Smith 375 West 200 South Salt Lake City, Utah 801.521.8600 tel.	Structural Engineer Leslie E. Robertson Associates 30 Broad Street New York, New York 10004 212.750.9000 tel.	Mechanical/Plumbing/Fire Protection Egghart Engineering Associates, Inc. 244 West 300 North Salt Lake City, Utah 84103 801.322.2400 tel.	Electrical/AV Engineer Spectrum Engineers 175 South Main Street Salt Lake City, Utah 84111 800.678.7077 tel.	Landscape Architect Design Workshop, Inc. 1796 Prospector Avenue Park City, Utah 84060 435.655.0915 tel.	Exhibition Planner and Brandenburg Associates 88 Pine Street New York, New York 10005 212.334.8200 tel.	Lighting Designer Brandston Partnership Inc 122 West 26th Street New York, New York 10001 212.924.4050 tel.
--	---	---	---	--	--	--	---	---

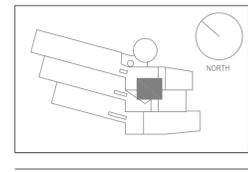

Key Plan

80% FD	Dec. 19, 2008
100% DD	June 2, 2008
XG 60% CD	May 5, 2008
WS9	March 26, 2008
WS8	Feb. 20, 2008
WS7	Dec. 18, 2007
50% DD	Sept. 18, 2007
WS6	July 11, 2007
WS5	May 23, 2007
WS4	April 12, 2007


No. / Issue Name / Date

No. / Issue Name / Date

Sheet Title
**Level 3 Sections & Elevations:
First Peoples Observatory**

Date	Project No.
Dec. 19, 2008	0275
Scale*	Sheet No.
1/4"=1'-0"	LX3-FP-2.00

*Note: Scale Given for Full Size Drawing Sheet (22" x 34")

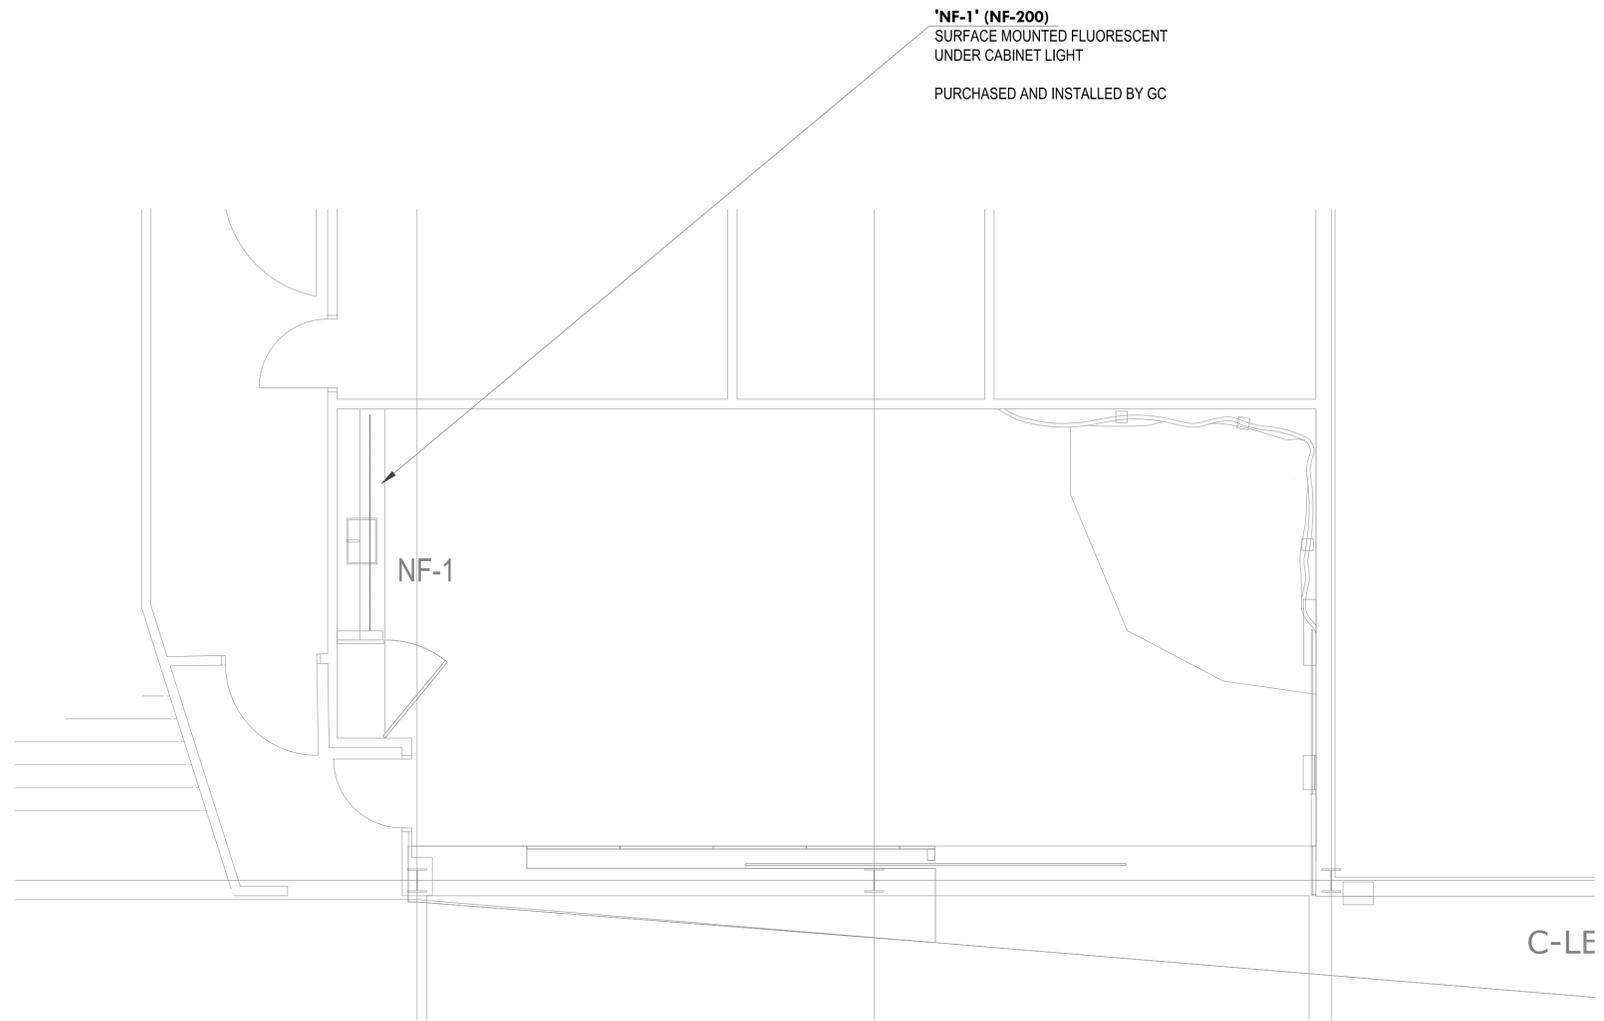


UTAH MUSEUM OF NATURAL HISTORY

UNIVERSITY OF UTAH, SALT LAKE CITY, UTAH

Owner UMNH 1300 East President's Circle Salt Lake City, Utah 84112 801.581.6927 tel.	Design Architect Polshak Partnership Architects LLP 320 West 13th Street New York, New York 212.807.7171 tel.	Architect of Record Giles Stransky Brems Smith 375 West 200 South Salt Lake City, Utah 801.521.8600 tel.	Structural Engineer Leslie E. Robertson Associates 30 Broad Street New York, New York 10004 212.750.9000 tel.	Mechanical/Plumbing/Fire Protection Cajigas Engineering Associates, Inc. 244 West 300 North Salt Lake City, Utah 84103 801.322.2400 tel.	Electrical/AV Engineer Spectrum Engineers 175 South Main Street Salt Lake City, Utah 84111 800.678.7077 tel.	Landscape Architect Design Workshop, Inc. 1796 Prospector Avenue Park City, Utah 84060 435.655.0915 tel.	Exhibition Planner and Rajesh Raju Associates 88 Pine Street New York, New York 10005 212.334.8200 tel.	Lighting Designer Brandston Partnership Inc 122 West 26th Street New York, New York 10001 212.924.4050 tel.
---	--	---	--	---	---	---	--	--

Exhibit Construction

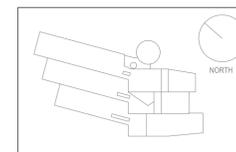

Key Plan

80% FD	Dec. 19, 2008
100% DD	June 2, 2008
XG 60% CD	May 5, 2008
WS9	March 26, 2008
WS8	Feb. 20, 2008
WS7	Dec. 18, 2007
50% DD	Sept. 18, 2007
WS6	July 11, 2007
WS5	May 23, 2007
WS4	April 12, 2007

No. / Issue Name / Date

No. / Issue Name / Date

Sheet Title
Level 3 Partial Plan:
Dry Cave


Date
Dec. 19, 2008

Scale*
1/4"=1'-0"

Project No.
0275

Sheet No.
LX3-DC-1.00

*Note: Scale Given for Full Size Drawing Sheet (22" x 34")

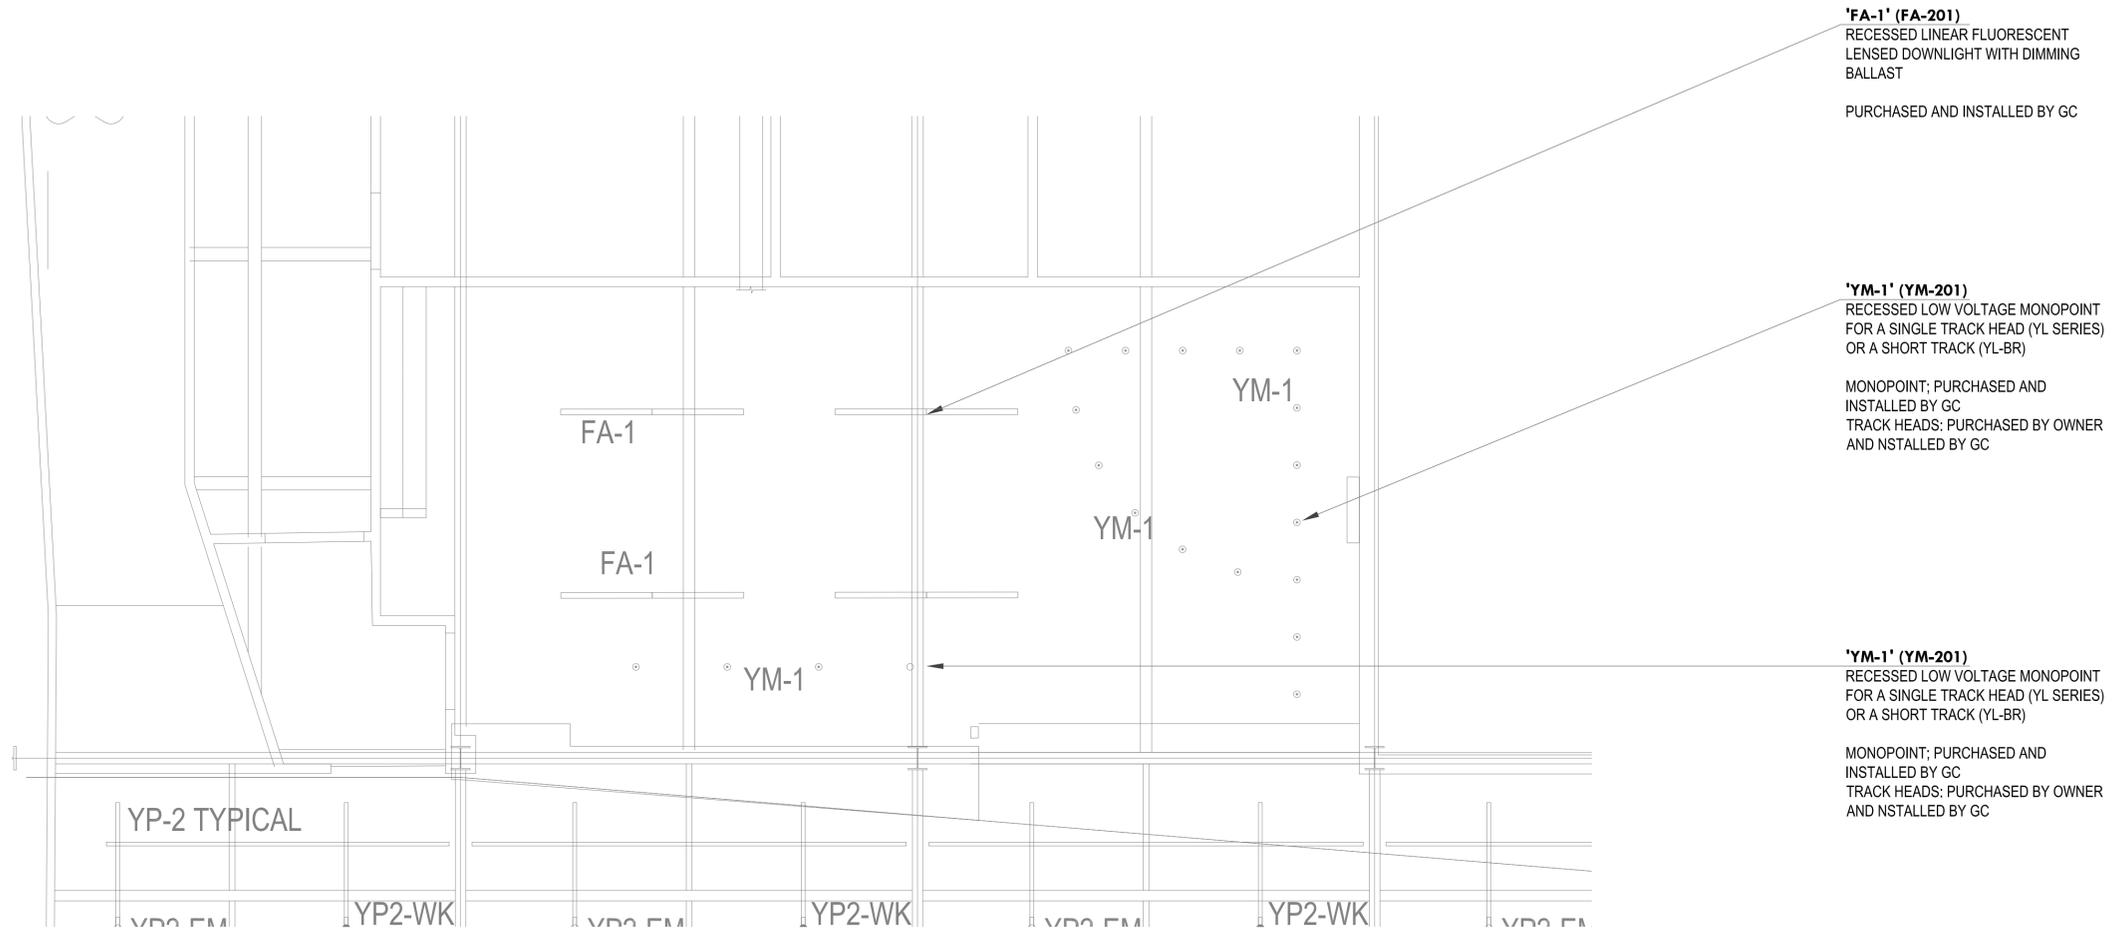

'FA-1' (FA-201)
 RECESSED LINEAR FLUORESCENT
 LENSED DOWNLIGHT WITH DIMMING
 BALLAST
 PURCHASED AND INSTALLED BY GC

'YM-1' (YM-201)
 RECESSED LOW VOLTAGE MONOPOINT
 FOR A SINGLE TRACK HEAD (YL SERIES)
 OR A SHORT TRACK (YL-BR)
 MONOPOINT; PURCHASED AND
 INSTALLED BY GC
 TRACK HEADS: PURCHASED BY OWNER
 AND NSTALLED BY GC


'YM-1' (YM-201)
 RECESSED LOW VOLTAGE MONOPOINT
 FOR A SINGLE TRACK HEAD (YL SERIES)
 OR A SHORT TRACK (YL-BR)
 MONOPOINT; PURCHASED AND
 INSTALLED BY GC
 TRACK HEADS: PURCHASED BY OWNER
 AND NSTALLED BY GC

UTAH MUSEUM OF NATURAL HISTORY

UNIVERSITY OF UTAH, SALT LAKE CITY, UTAH

Exhibit Construction

Owner UMNH 1300 East President's Circle Salt Lake City, Utah 84112 801.581.6927 tel.	Design Architect Polshak Partnership Architects LLP 320 West 13th Street New York, New York 212.807.7171 tel.	Architect of Record Giles Stransky Brems Smith 375 West 200 South Salt Lake City, Utah 801.521.8600 tel.	Structural Engineer Leslie E. Robertson Associates 30 Broad Street New York, New York 10004 212.750.9000 tel.	Mechanical/Plumbing/Fire Protection Cajigas Engineering Associates, Inc. 244 West 300 North Salt Lake City, Utah 84103 801.322.2400 tel.	Electrical/AV Engineer Spectrum Engineers 175 South Main Street Salt Lake City, Utah 84111 800.678.7077 tel.	Landscape Architect Design Workshop, Inc. 1796 Prospector Avenue Park City, Utah 84060 435.655.0915 tel.	Exhibition Planner and Rabin Rabinbaum Associates 88 Pine Street New York, New York 10005 212.334.8200 tel.	Lighting Designer Brandston Partnership Inc 122 West 26th Street New York, New York 10001 212.924.4050 tel.
---	--	---	--	---	---	---	--	--

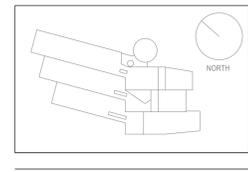

Key Plan


80% FD	Dec. 19, 2008
100% DD	June 2, 2008
XG 60% CD	May 5, 2008
WS9	March 26, 2008
WS8	Feb. 20, 2008
WS7	Dec. 18, 2007
50% DD	Sept. 18, 2007
WS6	July 11, 2007
WS5	May 23, 2007
WS4	April 12, 2007

No. / Issue Name / Date

No. / Issue Name / Date


Sheet Title Level 3 Partial RCP: Dry Cave	
Date Dec. 19, 2008	Project No. 0275
Scale* 1/4"=1'-0"	Sheet No. LX3-DC-1.02

*Note: Scale Given for Full Size Drawing Sheet (22" x 34")

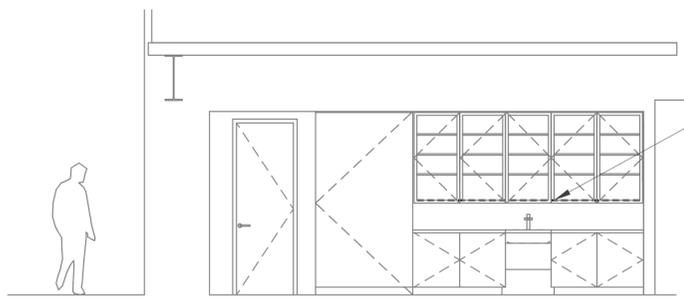


1 NORTH ELEVATION
SCALE: 1/4"= 1'-0"

'NF-1' (NF-200)
SURFACE MOUNTED FLUORESCENT
UNDER CABINET LIGHT
PURCHASED AND INSTALLED BY GC

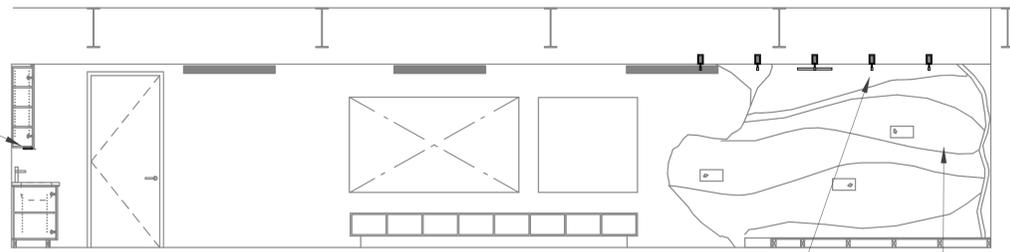


2 EAST ELEVATION
SCALE: 1/4"= 1'-0"

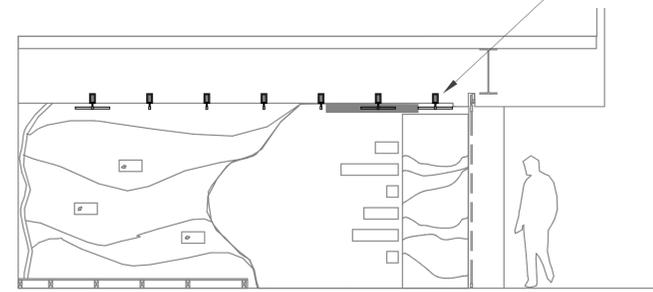

3 SOUTH ELEVATION
SCALE: 1/4"= 1'-0"

'YM-1' (YM-201)
RECESSED LOW VOLTAGE MONOPOINT FOR A SINGLE
TRACK HEAD (YI SERIES) OR A SHORT TRACK (YL-BR)
MONOPOINT; PURCHASED AND INSTALLED BY GC
TRACK HEADS: PURCHASED BY OWNER AND INSTALLED
BY GC

'YM-1' (YM-201)
RECESSED LOW VOLTAGE MONOPOINT FOR A SINGLE
TRACK HEAD (YI SERIES) OR A SHORT TRACK (YL-BR)
MONOPOINT; PURCHASED AND INSTALLED BY GC
TRACK HEADS: PURCHASED BY OWNER AND INSTALLED
BY GC

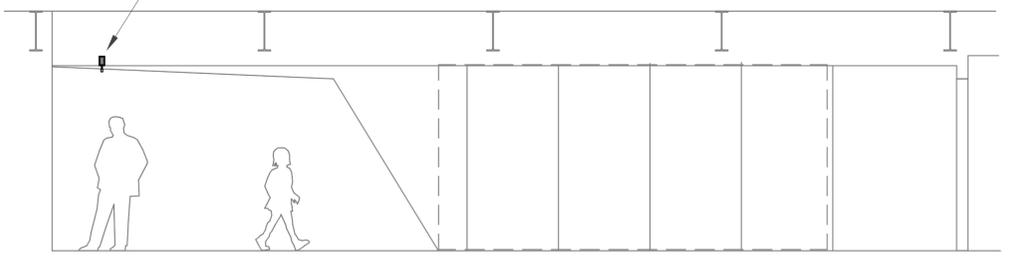


4 WEST ELEVATION
SCALE: 1/4"= 1'-0"

UTAH MUSEUM OF NATURAL HISTORY

UNIVERSITY OF UTAH, SALT LAKE CITY, UTAH

Owner UMNH 1300 East President's Circle Salt Lake City, Utah 84112 801.581.6927 tel.	Design Architect Polshak Partnership Architects LLP 320 West 13th Street New York, New York 212.807.7171 tel.	Architect of Record Sternberg Architects 375 West 200 South Salt Lake City, Utah 801.521.8600 tel.	Structural Engineer Leslie E. Robertson Associates 30 Broad Street New York, New York 10004 212.750.9000 tel.	Mechanical/Plumbing/Fire Protection Edgell Engineering Associates, Inc. 244 West 300 North Salt Lake City, Utah 84103 801.322.2400 tel.	Electrical/AV Engineer Spectrum Engineers 175 South Main Street Salt Lake City, Utah 84111 800.678.7077 tel.	Landscape Architect Design Workshop, Inc. 1796 Prospector Avenue Park City, Utah 84060 435.655.0915 tel.	Exhibition Planner and Brandston Partnership Inc 88 Pine Street New York, New York 10005 212.334.8200 tel.	Lighting Designer Brandston Partnership Inc 122 West 26th Street New York, New York 10001 212.924.4050 tel.
--	---	--	---	---	--	--	--	---

Exhibit Construction

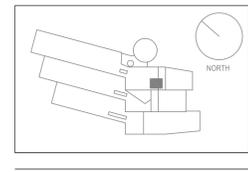

Key Plan


80% FD	Dec. 19, 2008
100% DD	June 2, 2008
XG 60% CD	May 5, 2008
WS9	March 26, 2008
WS8	Feb. 20, 2008
WS7	Dec. 18, 2007
50% DD	Sept. 18, 2007
WS6	July 11, 2007
WS5	May 23, 2007
WS4	April 12, 2007

No. / Issue Name / Date

No. / Issue Name / Date

Sheet Title	
Level 3 Elevations:	
Dry Cave	
Date	Project No.
Dec. 19, 2008	0275
Scale*	Sheet No.
1/4"=1'-0"	X3-DC-2.00

*Note: Scale Given for Full Size Drawing Sheet (22" x 34")

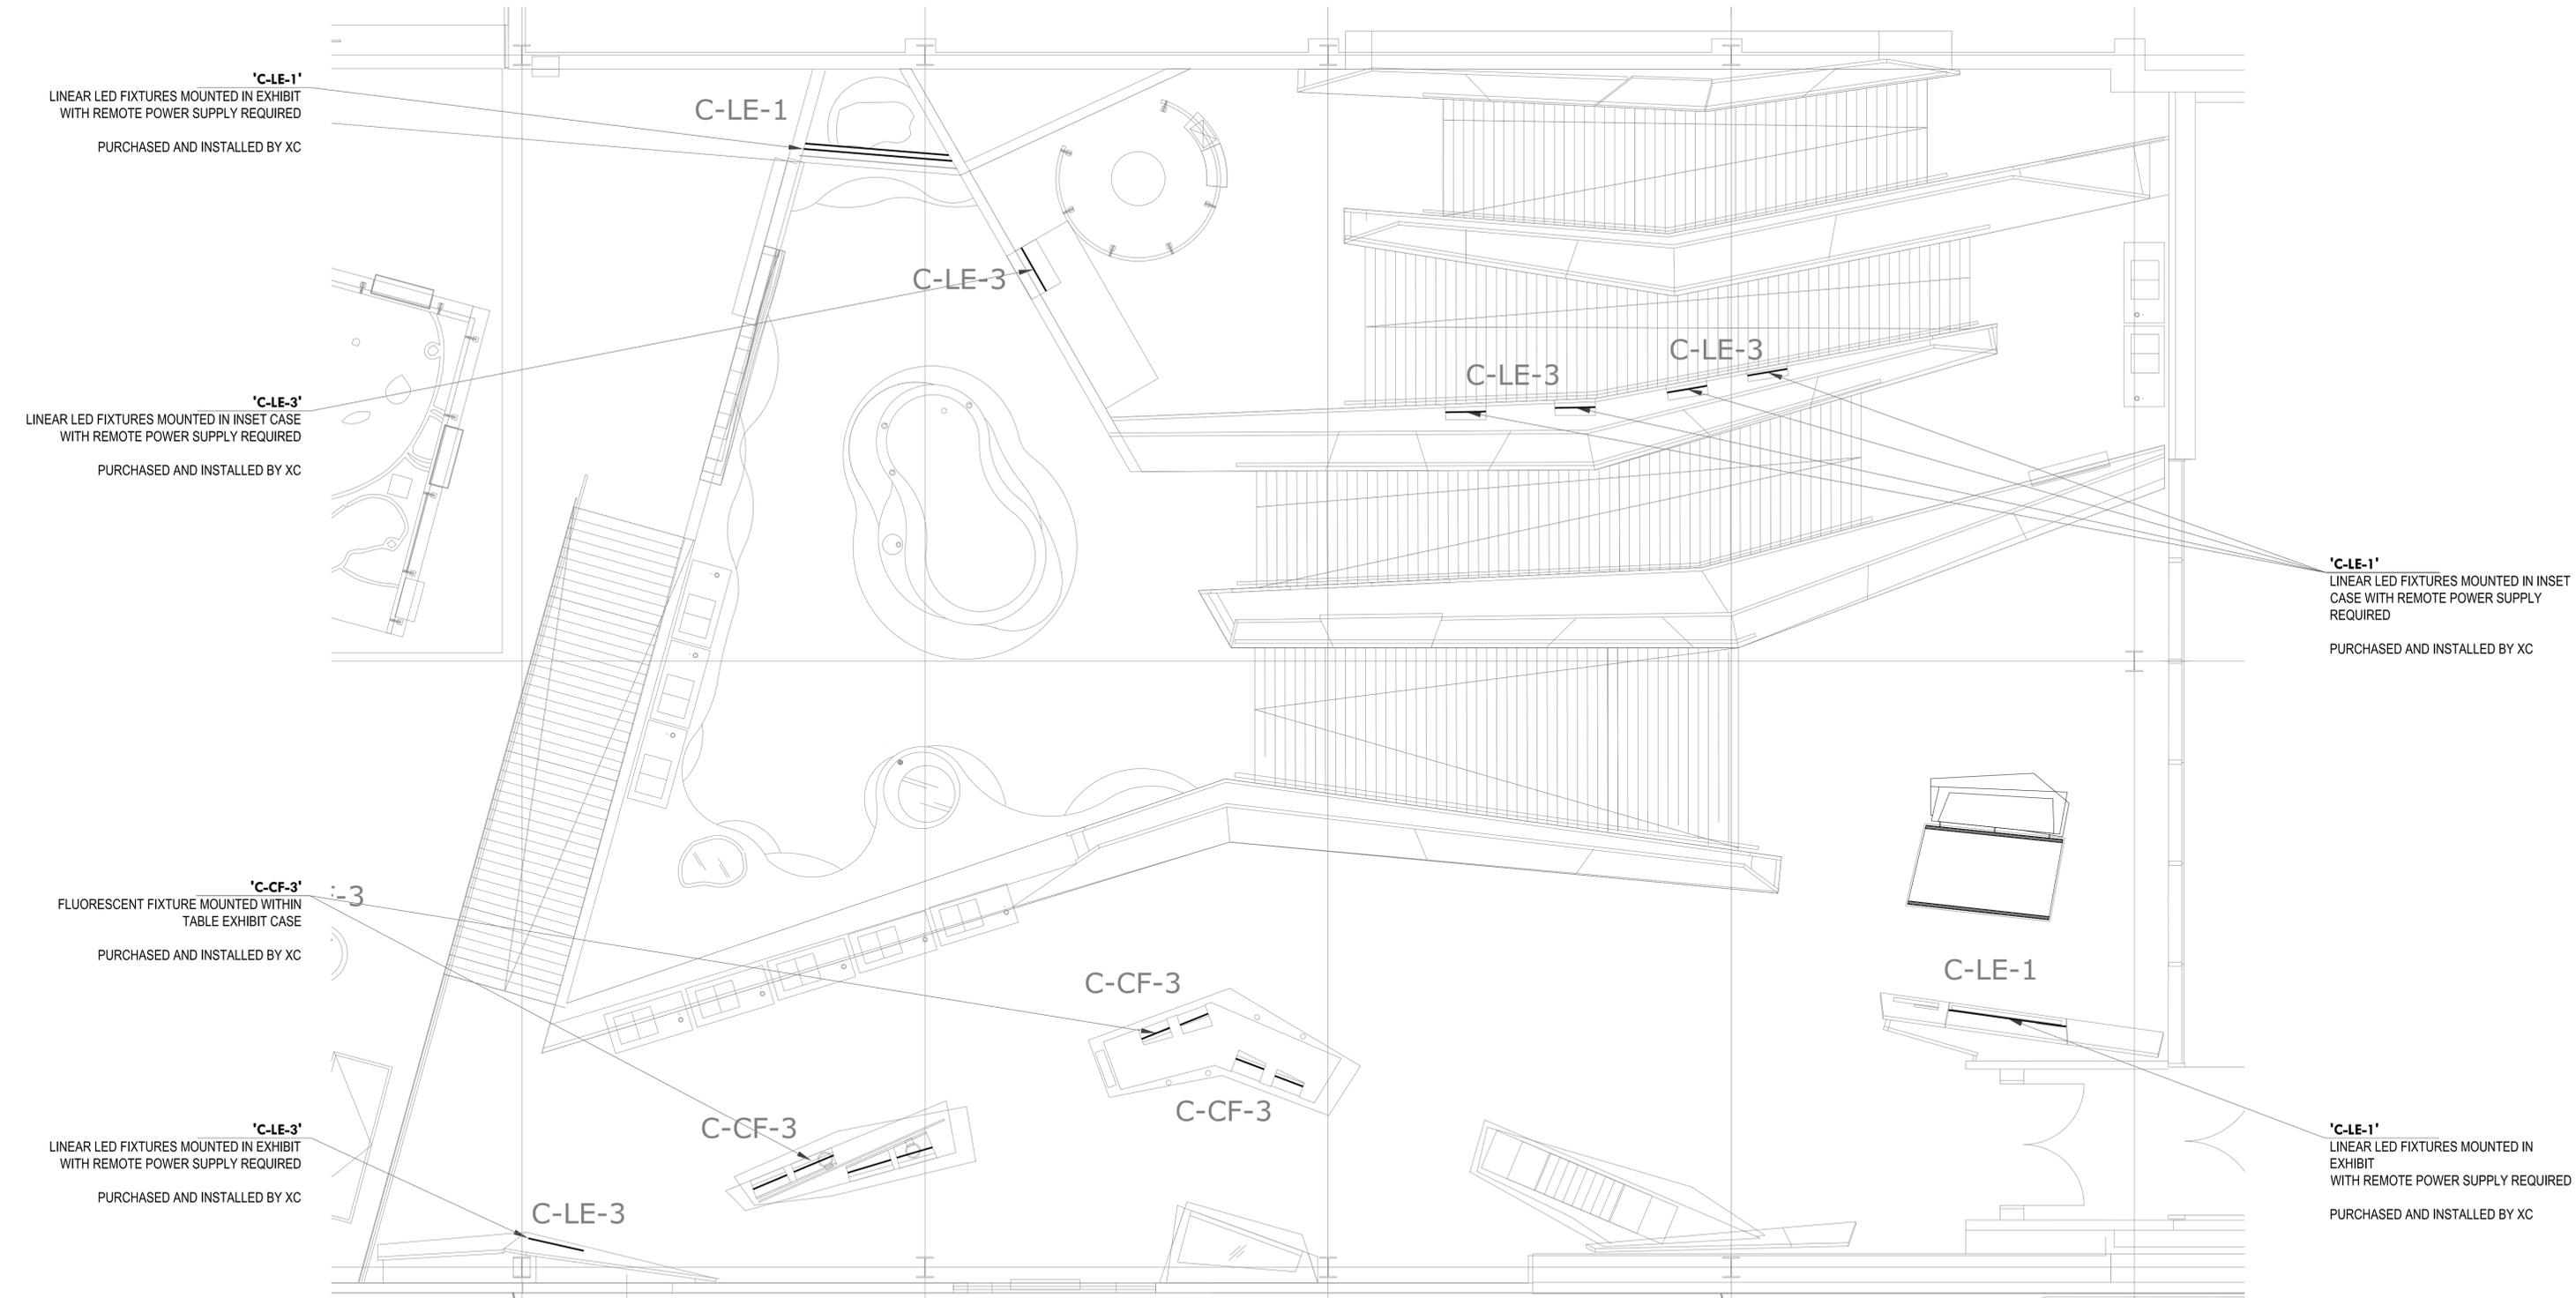


UTAH MUSEUM OF NATURAL HISTORY

UNIVERSITY OF UTAH, SALT LAKE CITY, UTAH

Owner UMNH 1300 East President's Circle Salt Lake City, Utah 84112 801.581.6927 tel.	Design Architect Polshak Partnership Architects LLP 320 West 13th Street New York, New York 212.807.7171 tel.	Architect of Record Giles Stransky Brans Smith 375 West 200 South Salt Lake City, Utah 801.521.8600 tel.	Structural Engineer Leslie E. Robertson Associates 30 Broad Street New York, New York 10004 212.750.9000 tel.	Mechanical/Plumbing/Fire Protection Coligni Engineering Associates, Inc. 244 West 300 North Salt Lake City, Utah 84103 801.322.2400 tel.	Electrical/AV Engineer Spectrum Engineers 175 South Main Street Salt Lake City, Utah 84111 800.678.7077 tel.	Landscape Architect Design Workshop, Inc. 1796 Prospector Avenue Park City, Utah 84060 435.655.0915 tel.	Exhibition Planner and Rabin Rabinbaum Associates 88 Pine Street New York, New York 10005 212.334.8200 tel.	Lighting Designer Brandston Partnership Inc 122 West 26th Street New York, New York 10001 212.924.4050 tel.
--	---	--	---	--	--	--	---	---

Exhibit Construction

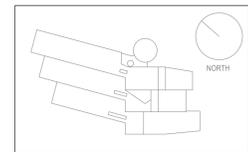

Key Plan


80% FD	Dec. 19, 2008
100% DD	June 2, 2008
XG 60% CD	May 5, 2008
WS9	March 26, 2008
WS8	Feb. 20, 2008
WS7	Dec. 18, 2007
50% DD	Sept. 18, 2007
WS6	July 11, 2007
WS5	May 23, 2007
WS4	April 12, 2007

No. / Issue Name / Date

No. / Issue Name / Date

Sheet Title	
Level 3 Partial Plan: The Land Observatory	
Date	Project No.
Dec. 19, 2008	0275
Scale*	Sheet No.
1/4"=1'-0"	LX3-LD-1.00

*Note: Scale Given for Full Size Drawing Sheet (22" x 34")

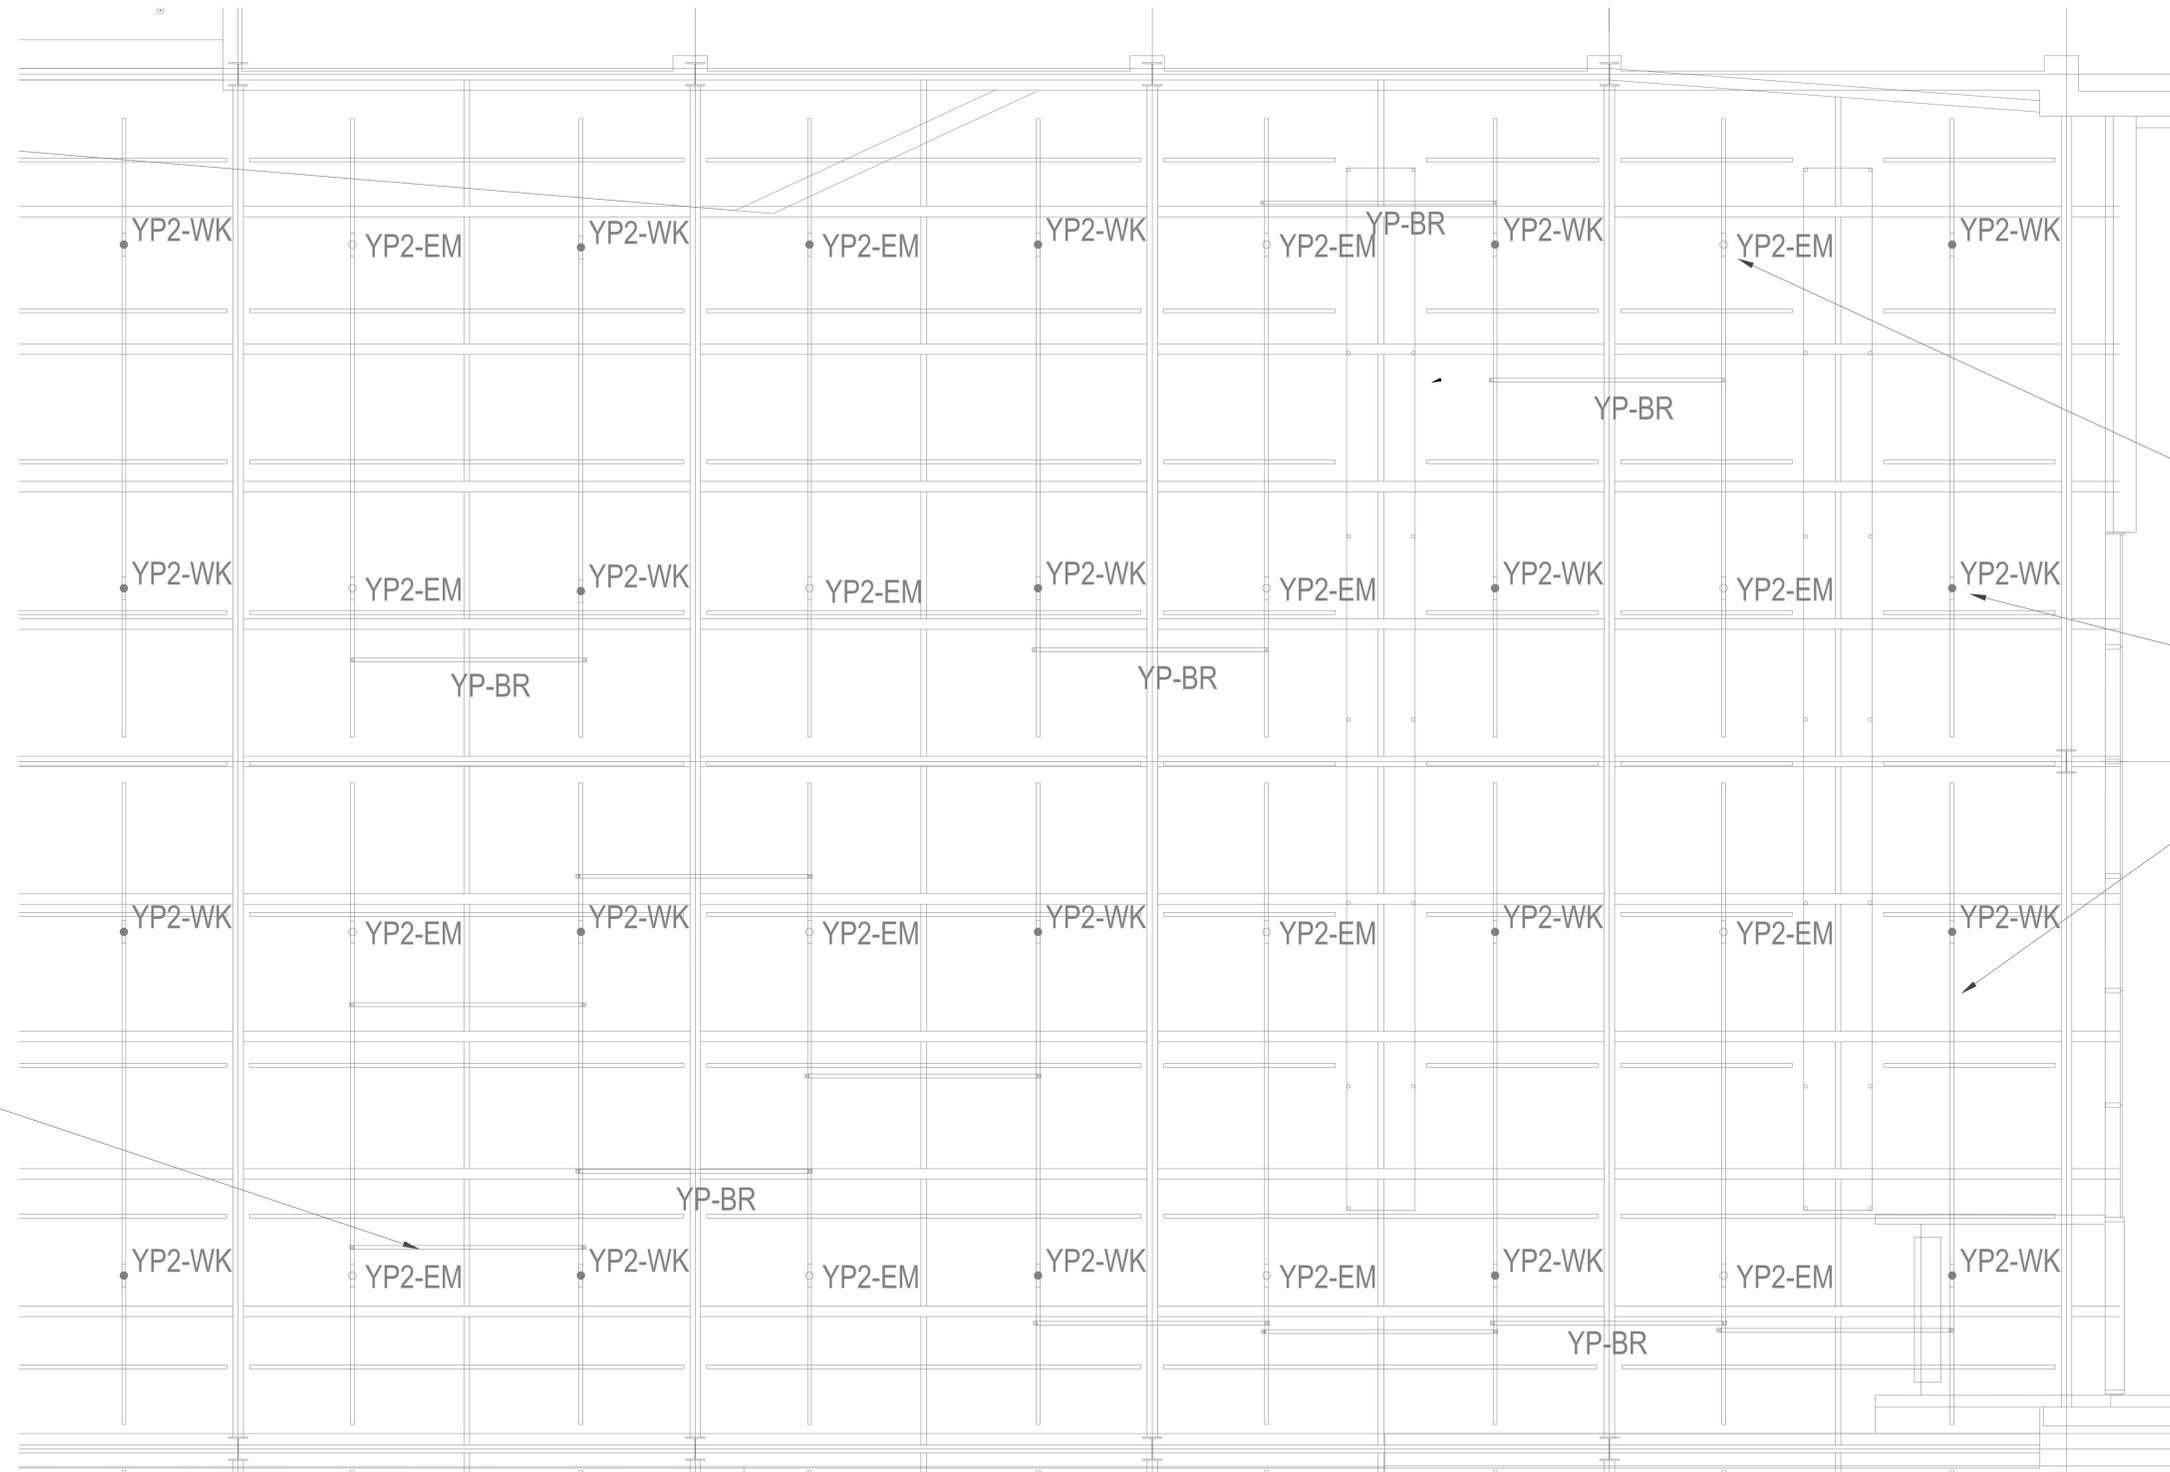

'YP2-EM' (YP-203)
 15 INCH SEGMENTED TRACK WITH 100W HALOGEN
 FIXTURE FOR EMERGENCY LIGHTING. TRACK TO BE AT
 THE END OR IN LINE WITH YP-2 TRACK AND MOUNTED
 ON UNI-STRUT

PURCHASED AND INSTALLED BY GC

'YP2-WK' (YP-204)
 15 INCH SEGMENT TRACK WITH 150W MH FIXTURE FOR
 WORK LIGHT. TRACK TO BE AT THE END OR IN LINE
 WITH YP-2 TRACK AND MOUNTED ON UNI-STRUT

PURCHASED AND INSTALLED BY GC

'YP-2' (YP-201)
 SINGLE CIRCUIT TRACKS MOUNTED ON CONTINUOUS
 UNI-STRUT

PURCHASED AND INSTALLED BY GC


'YP-BR' (YP-202)
 NOMINAL 10' LONG BRIDGE TRACK MOUNTED
 WHERE REQUIRED
 PURCHASED AND INSTALLED BY GC

UTAH MUSEUM OF NATURAL HISTORY

UNIVERSITY OF UTAH, SALT LAKE CITY, UTAH

Owner UMNH 1300 East President's Circle Salt Lake City, Utah 84112 801.581.6927 tel.	Design Architect Polshak Partnership Architects LLP 320 West 13th Street New York, New York 212.807.7171 tel.	Architect of Record Stefansky Drans Smith 375 West 200 South Salt Lake City, Utah 801.521.8600 tel.	Structural Engineer Leslie E. Robertson Associates 30 Broad Street New York, New York 10004 212.750.9000 tel.	Mechanical/Plumbing/Fire Protection Coligni Engineering Associates, Inc. 244 West 300 North Salt Lake City, Utah 84103 801.322.2400 tel.	Electrical/AV Engineer Spectrum Engineers 175 South Main Street Salt Lake City, Utah 84111 800.678.7077 tel.	Landscape Architect Design Workshop, Inc. 1796 Prospector Avenue Park City, Utah 84060 435.655.0915 tel.	Exhibition Planner and Rabin Rabinbaum Associates 88 Pine Street New York, New York 10005 212.334.8200 tel.	Lighting Designer Brandston Partnership Inc 122 West 26th Street New York, New York 10001 212.924.4050 tel.
--	---	--	---	--	--	--	---	---

Exhibit Construction

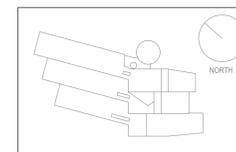

Key Plan

80% FD	Dec. 19, 2008
100% DD	June 2, 2008
XG 60% CD	May 5, 2008
WS9	March 26, 2008
WS8	Feb. 20, 2008
WS7	Dec. 18, 2007
50% DD	Sept. 18, 2007
WS6	July 11, 2007
WS5	May 23, 2007
WS4	April 12, 2007


No. / Issue Name / Date

No. / Issue Name / Date


Sheet Title
 Level 3 Partial RCP:
 The Land Observatory

Date	Project No.
Dec. 19, 2008	0275
Scale*	Sheet No.
1/4"=1'-0"	LX3-LD-1.02


*Note: Scale Given for Full Size Drawing Sheet (22" x 34")

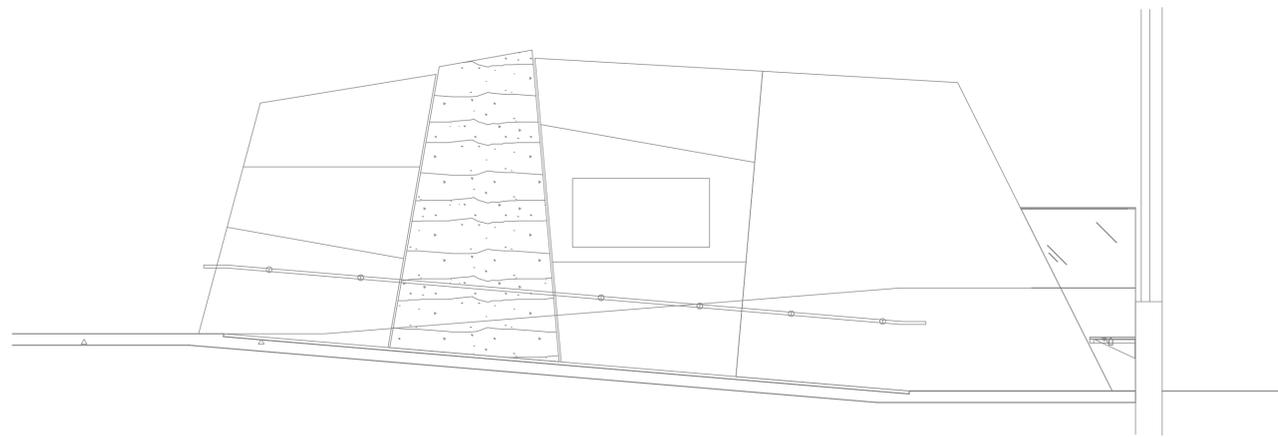


1 EAST ELEVATION MID. ROCKY MOUNTAINS
SCALE: 1/4" = 1'-0"

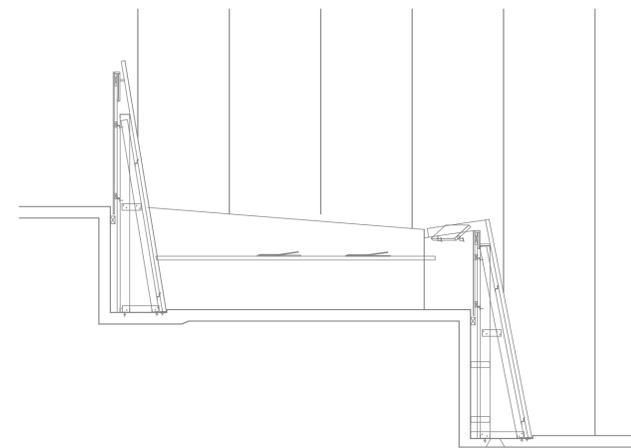


3 SOUTH ELEVATION MID. ROCKY MOUNTAINS
SCALE: 1/4" = 1'-0"

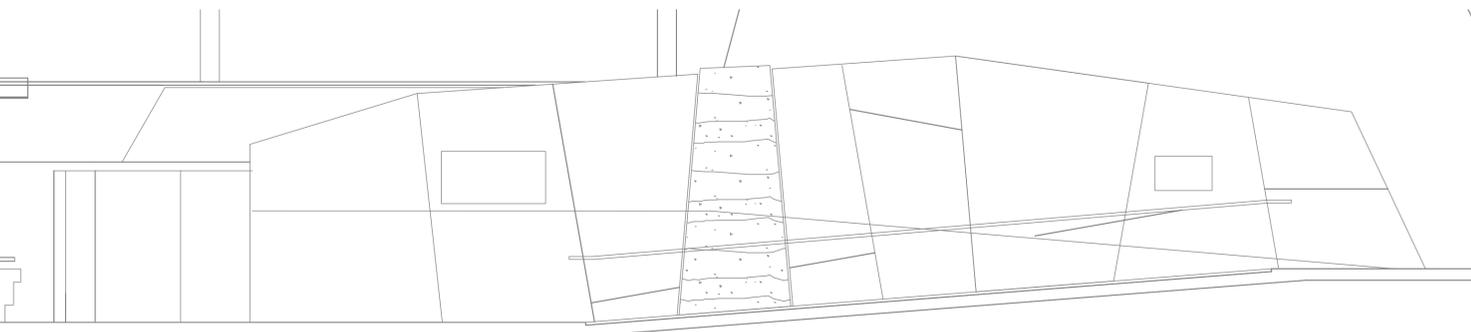

5 EAST ELEVATION MID. ROCKY MOUNTAINS
SCALE: 1/4" = 1'-0"

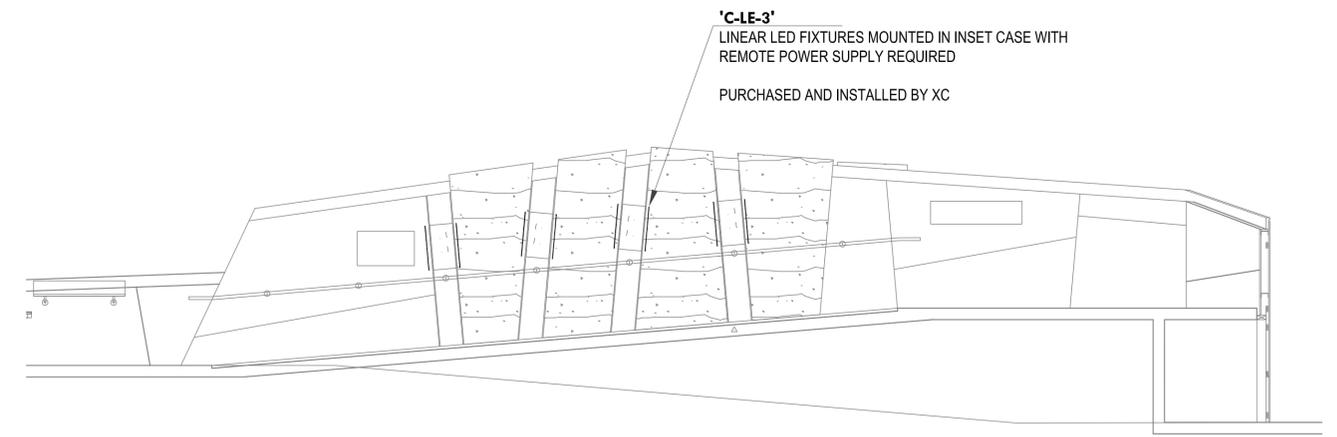

2 WEST ELEVATION MID. ROCKY MOUNTAINS
SCALE: 1/4" = 1'-0"

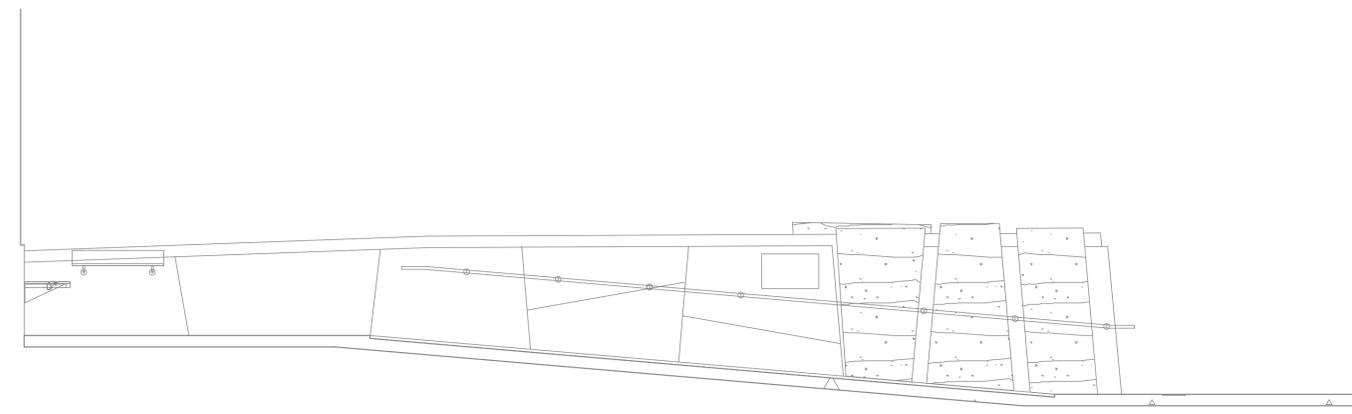


4 WEST ELEVATION MID. ROCKY MOUNTAINS
SCALE: 1/4" = 1'-0"

UTAH MUSEUM OF NATURAL HISTORY

UNIVERSITY OF UTAH, SALT LAKE CITY, UTAH

Owner UMNH 1300 East President's Circle Salt Lake City, Utah 84112 801.581.6927 tel.	Design Architect Polshak Partnership Architects LLP 320 West 13th Street New York, New York 212.807.7171 tel.	Architect of Record Sofronsky Brans Smith 375 West 200 South Salt Lake City, Utah 801.521.8600 tel.	Structural Engineer Leslie E. Robertson Associates 30 Broad Street New York, New York 10004 212.750.9000 tel.	Mechanical/Plumbing/Fire Protection Edgell Engineering Associates, Inc. 244 West 300 North Salt Lake City, Utah 84103 801.322.2400 tel.	Electrical/AV Engineer Spectrum Engineers 175 South Main Street Salt Lake City, Utah 84111 800.678.7077 tel.	Landscape Architect Design Workshop, Inc. 1796 Prospector Avenue Park City, Utah 84060 435.655.0915 tel.	Exhibition Planner and Rabinowitz Associates 88 Pine Street New York, New York 10005 212.334.8200 tel.	Lighting Designer Brandston Partnership Inc 122 West 26th Street New York, New York 10001 212.924.4050 tel.
--	---	---	---	---	--	--	--	---

Exhibit Construction

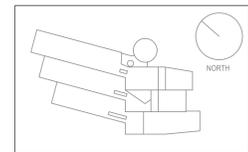

Key Plan

80% FD	Dec. 19, 2008
100% DD	June 2, 2008
XG 60% CD	May 5, 2008
WS9	March 26, 2008
WS8	Feb. 20, 2008
WS7	Dec. 18, 2007
50% DD	Sept. 18, 2007
WS6	July 11, 2007
WS5	May 23, 2007
WS4	April 12, 2007

No. / Issue Name / Date

No. / Issue Name / Date

Sheet Title
Level 3 Sections & Elevations:
The Land Observatory - MRM


Date	Project No.
Dec. 19, 2008	0275
Scale*	Sheet No.
1/4"=1'-0"	X3-LD-2.01

*Note: Scale Given for Full Size Drawing Sheet (22" x 34")

'C-LE-3'
 LINEAR LED FIXTURES MOUNTED IN INSET CASE WITH
 REMOTE POWER SUPPLY REQUIRED
 PURCHASED AND INSTALLED BY XC

'C-LE-1'
 LINEAR LED FIXTURES MOUNTED IN EXHIBIT
 WITH REMOTE POWER SUPPLY REQUIRED
 PURCHASED AND INSTALLED BY XC

'C-LE-1'
 LINEAR LED FIXTURES MOUNTED IN EXHIBIT
 WITH REMOTE POWER SUPPLY REQUIRED
 PURCHASED AND INSTALLED BY XC

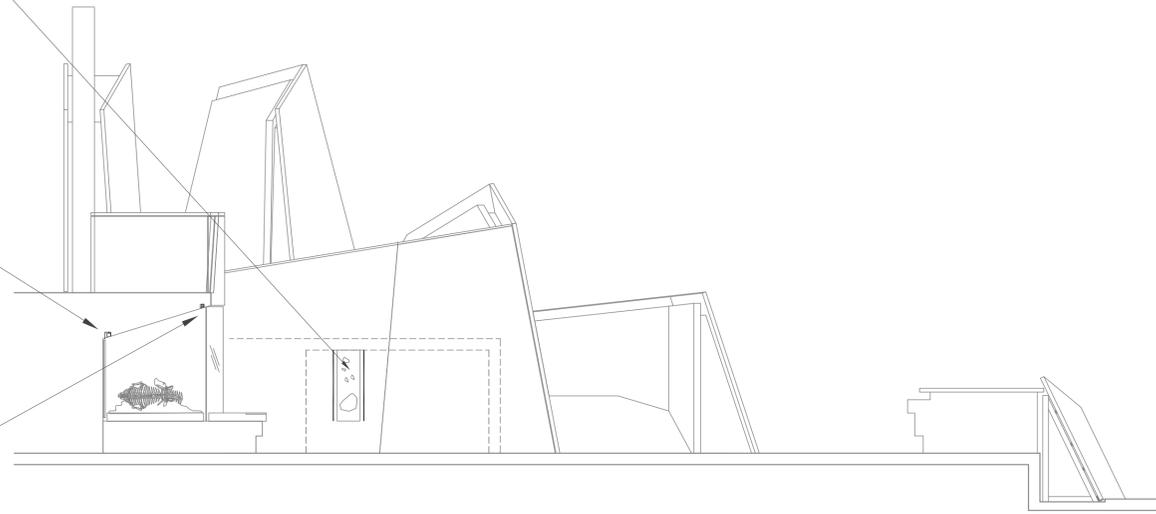


1 NORTH ELEVATION COLORADO
 PLATEAU
 SCALE: 1/4" = 1'-0"

UTAH MUSEUM OF NATURAL HISTORY

UNIVERSITY OF UTAH, SALT LAKE CITY, UTAH

Owner UMNH 1300 East President's Circle Salt Lake City, Utah 84112 801.581.6927 tel.	Design Architect Polshak Partnership Architects LLP 320 West 13th Street New York, New York 212.807.7171 tel.	Architect of Record Sternberg Architects 375 West 200 South Salt Lake City, Utah 801.521.8600 tel.	Structural Engineer Leslie E. Robertson Associates 30 Broad Street New York, New York 10004 212.750.9000 tel.	Mechanical/Plumbing/Fire Protection Cognit Engineering Associates, Inc. 244 West 300 North Salt Lake City, Utah 84103 801.322.2400 tel.	Electrical/AV Engineer Spectrum Engineers 175 South Main Street Salt Lake City, Utah 84111 800.678.7077 tel.	Landscape Architect Design Workshop, Inc. 1796 Prospector Avenue Park City, Utah 84060 435.655.0915 tel.	Exhibition Planner and Rabinowitz Associates 88 Pine Street New York, New York 10005 212.334.8200 tel.	Lighting Designer Brandston Partnership Inc 122 West 26th Street New York, New York 10001 212.924.4050 tel.
---	--	---	--	--	---	---	---	--

Exhibit Construction

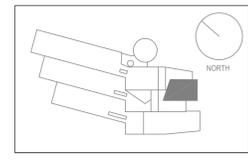

Key Plan

80% FD	Dec. 19, 2008
100% DD	June 2, 2008
XG 60% CD	May 5, 2008
WS9	March 26, 2008
WS8	Feb. 20, 2008
WS7	Dec. 18, 2007
50% DD	Sept. 18, 2007
WS6	July 11, 2007
WS5	May 23, 2007
WS4	April 12, 2007


No. / Issue Name / Date

No. / Issue Name / Date

Sheet Title
 Level 3 Sections & Elevations
 The Land Observatory - CP

Date Dec. 19, 2008	Project No. 0275
Scale* 1/4"=1'-0"	Sheet No. LX3-LD-2.02

*Note: Scale Given for Full Size Drawing Sheet (22" x 34")

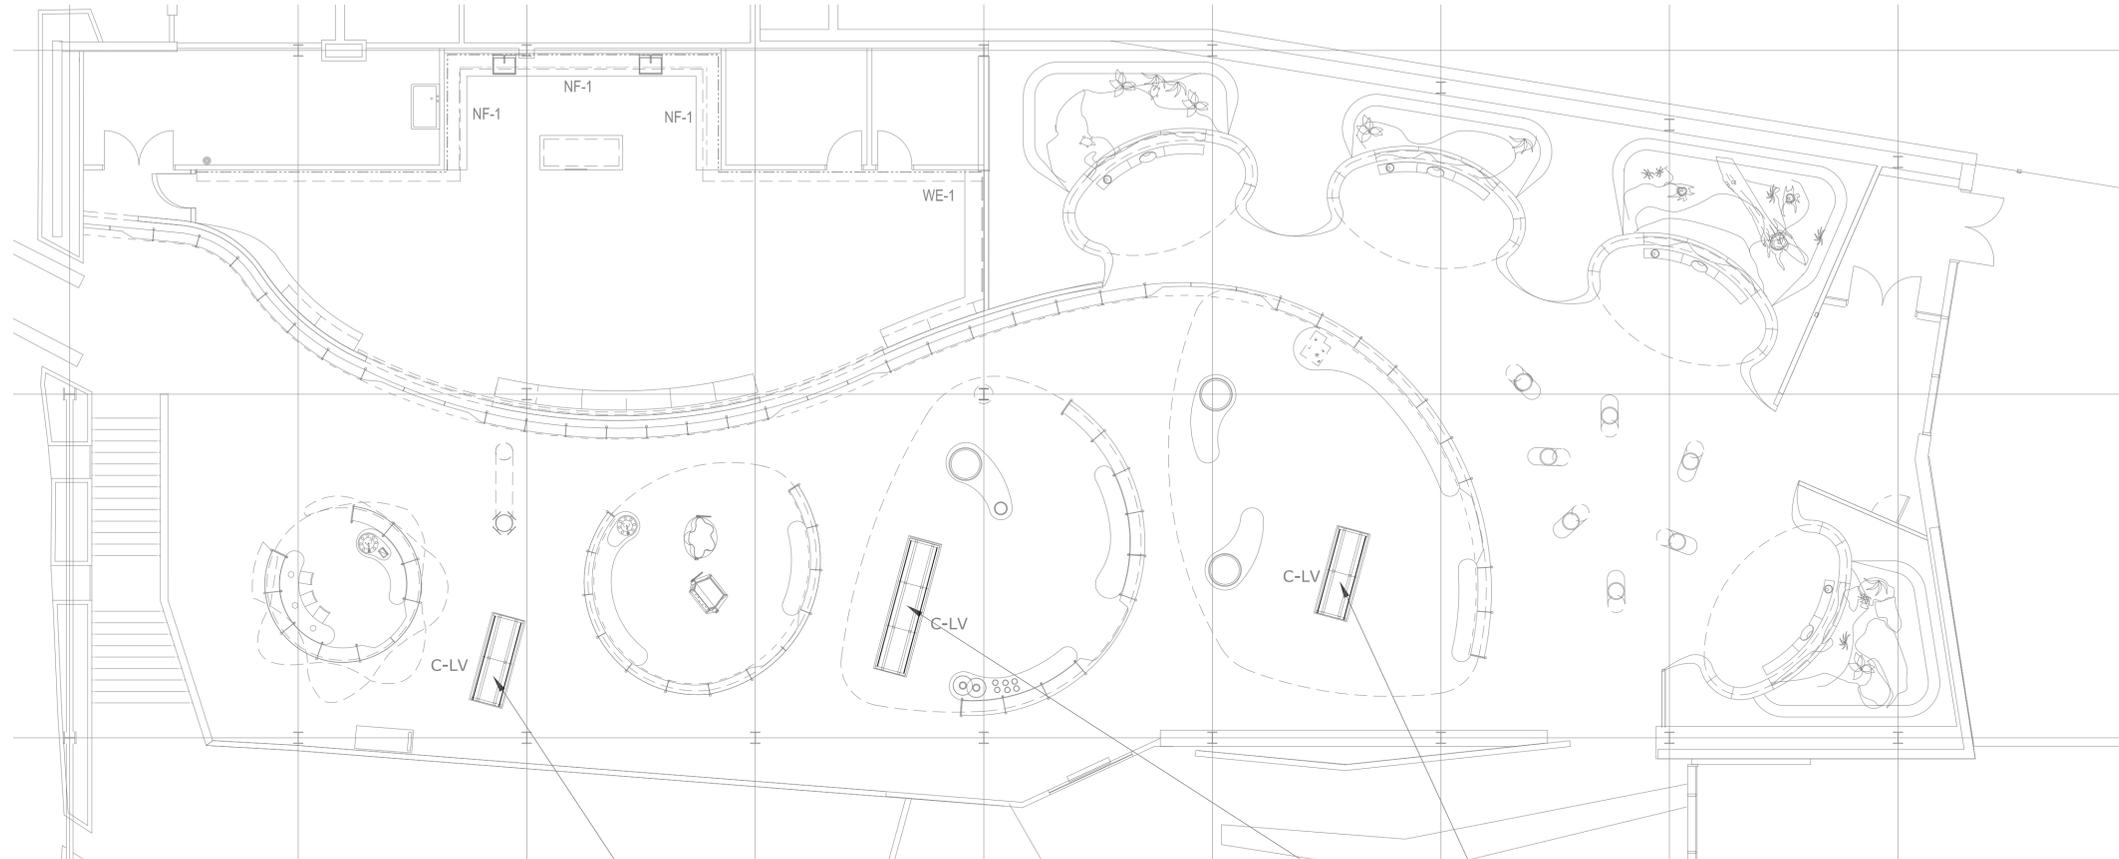

'C-LV'
 LOW VOLTAGE TRACK SYSTEM MOUNTED TO CASE FRAMES WITH LED TRACK HEADS AND REMOTE TRANSFORMERS
 PURCHASED AND INSTALLED BY XC


'C-LV'
 LOW VOLTAGE TRACK SYSTEM MOUNTED TO CASE FRAMES WITH LED TRACK HEADS AND REMOTE TRANSFORMERS
 PURCHASED AND INSTALLED BY XC

UTAH MUSEUM OF NATURAL HISTORY

UNIVERSITY OF UTAH, SALT LAKE CITY, UTAH

Owner UMNH 1300 East President's Circle Salt Lake City, Utah 84112 801.581.6927 tel.	Design Architect Polshak Partnership Architects LLP 320 West 13th Street New York, New York 212.807.7171 tel.	Architect of Record Giffels Strinsky Brems Smith 375 West 200 South Salt Lake City, Utah 801.521.8600 tel.	Structural Engineer Leslie E. Robertson Associates 30 Broad Street New York, New York 10004 212.750.9000 tel.	Mechanical/Plumbing/Fire Protection Coligni Engineering Associates, Inc. 244 West 300 North Salt Lake City, Utah 84103 801.322.2400 tel.	Electrical/AV Engineer Spectrum Engineers 175 South Main Street Salt Lake City, Utah 84111 800.678.7077 tel.	Landscape Architect Design Workshop, Inc. 1796 Prospector Avenue Park City, Utah 84060 435.655.0915 tel.	Exhibition Planner and Rabin Rabinbaum Associates 88 Pine Street New York, New York 10005 212.334.8200 tel.	Lighting Designer Brandston Partnership Inc 122 West 26th Street New York, New York 10001 212.924.4050 tel.
---	--	---	--	---	---	---	--	--

Exhibit Construction

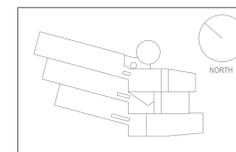

Key Plan

80% FD	Dec. 19, 2008
100% DD	June 2, 2008
XG 60% CD	May 5, 2008
WS9	March 26, 2008
WS8	Feb. 20, 2008
WS7	Dec. 18, 2007
50% DD	Sept. 18, 2007
WS6	July 11, 2007
WS5	May 23, 2007
WS4	April 12, 2007

No. / Issue Name / Date

No. / Issue Name / Date

Sheet Title
**Level 4 Partial Plan:
 Life Observatory**


Date
 Dec. 19, 2008

Scale*
 1/8"=1'-0"

Project No.
 0275

Sheet No.
 LX4-LF-1.00

*Note: Scale Given for Full Size Drawing Sheet (22" x 34")

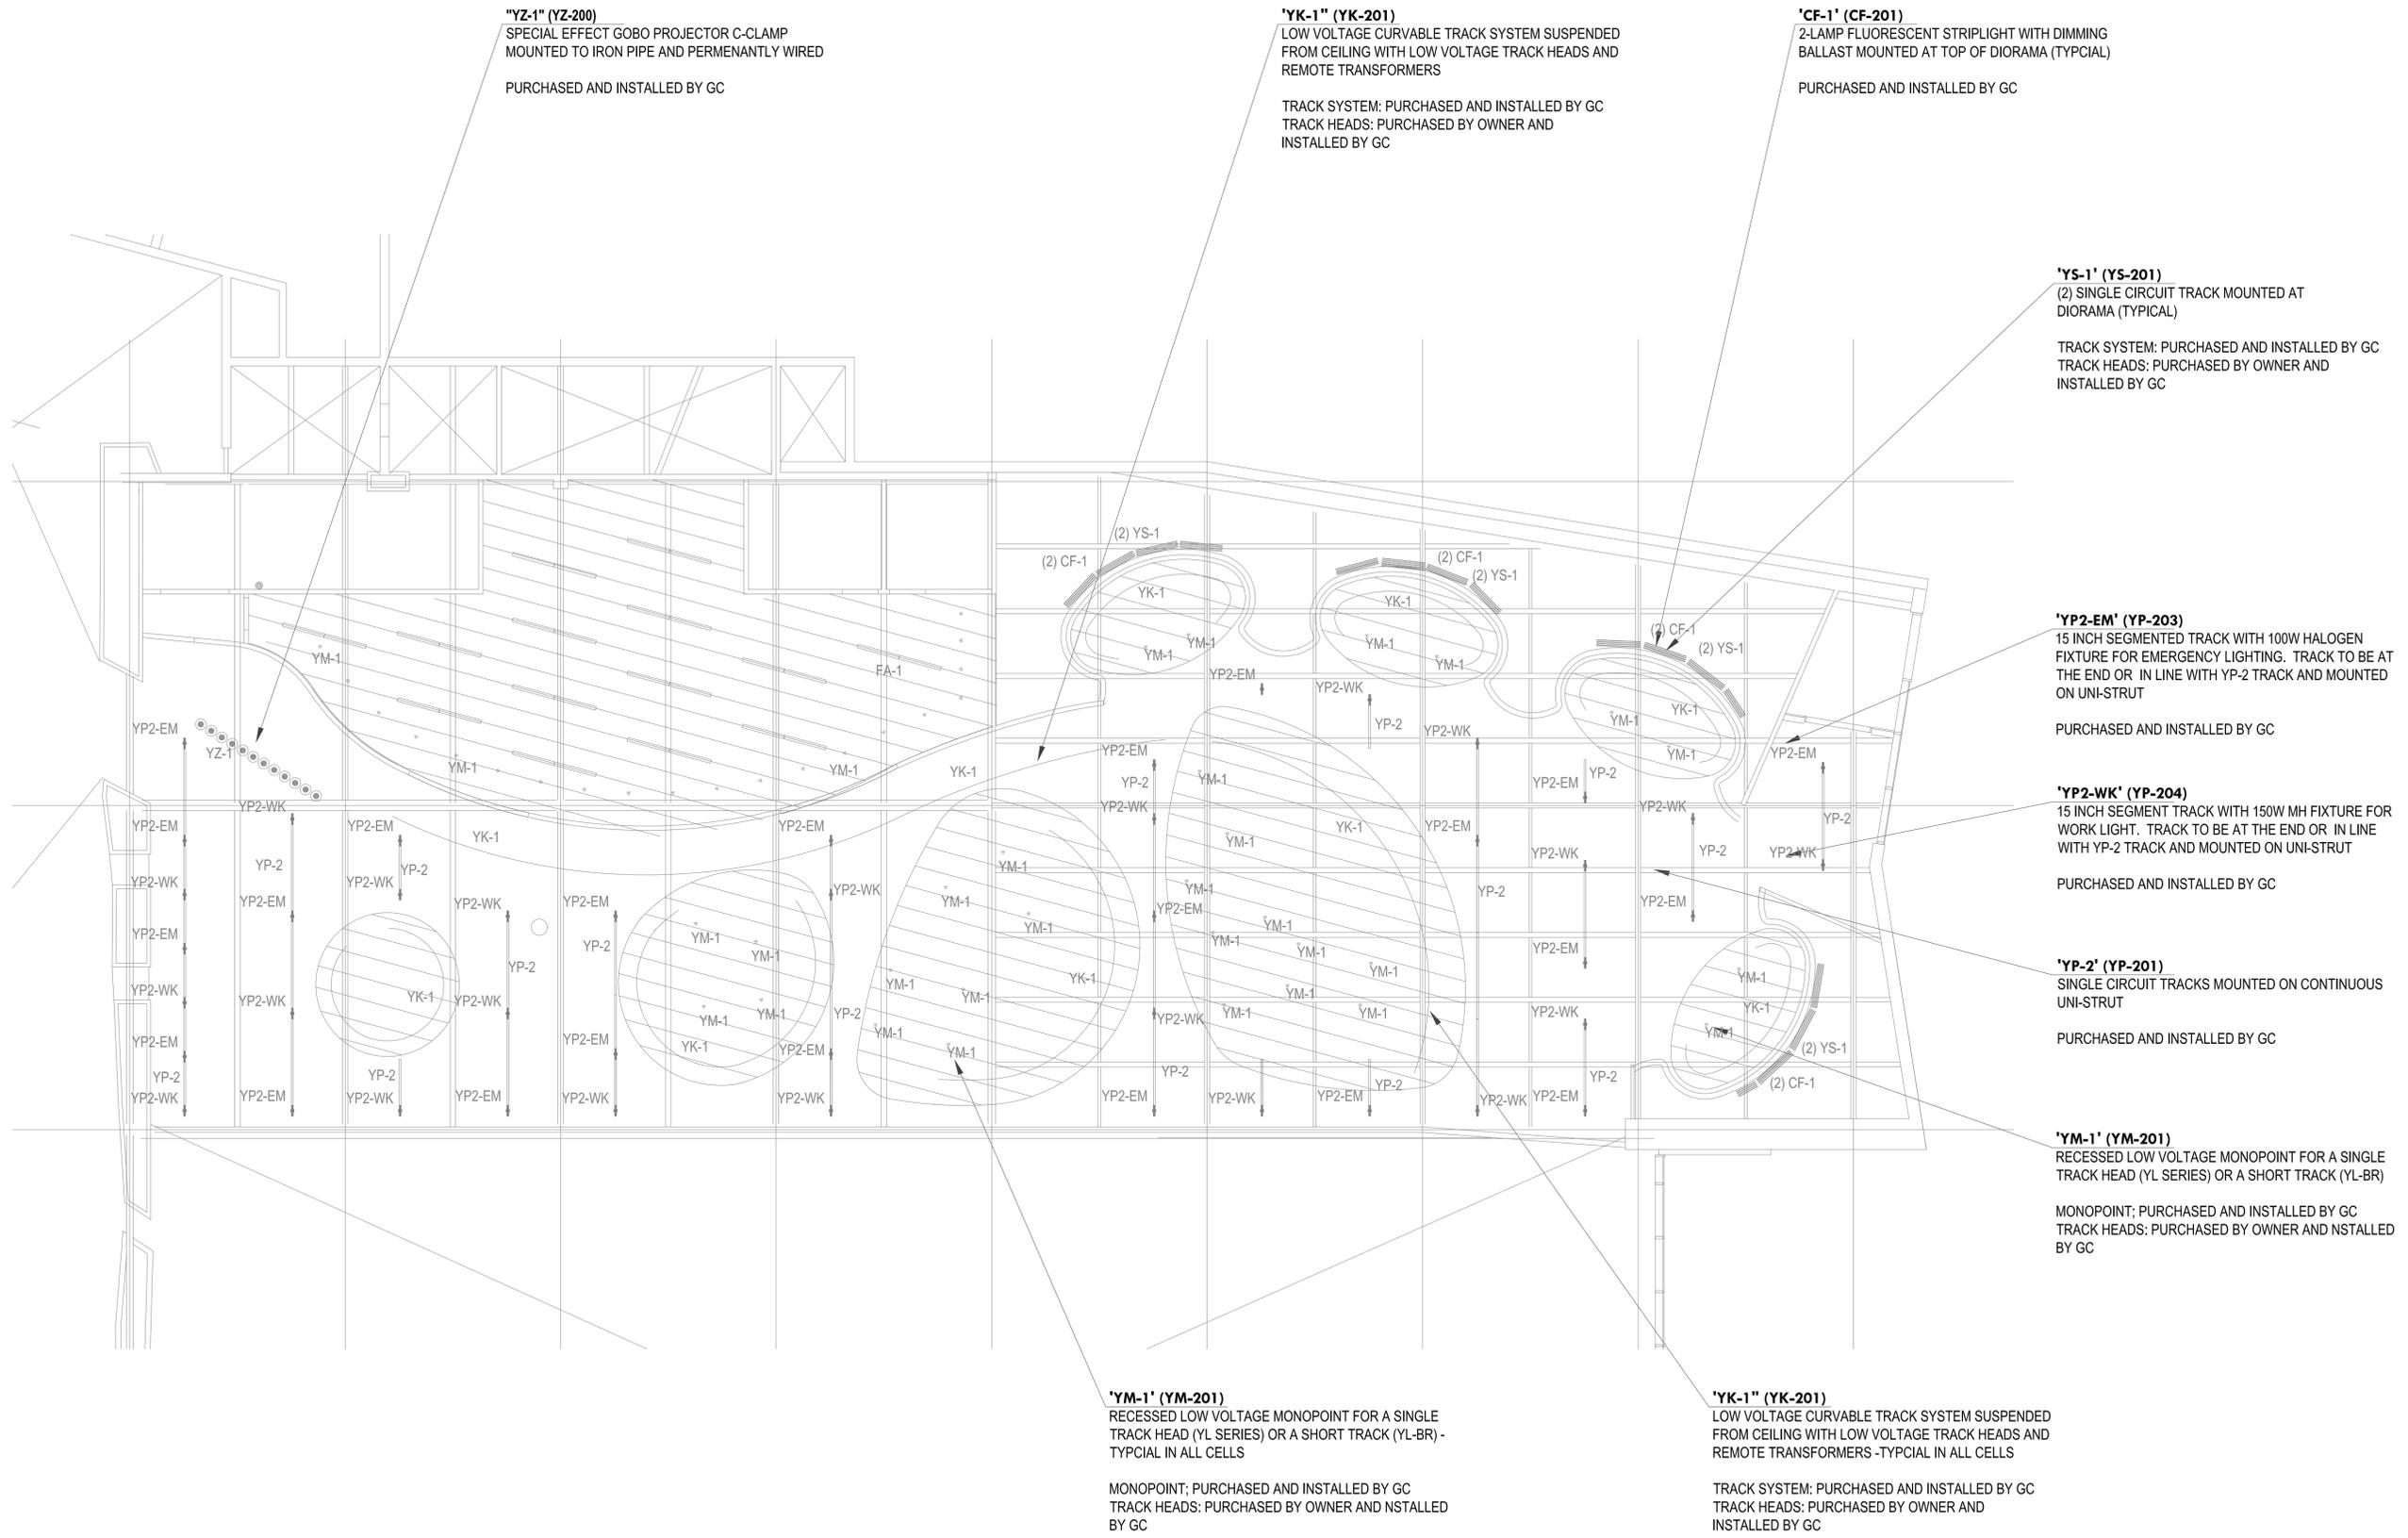

"YZ-1" (YZ-200)
 SPECIAL EFFECT GOBO PROJECTOR C-CLAMP
 MOUNTED TO IRON PIPE AND PERMANENTLY WIRED
 PURCHASED AND INSTALLED BY GC

'YK-1" (YK-201)
 LOW VOLTAGE CURVABLE TRACK SYSTEM SUSPENDED
 FROM CEILING WITH LOW VOLTAGE TRACK HEADS AND
 REMOTE TRANSFORMERS
 TRACK SYSTEM: PURCHASED AND INSTALLED BY GC
 TRACK HEADS: PURCHASED BY OWNER AND
 INSTALLED BY GC

'CF-1" (CF-201)
 2-LAMP FLUORESCENT STRIPLIGHT WITH DIMMING
 BALLAST MOUNTED AT TOP OF DIORAMA (TYPICAL)
 PURCHASED AND INSTALLED BY GC

'YS-1" (YS-201)
 (2) SINGLE CIRCUIT TRACK MOUNTED AT
 DIORAMA (TYPICAL)
 TRACK SYSTEM: PURCHASED AND INSTALLED BY GC
 TRACK HEADS: PURCHASED BY OWNER AND
 INSTALLED BY GC

'YP2-EM' (YP-203)
 15 INCH SEGMENTED TRACK WITH 100W HALOGEN
 FIXTURE FOR EMERGENCY LIGHTING. TRACK TO BE AT
 THE END OR IN LINE WITH YP-2 TRACK AND MOUNTED
 ON UNI-STRUT
 PURCHASED AND INSTALLED BY GC

'YP2-WK' (YP-204)
 15 INCH SEGMENT TRACK WITH 150W MH FIXTURE FOR
 WORK LIGHT. TRACK TO BE AT THE END OR IN LINE
 WITH YP-2 TRACK AND MOUNTED ON UNI-STRUT
 PURCHASED AND INSTALLED BY GC

'YP-2' (YP-201)
 SINGLE CIRCUIT TRACKS MOUNTED ON CONTINUOUS
 UNI-STRUT
 PURCHASED AND INSTALLED BY GC

'YM-1" (YM-201)
 RECESSED LOW VOLTAGE MONOPOINT FOR A SINGLE
 TRACK HEAD (YL SERIES) OR A SHORT TRACK (YL-BR)
 MONOPOINT; PURCHASED AND INSTALLED BY GC
 TRACK HEADS: PURCHASED BY OWNER AND INSTALLED
 BY GC

'YM-1" (YM-201)
 RECESSED LOW VOLTAGE MONOPOINT FOR A SINGLE
 TRACK HEAD (YL SERIES) OR A SHORT TRACK (YL-BR) -
 TYPICAL IN ALL CELLS
 MONOPOINT; PURCHASED AND INSTALLED BY GC
 TRACK HEADS: PURCHASED BY OWNER AND INSTALLED
 BY GC


'YK-1" (YK-201)
 LOW VOLTAGE CURVABLE TRACK SYSTEM SUSPENDED
 FROM CEILING WITH LOW VOLTAGE TRACK HEADS AND
 REMOTE TRANSFORMERS - TYPICAL IN ALL CELLS
 TRACK SYSTEM: PURCHASED AND INSTALLED BY GC
 TRACK HEADS: PURCHASED BY OWNER AND
 INSTALLED BY GC

UTAH MUSEUM OF NATURAL HISTORY

UNIVERSITY OF UTAH, SALT LAKE CITY, UTAH

Owner UMNH 1300 East President's Circle Salt Lake City, Utah 84112 801.581.6927 tel.	Design Architect Polshak Partnership Architects LLP 320 West 13th Street New York, New York 212.807.7171 tel.	Architect of Record Giffels Strinsky Drans Smith 375 West 200 South Salt Lake City, Utah 801.521.8600 tel.	Structural Engineer Leslie E. Robertson Associates 30 Broad Street New York, New York 10004 212.750.9000 tel.	Mechanical/Plumbing/Fire Protection Cajigas Engineering Associates, Inc. 244 West 300 North Salt Lake City, Utah 84103 801.322.2400 tel.	Electrical/AV Engineer Spectrum Engineers 175 South Main Street Salt Lake City, Utah 84111 800.678.7077 tel.	Landscape Architect Design Workshop, Inc. 1796 Prospector Avenue Park City, Utah 84060 435.655.0915 tel.	Exhibition Planner and Rabin Rabinbaum Associates 88 Pine Street New York, New York 10005 212.334.8200 tel.	Lighting Designer Brandston Partnership Inc 122 West 26th Street New York, New York 10001 212.924.4050 tel.
---	--	---	--	---	---	---	--	--

Exhibit Construction

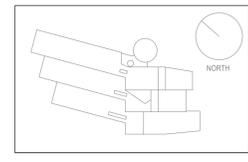

Key Plan


80% FD	Dec. 19, 2008
100% DD	June 2, 2008
XG 60% CD	May 5, 2008
WS9	March 26, 2008
WS8	Feb. 20, 2008
WS7	Dec. 18, 2007
50% DD	Sept. 18, 2007
WS6	July 11, 2007
WS5	May 23, 2007
WS4	April 12, 2007

No. / Issue Name / Date

No. / Issue Name / Date

Sheet Title	
Level 4 Partial RCP: Life Observatory	
Date	Project No.
Dec. 19, 2008	0275
Scale*	Sheet No.
1/8"=1'-0"	LX4-LF-1.02

*Note: Scale Given for Full Size Drawing Sheet (22" x 34")

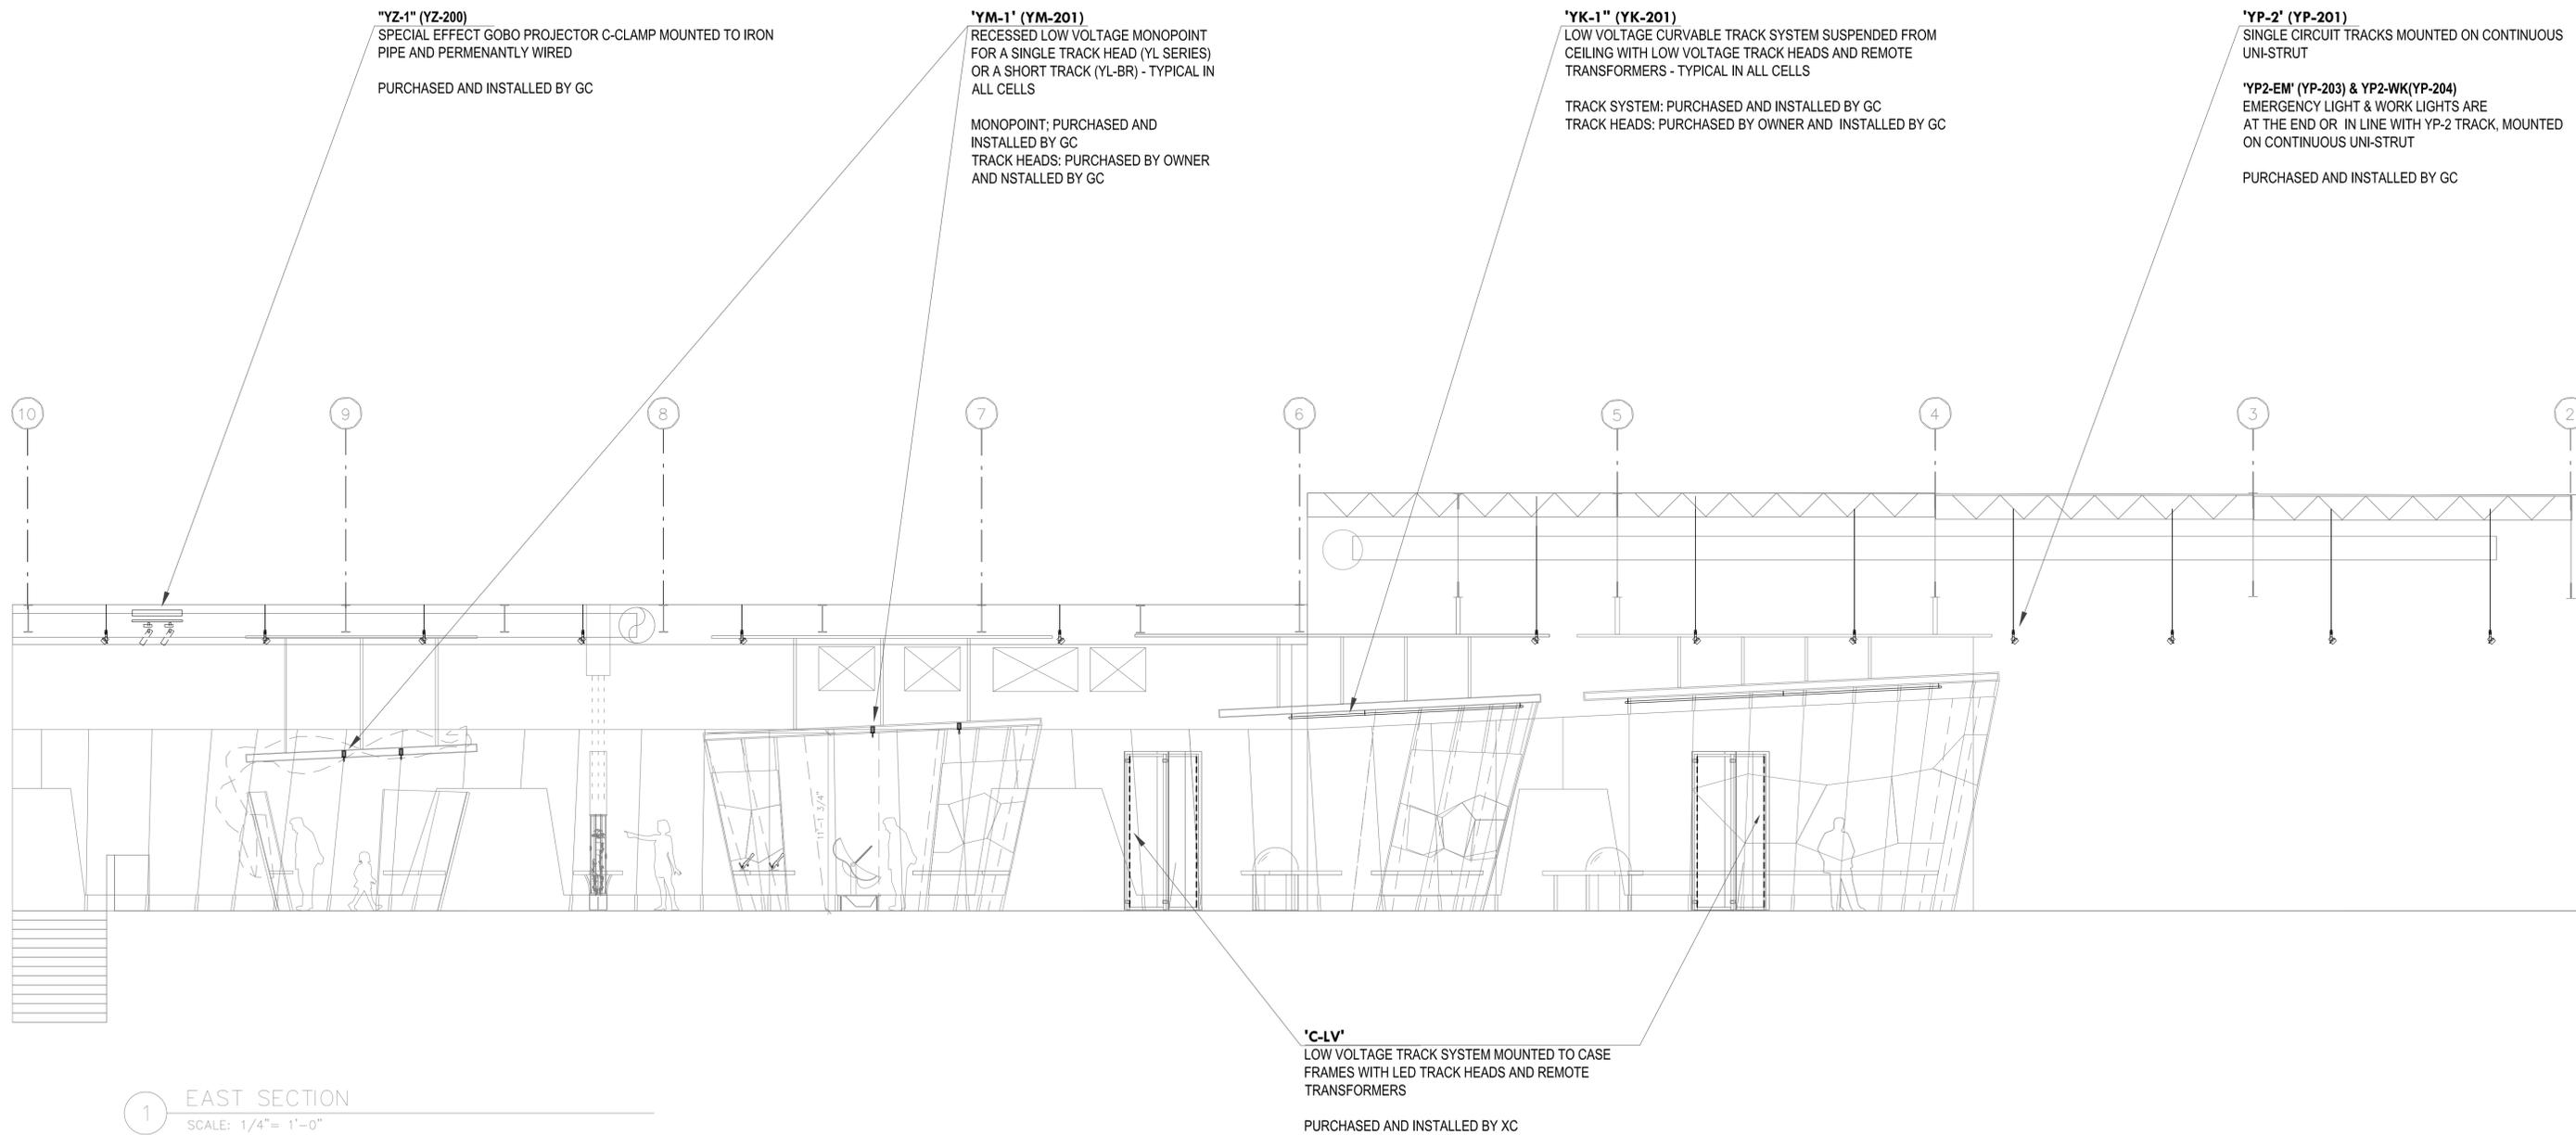


UTAH MUSEUM OF NATURAL HISTORY

UNIVERSITY OF UTAH, SALT LAKE CITY, UTAH

Owner UMNH 1300 East President's Circle Salt Lake City, Utah 84112 801.581.6927 tel.	Design Architect Polshak Partnership Architects LLP 320 West 13th Street New York, New York 212.807.7171 tel.	Architect of Record Gensler 375 West 200 South Salt Lake City, Utah 801.521.8600 tel.	Structural Engineer Leslie E. Robertson Associates 30 Broad Street New York, New York 10004 212.750.9000 tel.	Mechanical/Plumbing/Fire Protection Eggen Engineering Associates, Inc. 244 West 300 North Salt Lake City, Utah 84103 801.322.2400 tel.	Electrical/AV Engineer Spectrum Engineers 175 South Main Street Salt Lake City, Utah 84111 800.678.7077 tel.	Landscape Architect Design Workshop, Inc. 1796 Prospector Avenue Park City, Utah 84060 435.655.0915 tel.	Exhibition Planner and Brandenburg Associates 88 Pine Street New York, New York 10005 212.334.8200 tel.	Lighting Designer Brandston Partnership Inc 122 West 26th Street New York, New York 10001 212.924.4050 tel.
---	--	--	--	---	---	---	--	--

Exhibit Construction

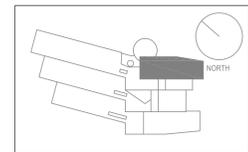

Key Plan

80% FD	Dec. 19, 2008
100% DD	June 2, 2008
XG 60% CD	May 5, 2008
WS9	March 26, 2008
WS8	Feb. 20, 2008
WS7	Dec. 18, 2007
50% DD	Sept. 18, 2007
WS6	July 11, 2007
WS5	May 23, 2007
WS4	April 12, 2007


No. / Issue Name / Date

No. / Issue Name / Date

Sheet Title
Sections & Elevations
Life Observatory

Date Dec. 19, 2008	Project No. 0275
Scale* 1/4"=1'-0"	Sheet No. LX4-LF-2.00

*Note: Scale Given for Full Size Drawing Sheet (22" x 34")

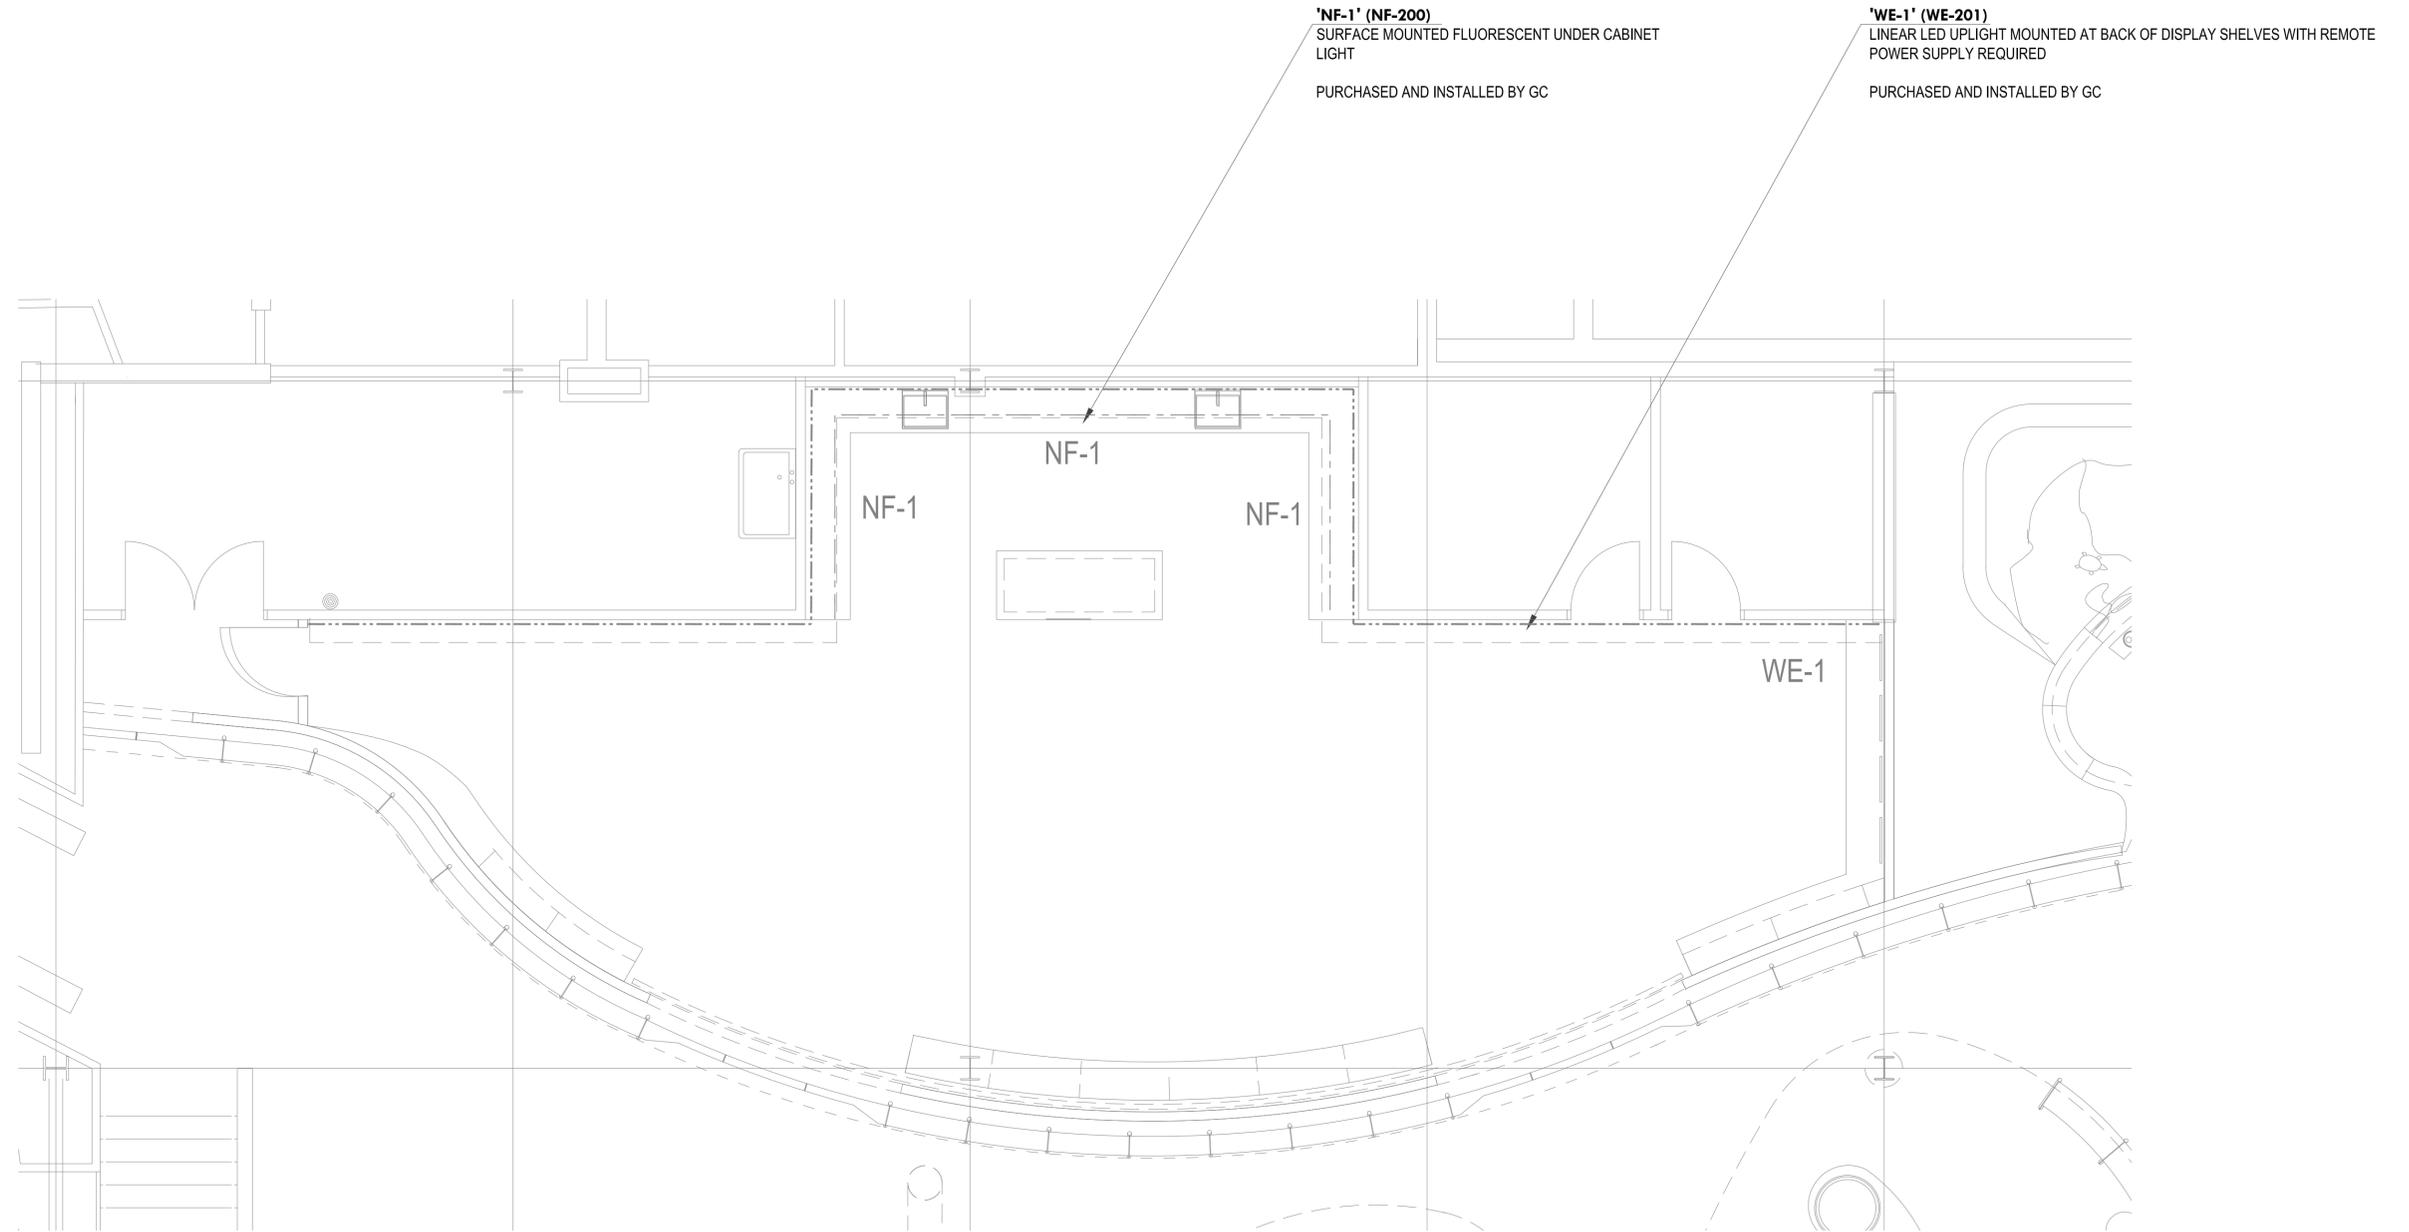


UTAH MUSEUM OF NATURAL HISTORY

UNIVERSITY OF UTAH, SALT LAKE CITY, UTAH

Owner UMNH 1300 East President's Circle Salt Lake City, Utah 84112 801.581.6927 tel.	Design Architect Polshak Partnership Architects LLP 320 West 13th Street New York, New York 212.807.7171 tel.	Architect of Record Giffels Strinsky Brems Smith 375 West 200 South Salt Lake City, Utah 801.521.8600 tel.	Structural Engineer Leslie E. Robertson Associates 30 Broad Street New York, New York 10004 212.750.9000 tel.	Mechanical/Plumbing/Fire Protection Cajigas Engineering Associates, Inc. 244 West 300 North Salt Lake City, Utah 84103 801.322.2400 tel.	Electrical/AV Engineer Spectrum Engineers 175 South Main Street Salt Lake City, Utah 84111 800.678.7077 tel.	Landscape Architect Design Workshop, Inc. 1796 Prospector Avenue Park City, Utah 84060 435.655.0915 tel.	Exhibition Planner and Rabin Rabinbaum Associates 88 Pine Street New York, New York 10005 212.334.8200 tel.	Lighting Designer Brandston Partnership Inc 122 West 26th Street New York, New York 10001 212.924.4050 tel.
---	--	---	--	---	---	---	--	--

Exhibit Construction

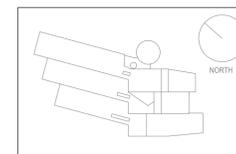

Key Plan

80% FD	Dec. 19, 2008
100% DD	June 2, 2008
XG 60% CD	May 5, 2008
WS9	March 26, 2008
WS8	Feb. 20, 2008
WS7	Dec. 18, 2007
50% DD	Sept. 18, 2007
WS6	July 11, 2007
WS5	May 23, 2007
WS4	April 12, 2007

No. / Issue Name / Date

No. / Issue Name / Date


Sheet Title
**Level 4 Partial Plan:
Naturalist Lab**

Date Dec. 19, 2008	Project No. 0275
Scale* 1/4"=1'-0"	Sheet No. LX4-NL-1.00

*Note: Scale Given for Full Size Drawing Sheet (22" x 34")

'FA-1' (FA-201)
 RECESSED LINEAR FLUORESCENT LENSED DOWNLIGHT WITH DIMMING BALLAST
 PURCHASED AND INSTALLED BY GC

'YM-1' (YM-201)
 RECESSED LOW VOLTAGE MONOPOINT FOR A SINGLE TRACK HEAD (YL SERIES) OR A SHORT TRACK (YL-BR)
 MONOPOINT; PURCHASED AND INSTALLED BY GC
 TRACK HEADS: PURCHASED BY OWNER AND INSTALLED BY GC

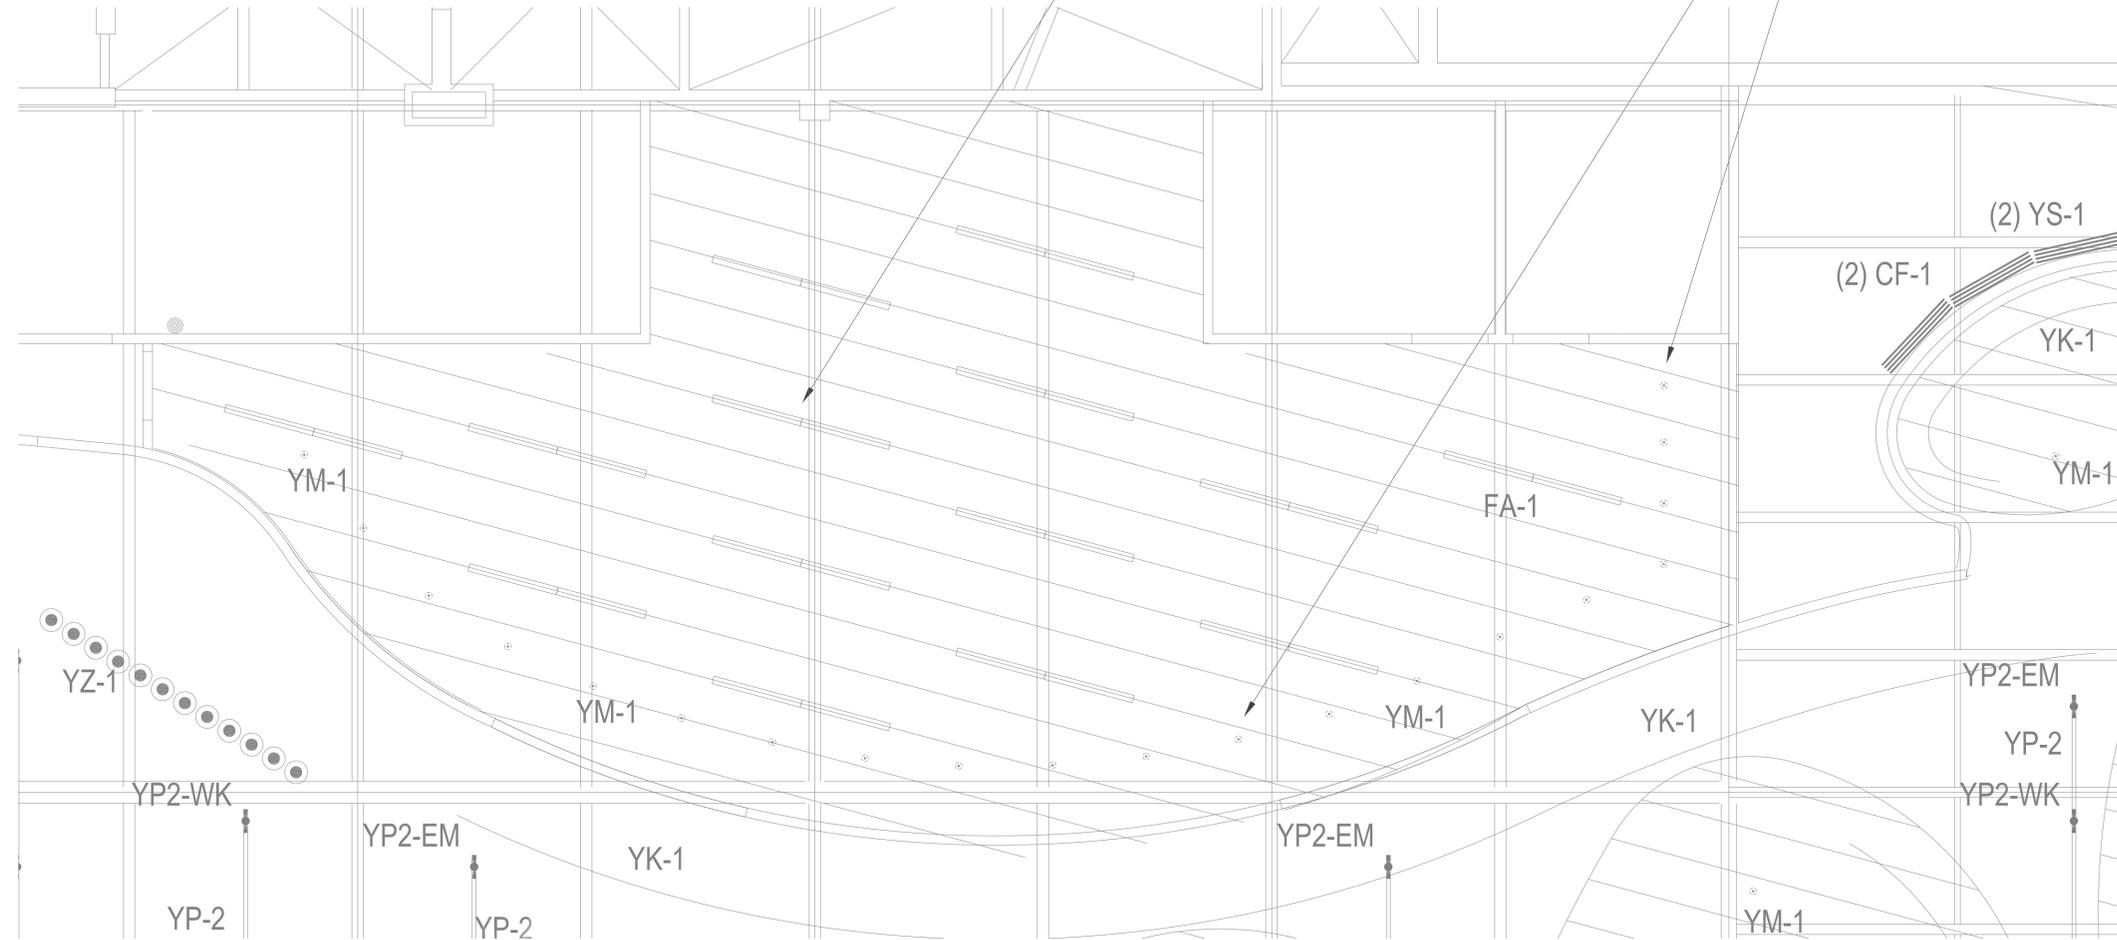


UTAH MUSEUM OF NATURAL HISTORY

UNIVERSITY OF UTAH, SALT LAKE CITY, UTAH

Exhibit Construction

Owner UMNH 1300 East President's Circle Salt Lake City, Utah 84112 801.581.6927 tel.	Design Architect Polshak Partnership Architects LLP 320 West 13th Street New York, New York 212.807.7171 tel.	Architect of Record Giles Stransky Brans Smith 375 West 200 South Salt Lake City, Utah 801.521.8600 tel.	Structural Engineer Leslie E. Robertson Associates 30 Broad Street New York, New York 10004 212.750.9000 tel.	Mechanical/Plumbing/Fire Protection Coligi Engineering Associates, Inc. 244 West 300 North Salt Lake City, Utah 84103 801.322.2400 tel.	Electrical/AV Engineer Spectrum Engineers 175 South Main Street Salt Lake City, Utah 84111 800.678.7077 tel.	Landscape Architect Design Workshop, Inc. 1796 Prospector Avenue Park City, Utah 84060 435.655.0915 tel.	Exhibition Planner and Rabin Rabinbaum Associates 88 Pine Street New York, New York 10005 212.334.8200 tel.	Lighting Designer Brandston Partnership Inc 122 West 26th Street New York, New York 10001 212.924.4050 tel.
---	--	---	--	--	---	---	--	--

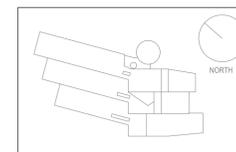

Key Plan

80% FD	Dec. 19, 2008
100% DD	June 2, 2008
XG 60% CD	May 5, 2008
WS9	March 26, 2008
WS8	Feb. 20, 2008
WS7	Dec. 18, 2007
50% DD	Sept. 18, 2007
WS6	July 11, 2007
WS5	May 23, 2007
WS4	April 12, 2007


No. / Issue Name / Date

No. / Issue Name / Date

Sheet Title
**Level 4 Partial RCP:
 Naturalist Lab**

Date Dec. 19, 2008	Project No. 0275
Scale* 1/4"=1'-0"	Sheet No. LX4-NL-1.02

*Note: Scale Given for Full Size Drawing Sheet (22" x 34")

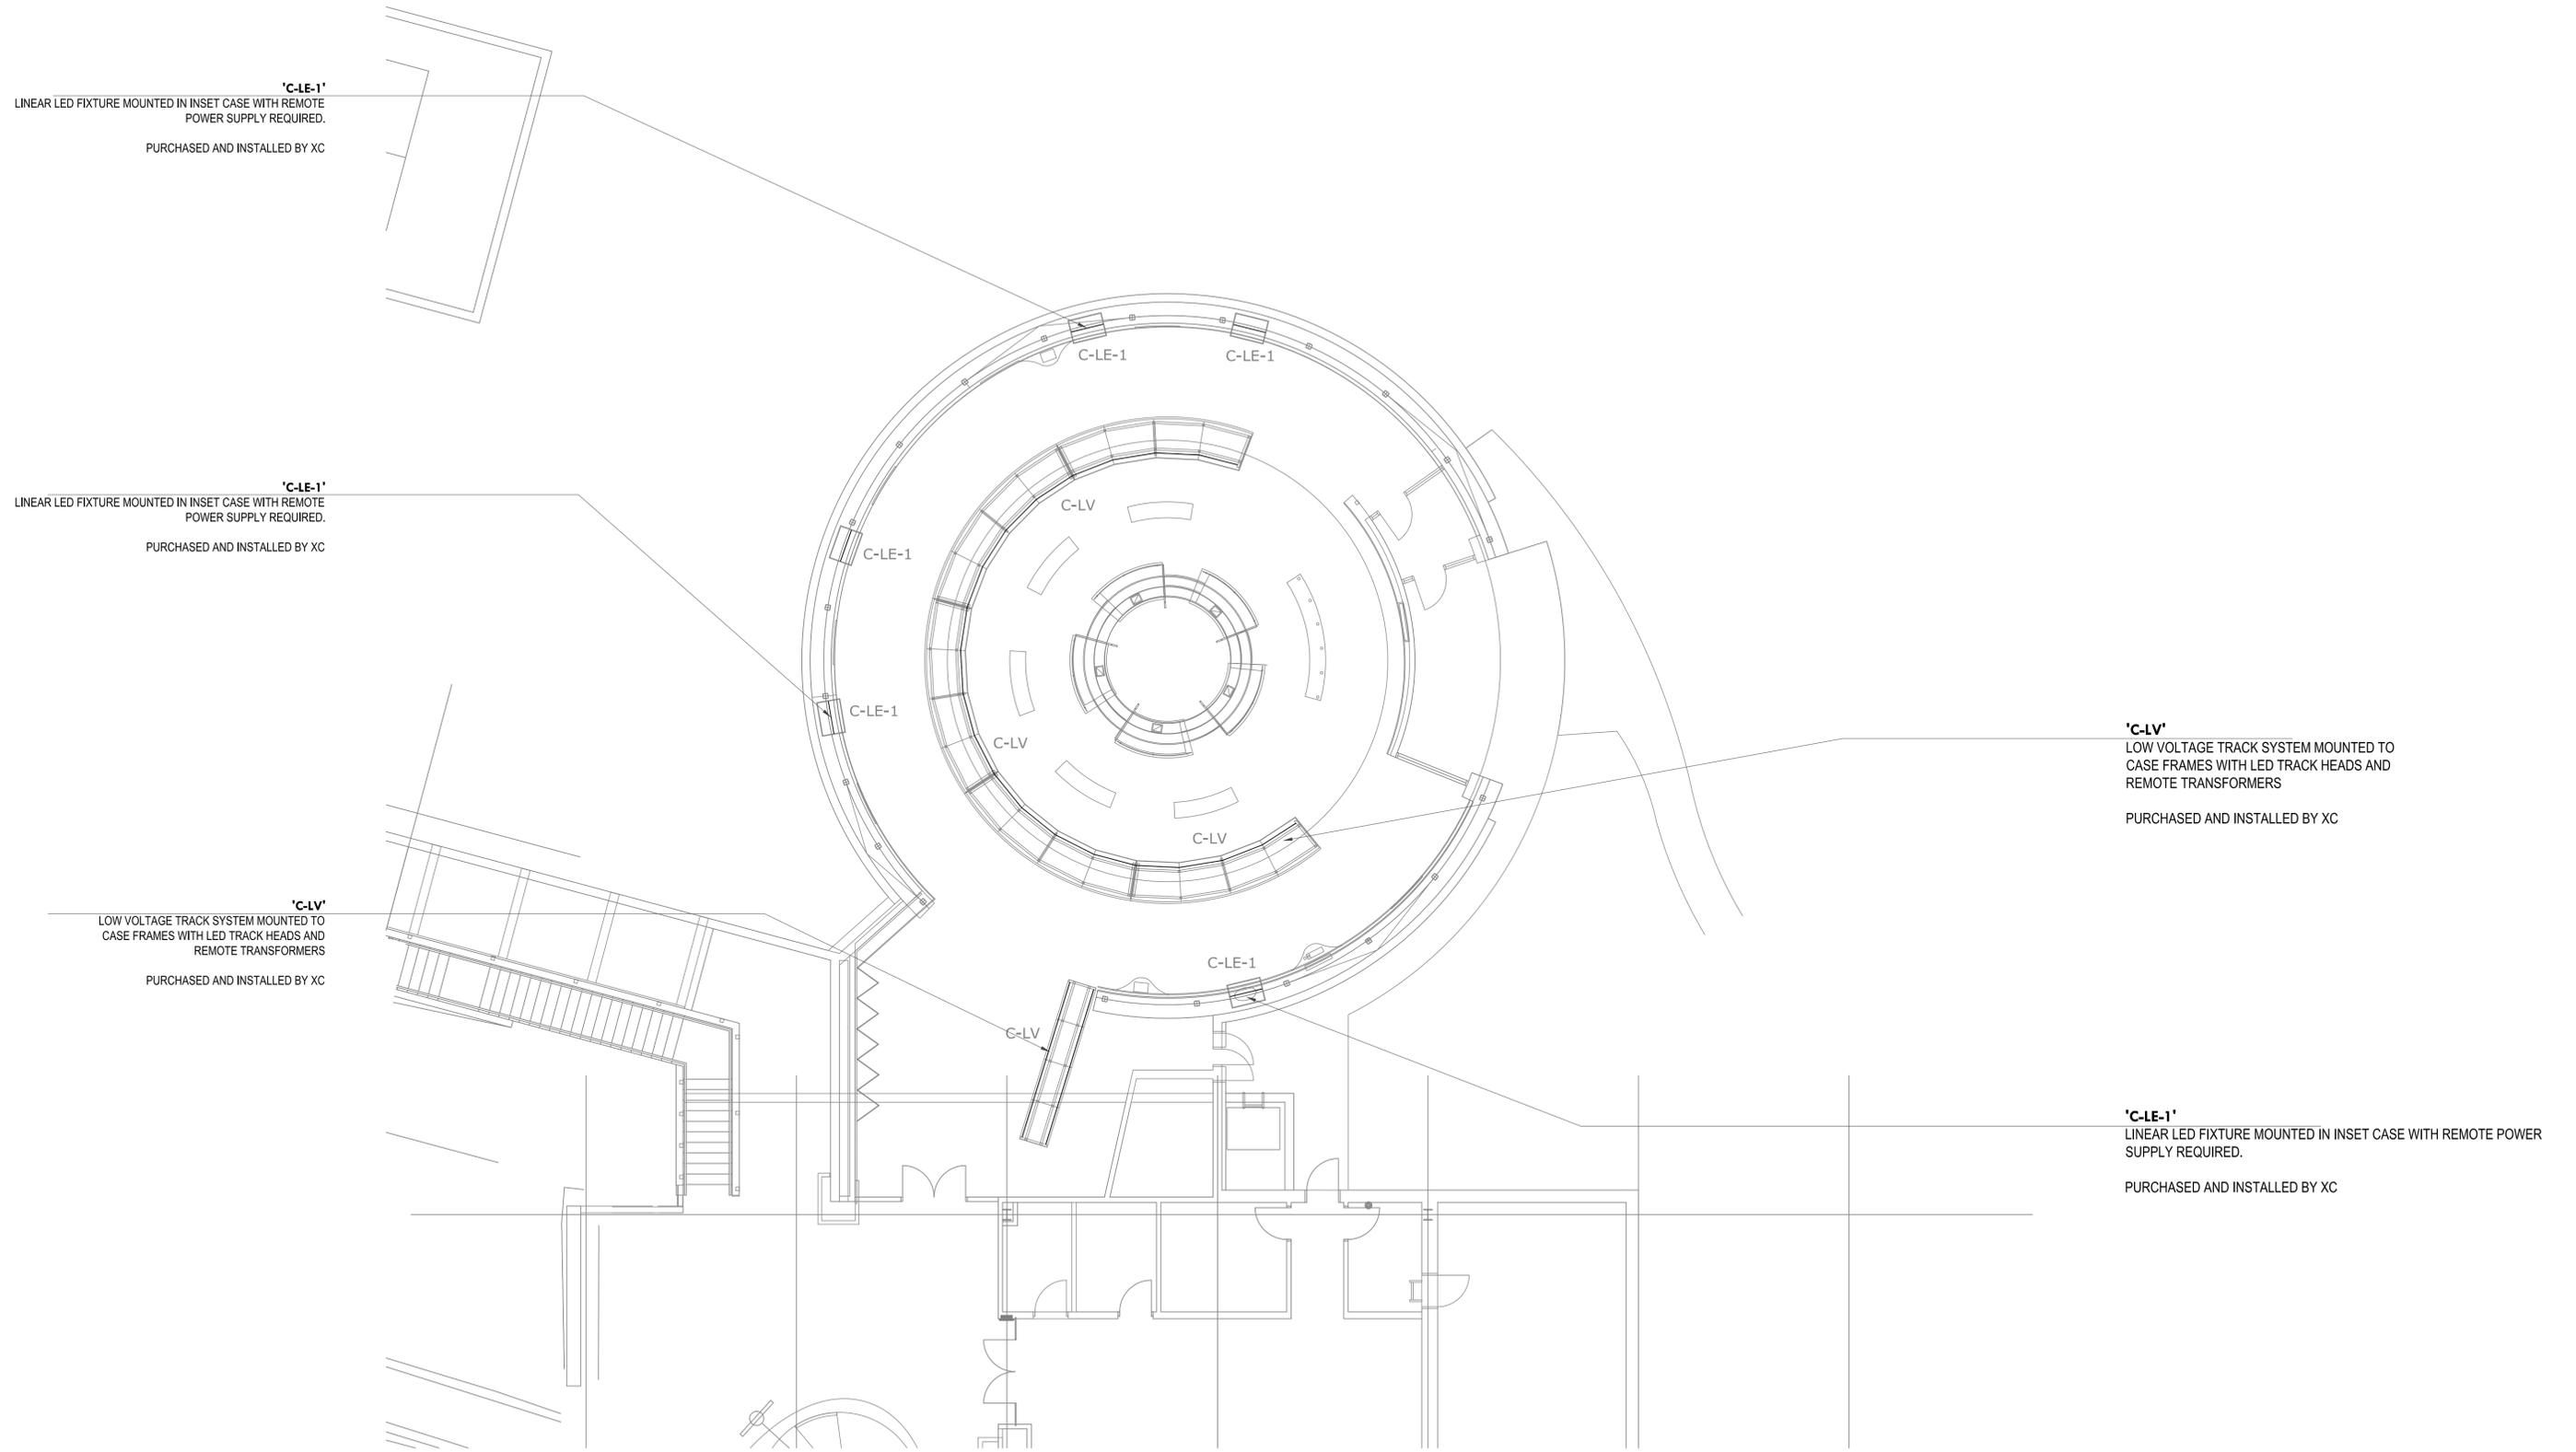


UTAH MUSEUM OF NATURAL HISTORY

UNIVERSITY OF UTAH, SALT LAKE CITY, UTAH

Exhibit Construction

Owner UMNH 1300 East President's Circle Salt Lake City, Utah 84112 801.581.6927 tel.	Design Architect Polshak Partnership Architects LLP 320 West 13th Street New York, New York 212.807.7171 tel.	Architect of Record Sofsky Architects 375 West 200 South Salt Lake City, Utah 801.521.8600 tel.	Structural Engineer Leslie E. Robertson Associates 30 Broad Street New York, New York 10004 212.750.9000 tel.	Mechanical/Plumbing/Fire Protection Engineer Edgell Engineering Associates, Inc. 244 West 300 North Salt Lake City, Utah 84103 801.322.2400 tel.	Electrical/AV Engineer Spectrum Engineers 175 South Main Street Salt Lake City, Utah 84111 800.678.7077 tel.	Landscape Architect Design Workshop, Inc. 1796 Prospector Avenue Park City, Utah 84060 435.655.0915 tel.	Exhibition Planner and Designer Rabinowitz Associates 88 Pine Street New York, New York 10005 212.334.8200 tel.	Lighting Designer Brandston Partnership Inc 122 West 26th Street New York, New York 10001 212.924.4050 tel.
---	--	--	--	---	---	---	--	--

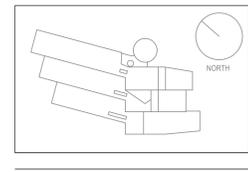

Key Plan


80% FD	Dec. 19, 2008
100% DD	June 2, 2008
XG 60% CD	May 5, 2008
WS9	March 26, 2008
WS8	Feb. 20, 2008
WS7	Dec. 18, 2007
50% DD	Sept. 18, 2007
WS6	July 11, 2007
WS5	May 23, 2007
WS4	April 12, 2007

No. / Issue Name / Date

No. / Issue Name / Date

Sheet Title	
Level 5 Partial Plan: Native Voices Observatory	
Date	Project No.
Dec. 19, 2008	0275
Scale*	Sheet No.
1/8"=1'-0"	LX5-NV-1.00

*Note: Scale Given for Full Size Drawing Sheet (22" x 34")

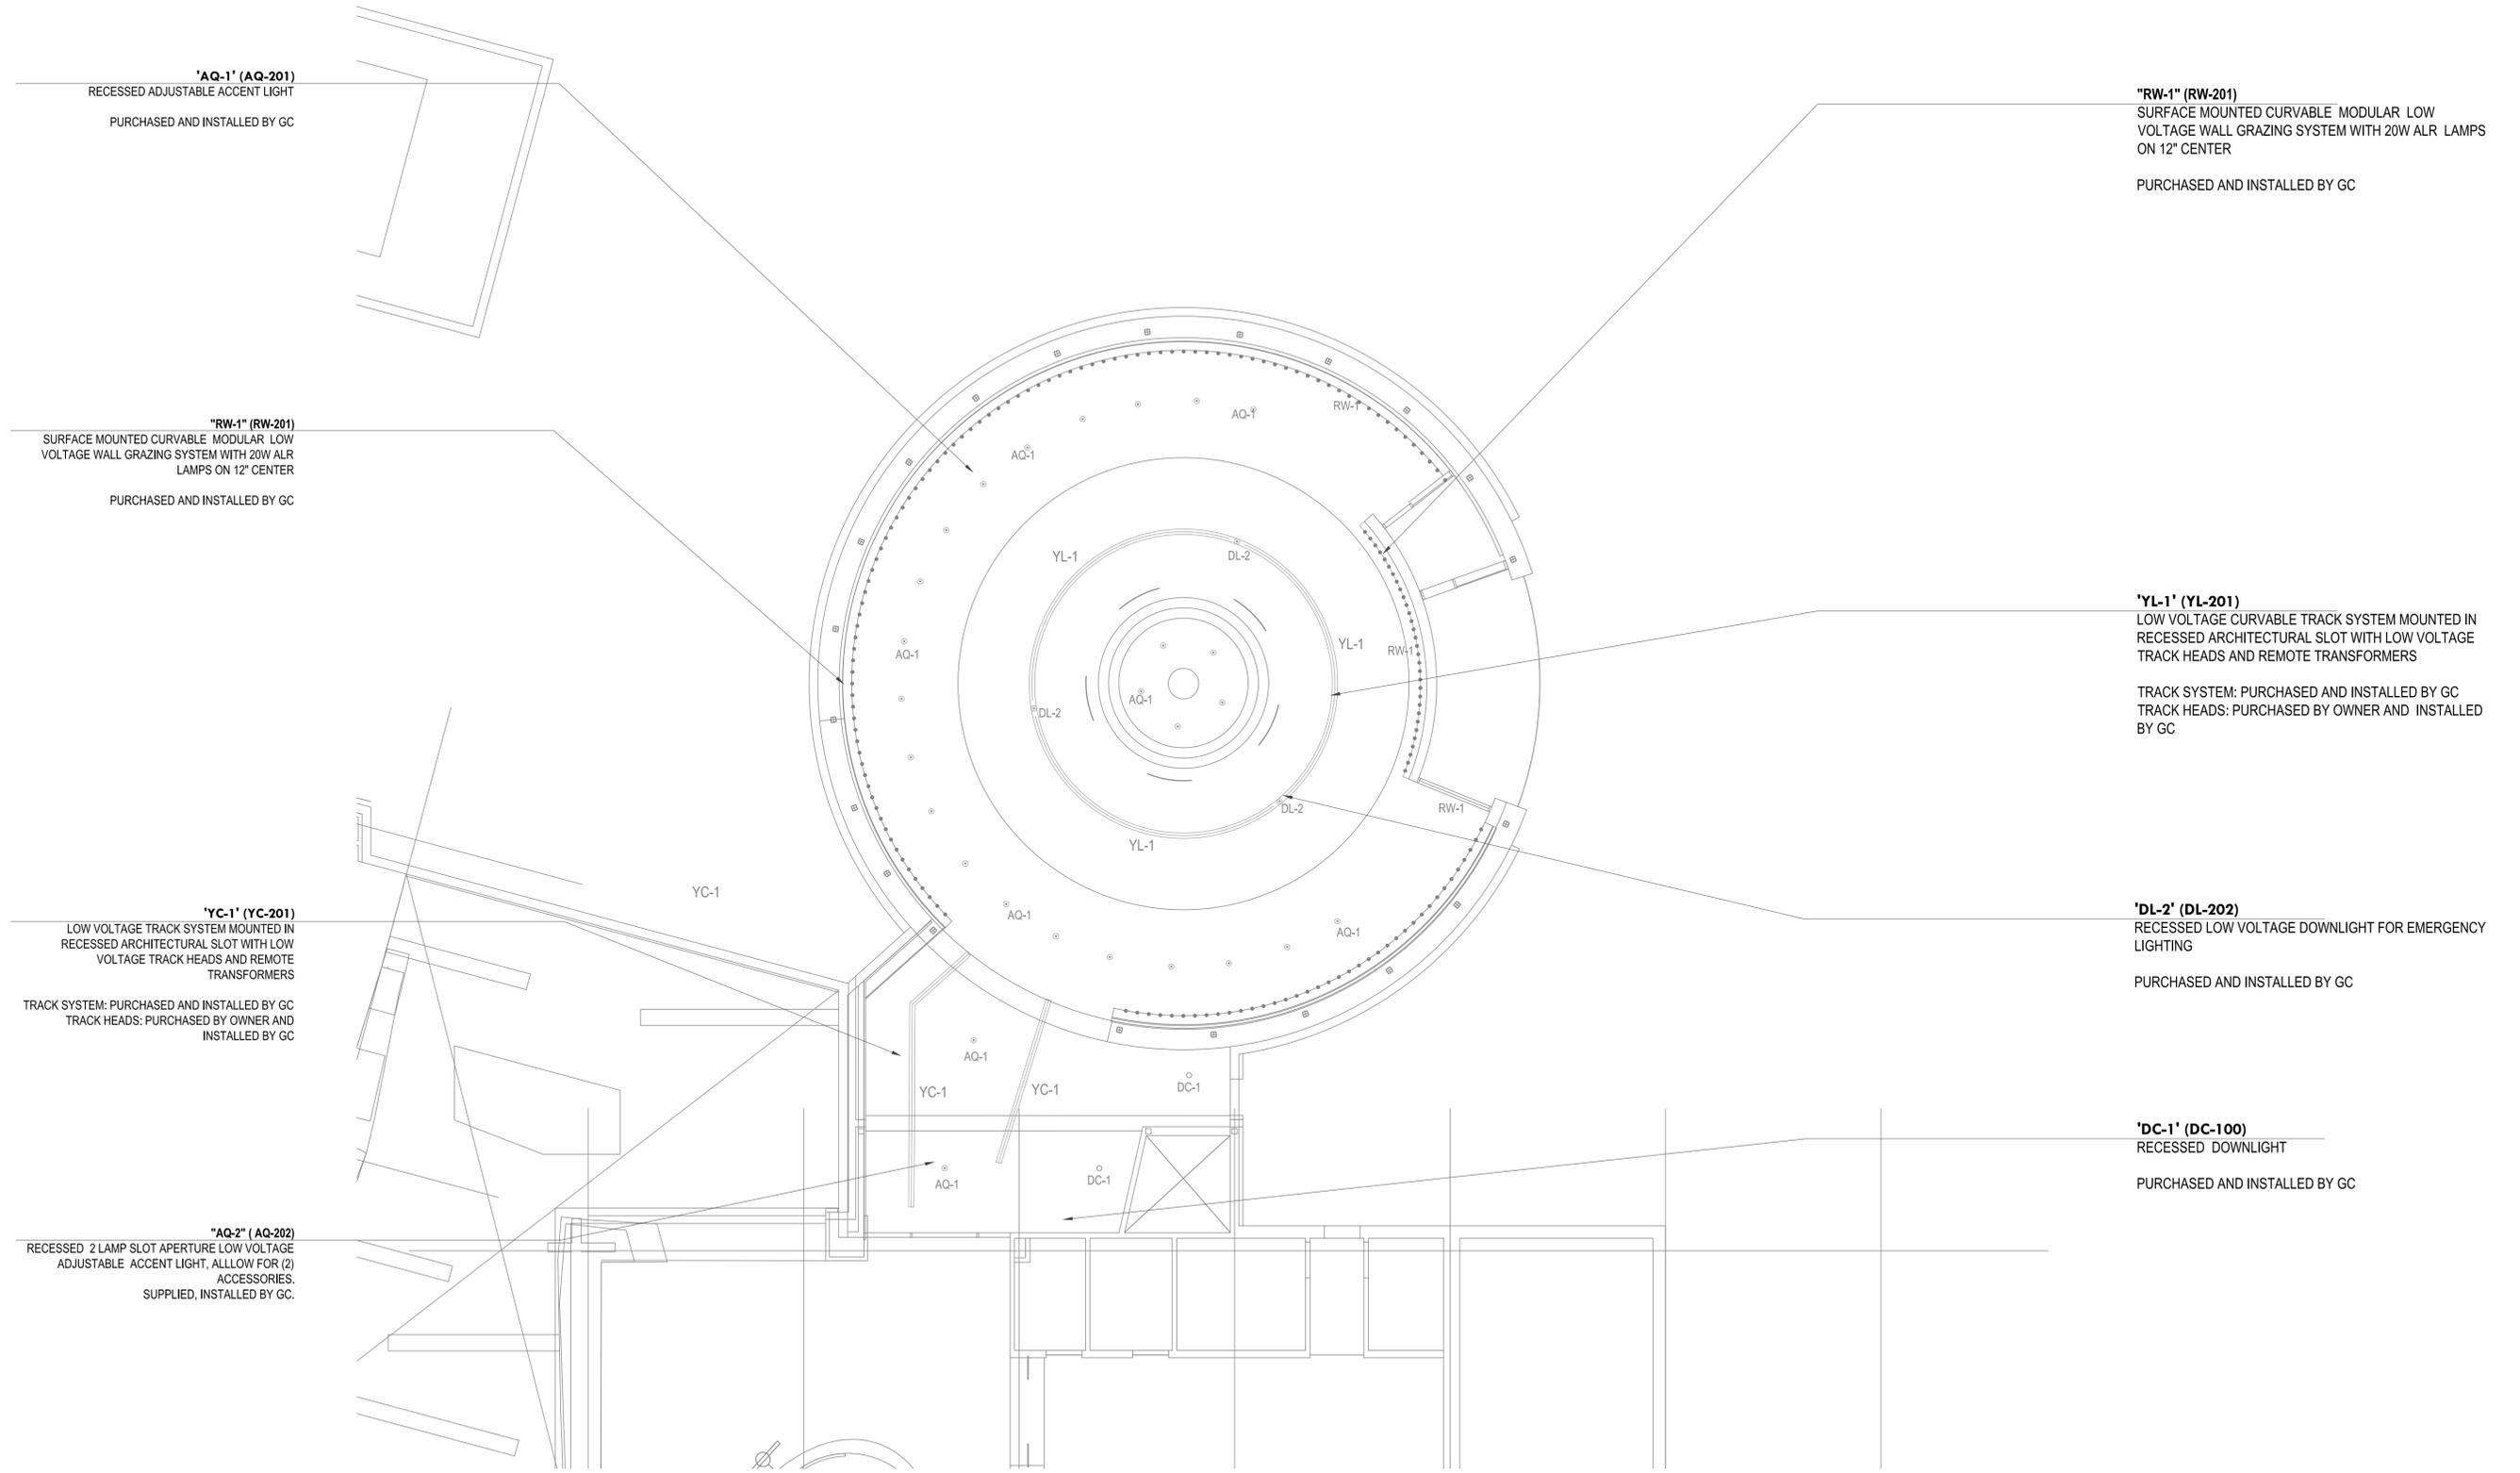

'AQ-1' (AQ-201)
RECESSED ADJUSTABLE ACCENT LIGHT
PURCHASED AND INSTALLED BY GC

"RW-1" (RW-201)
SURFACE MOUNTED CURVABLE MODULAR LOW VOLTAGE WALL GRAZING SYSTEM WITH 20W ALR LAMPS ON 12" CENTER
PURCHASED AND INSTALLED BY GC

"RW-1" (RW-201)
SURFACE MOUNTED CURVABLE MODULAR LOW VOLTAGE WALL GRAZING SYSTEM WITH 20W ALR LAMPS ON 12" CENTER
PURCHASED AND INSTALLED BY GC

'YL-1' (YL-201)
LOW VOLTAGE CURVABLE TRACK SYSTEM MOUNTED IN RECESSED ARCHITECTURAL SLOT WITH LOW VOLTAGE TRACK HEADS AND REMOTE TRANSFORMERS
TRACK SYSTEM: PURCHASED AND INSTALLED BY GC
TRACK HEADS: PURCHASED BY OWNER AND INSTALLED BY GC

'YC-1' (YC-201)
LOW VOLTAGE TRACK SYSTEM MOUNTED IN RECESSED ARCHITECTURAL SLOT WITH LOW VOLTAGE TRACK HEADS AND REMOTE TRANSFORMERS
TRACK SYSTEM: PURCHASED AND INSTALLED BY GC
TRACK HEADS: PURCHASED BY OWNER AND INSTALLED BY GC

'DL-2' (DL-202)
RECESSED LOW VOLTAGE DOWNLIGHT FOR EMERGENCY LIGHTING
PURCHASED AND INSTALLED BY GC

"AQ-2" (AQ-202)
RECESSED 2 LAMP SLOT APERTURE LOW VOLTAGE ADJUSTABLE ACCENT LIGHT, ALLOW FOR (2) ACCESSORIES.
SUPPLIED, INSTALLED BY GC.


'DC-1' (DC-100)
RECESSED DOWNLIGHT
PURCHASED AND INSTALLED BY GC

UTAH MUSEUM OF NATURAL HISTORY

UNIVERSITY OF UTAH, SALT LAKE CITY, UTAH

Exhibit Construction

Owner UMNH 1300 East President's Circle Salt Lake City, Utah 84112 801.581.6927 tel.	Design Architect Polshak Partnership Architects LLP 320 West 13th Street New York, New York 212.807.7171 tel.	Architect of Record Grisman Brady Architects 375 West 200 South Salt Lake City, Utah 801.521.8600 tel.	Structural Engineer Leslie E. Robertson Associates 30 Broad Street New York, New York 10004 212.750.9000 tel.	Mechanical/Plumbing/Fire Protection Edgell Engineering Associates, Inc. 244 West 300 North Salt Lake City, Utah 84103 801.322.2400 tel.	Electrical/AV Engineer Spectrum Engineers 175 South Main Street Salt Lake City, Utah 84111 800.678.7077 tel.	Landscape Architect Design Workshop, Inc. 1796 Prospector Avenue Park City, Utah 84060 435.655.0915 tel.	Exhibition Planner and Brandenburg Associates 88 Pine Street New York, New York 10005 212.334.8200 tel.	Lighting Designer Brandston Partnership Inc 122 West 26th Street New York, New York 10001 212.924.4050 tel.
--	---	--	---	---	--	--	---	---

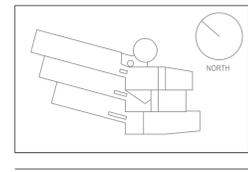

Key Plan

80% FD	Dec. 19, 2008
100% DD	June 2, 2008
XG 60% CD	May 5, 2008
WS9	March 26, 2008
WS8	Feb. 20, 2008
WS7	Dec. 18, 2007
50% DD	Sept. 18, 2007
WS6	July 11, 2007
WS5	May 23, 2007
WS4	April 12, 2007


No. / Issue Name / Date

Sheet Title	Level 5 Partial RCP: Native Voices Observatory
Date	Dec. 19, 2008
Scale*	1/8"=1'-0"

No. / Issue Name / Date


Project No.	0275
Sheet No.	LX5-NV-1.02

*Note: Scale Given for Full Size Drawing Sheet (22" x 34")

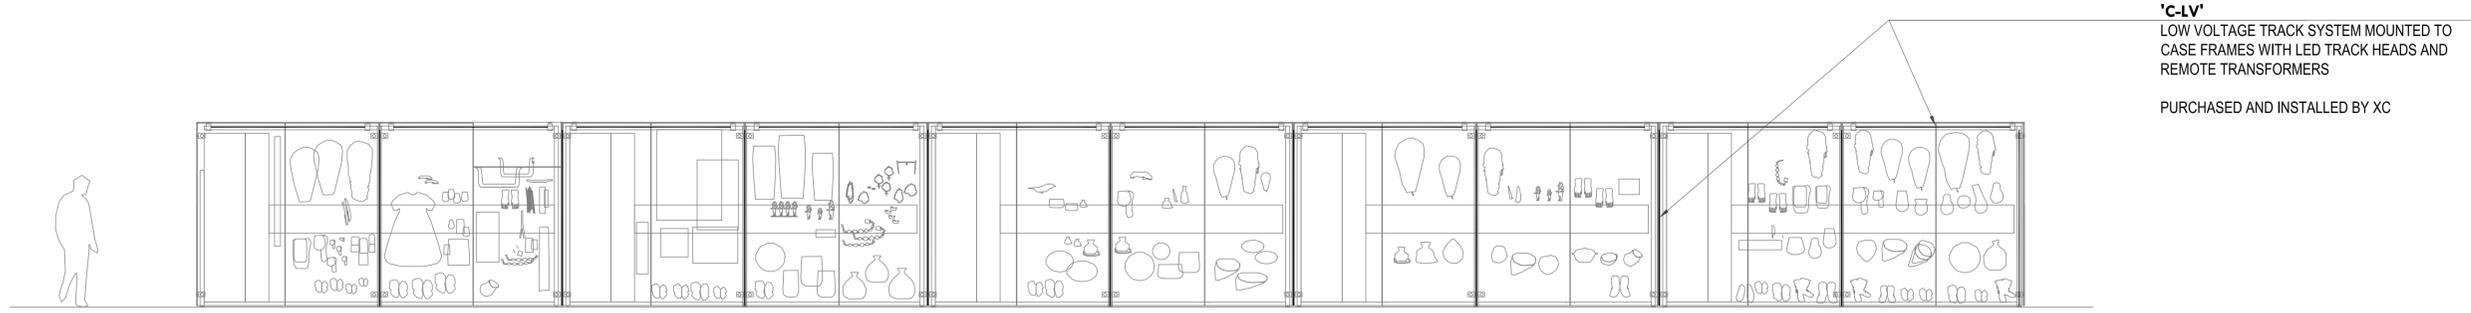

'C-LV'
 LOW VOLTAGE TRACK SYSTEM MOUNTED TO CASE FRAMES WITH LED TRACK HEADS AND REMOTE TRANSFORMERS
 PURCHASED AND INSTALLED BY XC


1 DEVELOPED ELEVATION: EXHIBIT CASES
 SCALE: 1/4" = 1'-0"

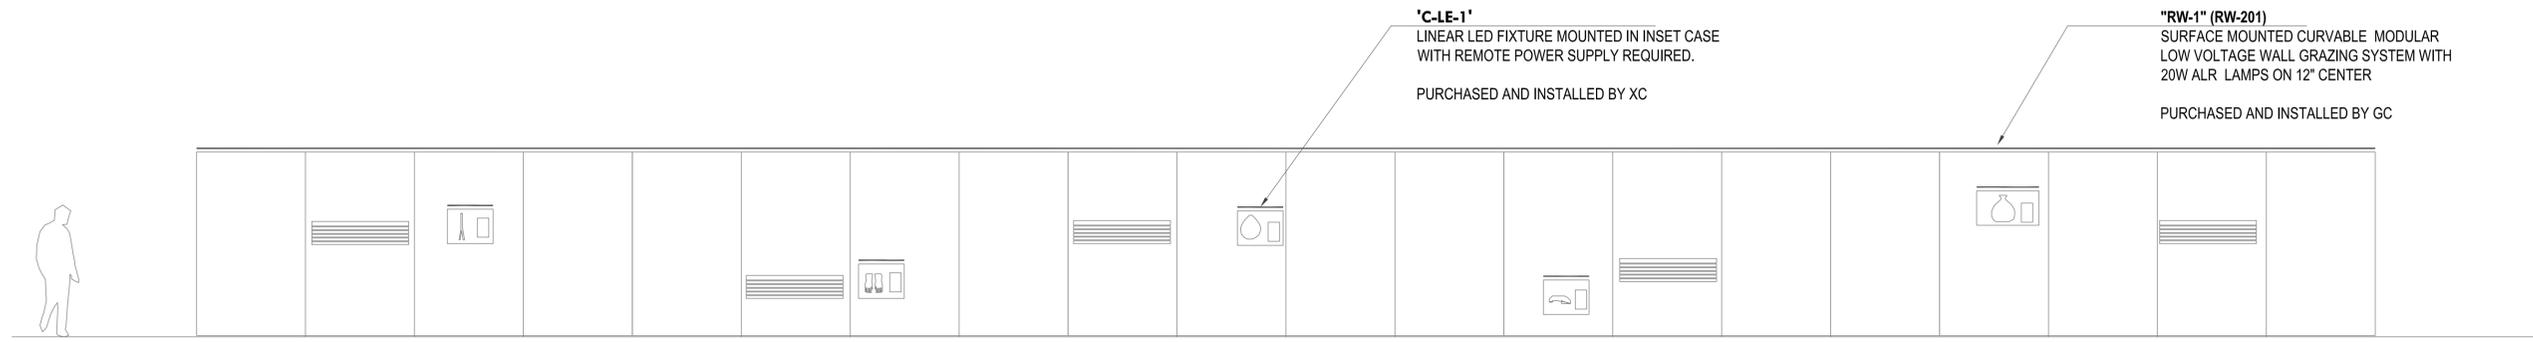

'C-LE-1'
 LINEAR LED FIXTURE MOUNTED IN INSET CASE WITH REMOTE POWER SUPPLY REQUIRED.
 PURCHASED AND INSTALLED BY XC

'RW-1' (RW-201)
 SURFACE MOUNTED CURVABLE MODULAR LOW VOLTAGE WALL GRAZING SYSTEM WITH 20W ALR LAMPS ON 12" CENTER
 PURCHASED AND INSTALLED BY GC

2 DEVELOPED ELEVATION: HOMELAND PHOTOMURAL
 SCALE: 1/4" = 1'-0"

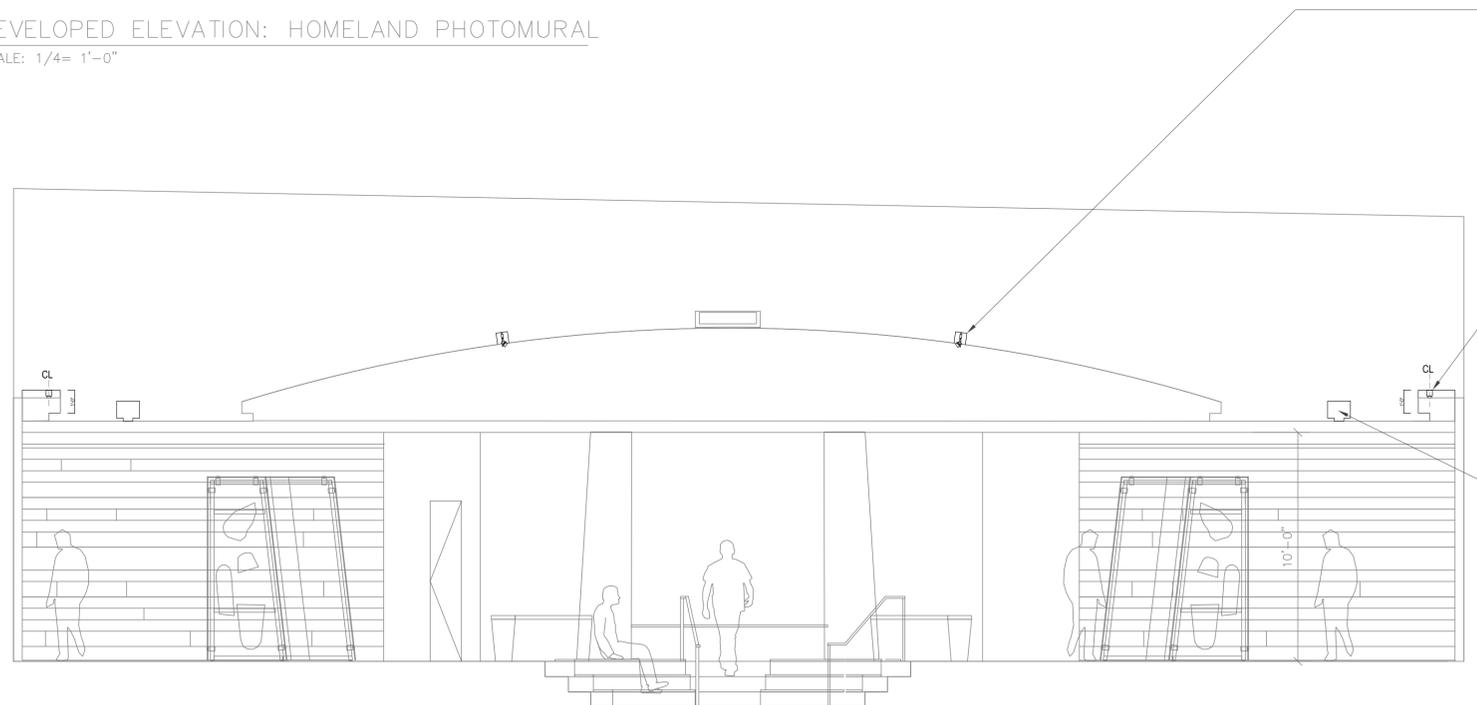

'YL-1' (YL-201)
 LOW VOLTAGE CURVABLE TRACK SYSTEM MOUNTED IN RECESSED ARCHITECTURAL SLOT WITH LOW VOLTAGE TRACK HEADS AND REMOTE TRANSFORMERS
 TRACK SYSTEM: PURCHASED AND INSTALLED BY GC
 TRACK HEADS: PURCHASED BY OWNER AND INSTALLED BY GC

'RW-1' (RW-201)
 SURFACE MOUNTED CURVABLE MODULAR LOW VOLTAGE WALL GRAZING SYSTEM WITH 20W ALR LAMPS ON 12" CENTER
 PURCHASED AND INSTALLED BY GC

'AQ-1' (AQ-201)
 RECESSED ADJUSTABLE ACCENT LIGHT
 PURCHASED AND INSTALLED BY GC


3 SECTION: STORYTELLING
 SCALE: 1/4" = 1'-0"

UTAH MUSEUM OF NATURAL HISTORY

UNIVERSITY OF UTAH, SALT LAKE CITY, UTAH

Owner UMNH 1300 East President's Circle Salt Lake City, Utah 84112 801.581.6927 tel.	Design Architect Polshak Partnership Architects LLP 320 West 13th Street New York, New York 212.807.7171 tel.	Architect of Record RCS Architects 375 West 200 South Salt Lake City, Utah 801.521.8600 tel.	Structural Engineer Leslie E. Robertson Associates 30 Broad Street New York, New York 10004 212.750.9000 tel.	Mechanical/Plumbing/Fire Protection Edgell Engineering Associates, Inc. 244 West 300 North Salt Lake City, Utah 84103 801.322.2400 tel.	Electrical/AV Engineer Spectrum Engineers 175 South Main Street Salt Lake City, Utah 84111 800.678.7077 tel.	Landscape Architect Design Workshop, Inc. 1796 Prospector Avenue Park City, Utah 84060 435.655.0915 tel.	Exhibition Planner and Rabinowitz & Baum Associates 88 Pine Street New York, New York 10005 212.334.8200 tel.	Lighting Designer Brandston Partnership Inc 122 West 26th Street New York, New York 10001 212.924.4050 tel.
--	---	--	---	---	--	--	---	---

Exhibit Construction

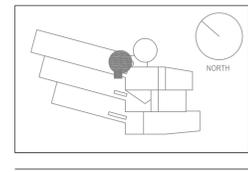

Key Plan


80% FD	Dec. 19, 2008
100% DD	June 2, 2008
XG 60% CD	May 5, 2008
WS9	March 26, 2008
WS8	Feb. 20, 2008
WS7	Dec. 18, 2007
50% DD	Sept. 18, 2007
WS6	July 11, 2007
WS5	May 23, 2007
WS4	April 12, 2007

No. / Issue Name / Date

No. / Issue Name / Date

Sheet Title	
Sections & Elevations: Native Voices Observatory	
Date	Project No.
Dec. 19, 2008	0275
Scale*	Sheet No.
1/4"=1'-0"	LX5-NV-2.01

*Note: Scale Given for Full Size Drawing Sheet (22" x 34")

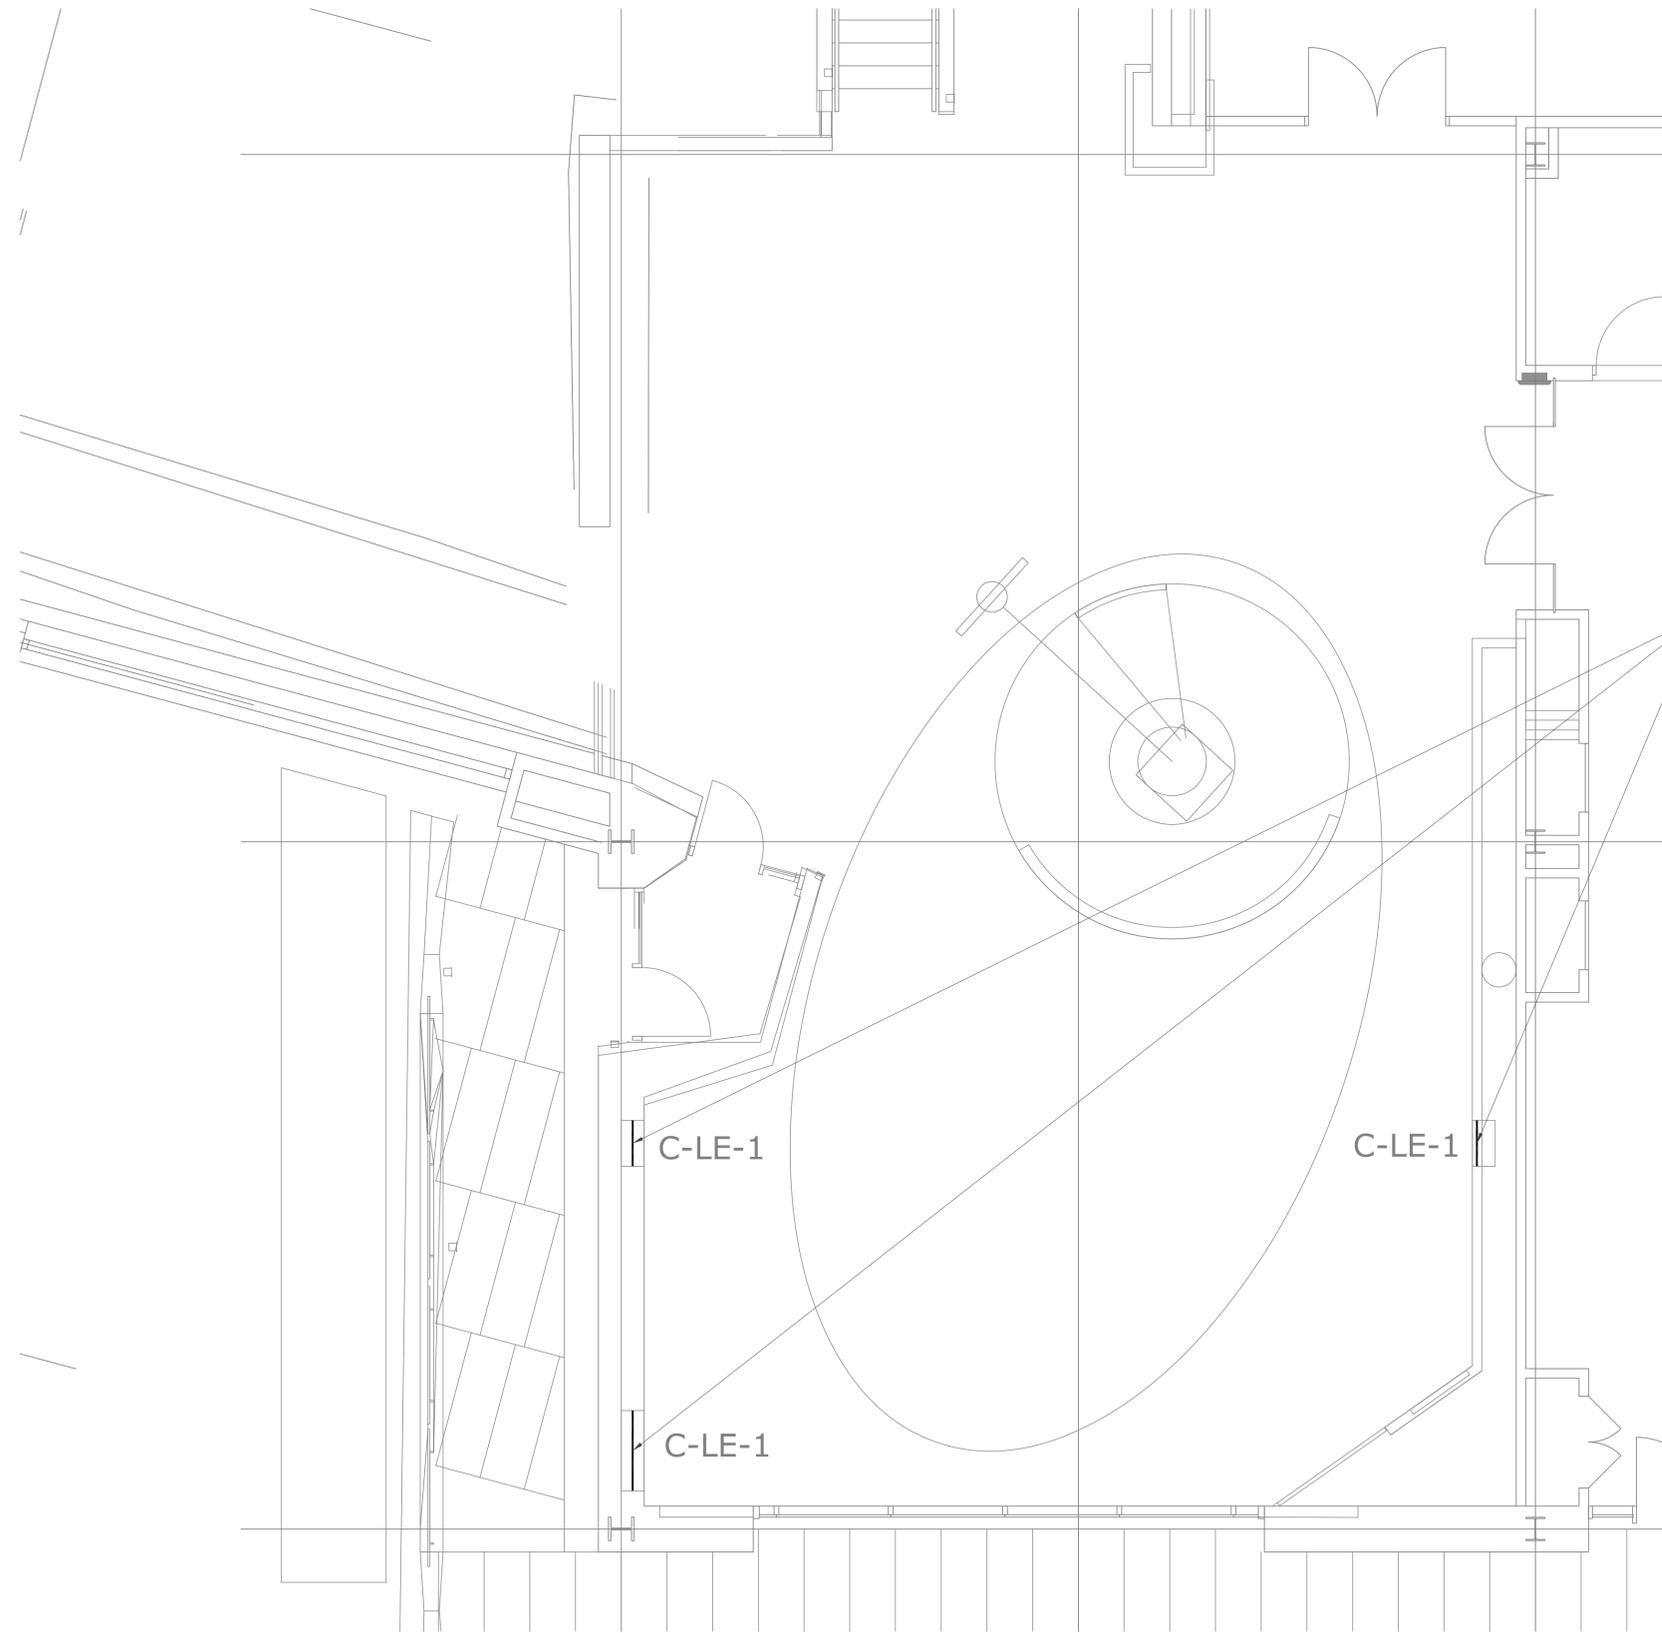


UTAH MUSEUM OF NATURAL HISTORY

UNIVERSITY OF UTAH, SALT LAKE CITY, UTAH

Exhibit Construction

<p>Owner UMNH 1300 East President's Circle Salt Lake City, Utah 84112 801.581.6927 tel.</p>	<p>Design Architect Polshak Partnership Architects LLP 320 West 13th Street New York, New York 212.807.7171 tel.</p>	<p>Architect of Record Sternberg Architects 375 West 200 South Salt Lake City, Utah 801.521.8600 tel.</p>	<p>Structural Engineer Leslie E. Robertson Associates 30 Broad Street New York, New York 10004 212.750.9000 tel.</p>	<p>Mechanical/Plumbing/Fire Protection Cognit Engineering Associates, Inc. 244 West 300 North Salt Lake City, Utah 84103 801.322.2400 tel.</p>	<p>Electrical/AV Engineer Spectrum Engineers 175 South Main Street Salt Lake City, Utah 84111 800.678.7077 tel.</p>	<p>Landscape Architect Design Workshop, Inc. 1796 Prospector Avenue Park City, Utah 84060 435.655.0915 tel.</p>	<p>Exhibition Planner and Rabinowitz Associates 88 Pine Street New York, New York 10005 212.334.8200 tel.</p>	<p>Lighting Designer Brandston Partnership Inc 122 West 26th Street New York, New York 10001 212.924.4050 tel.</p>
---	--	---	--	--	---	---	---	--

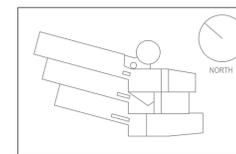

Key Plan


80% FD	Dec. 19, 2008
100% DD	June 2, 2008
XG 60% CD	May 5, 2008
WS9	March 26, 2008
WS8	Feb. 20, 2008
WS7	Dec. 18, 2007
50% DD	Sept. 18, 2007
WS6	July 11, 2007
WS5	May 23, 2007
WS4	April 12, 2007

No. / Issue Name / Date

No. / Issue Name / Date

Sheet Title	
Level 5 Partial Plan: Sky Observatory	
Date	Project No.
Dec. 19, 2008	0275
Scale*	Sheet No.
1/4"=1'-0"	LX5-SK-1.00

*Note: Scale Given for Full Size Drawing Sheet (22" x 34")

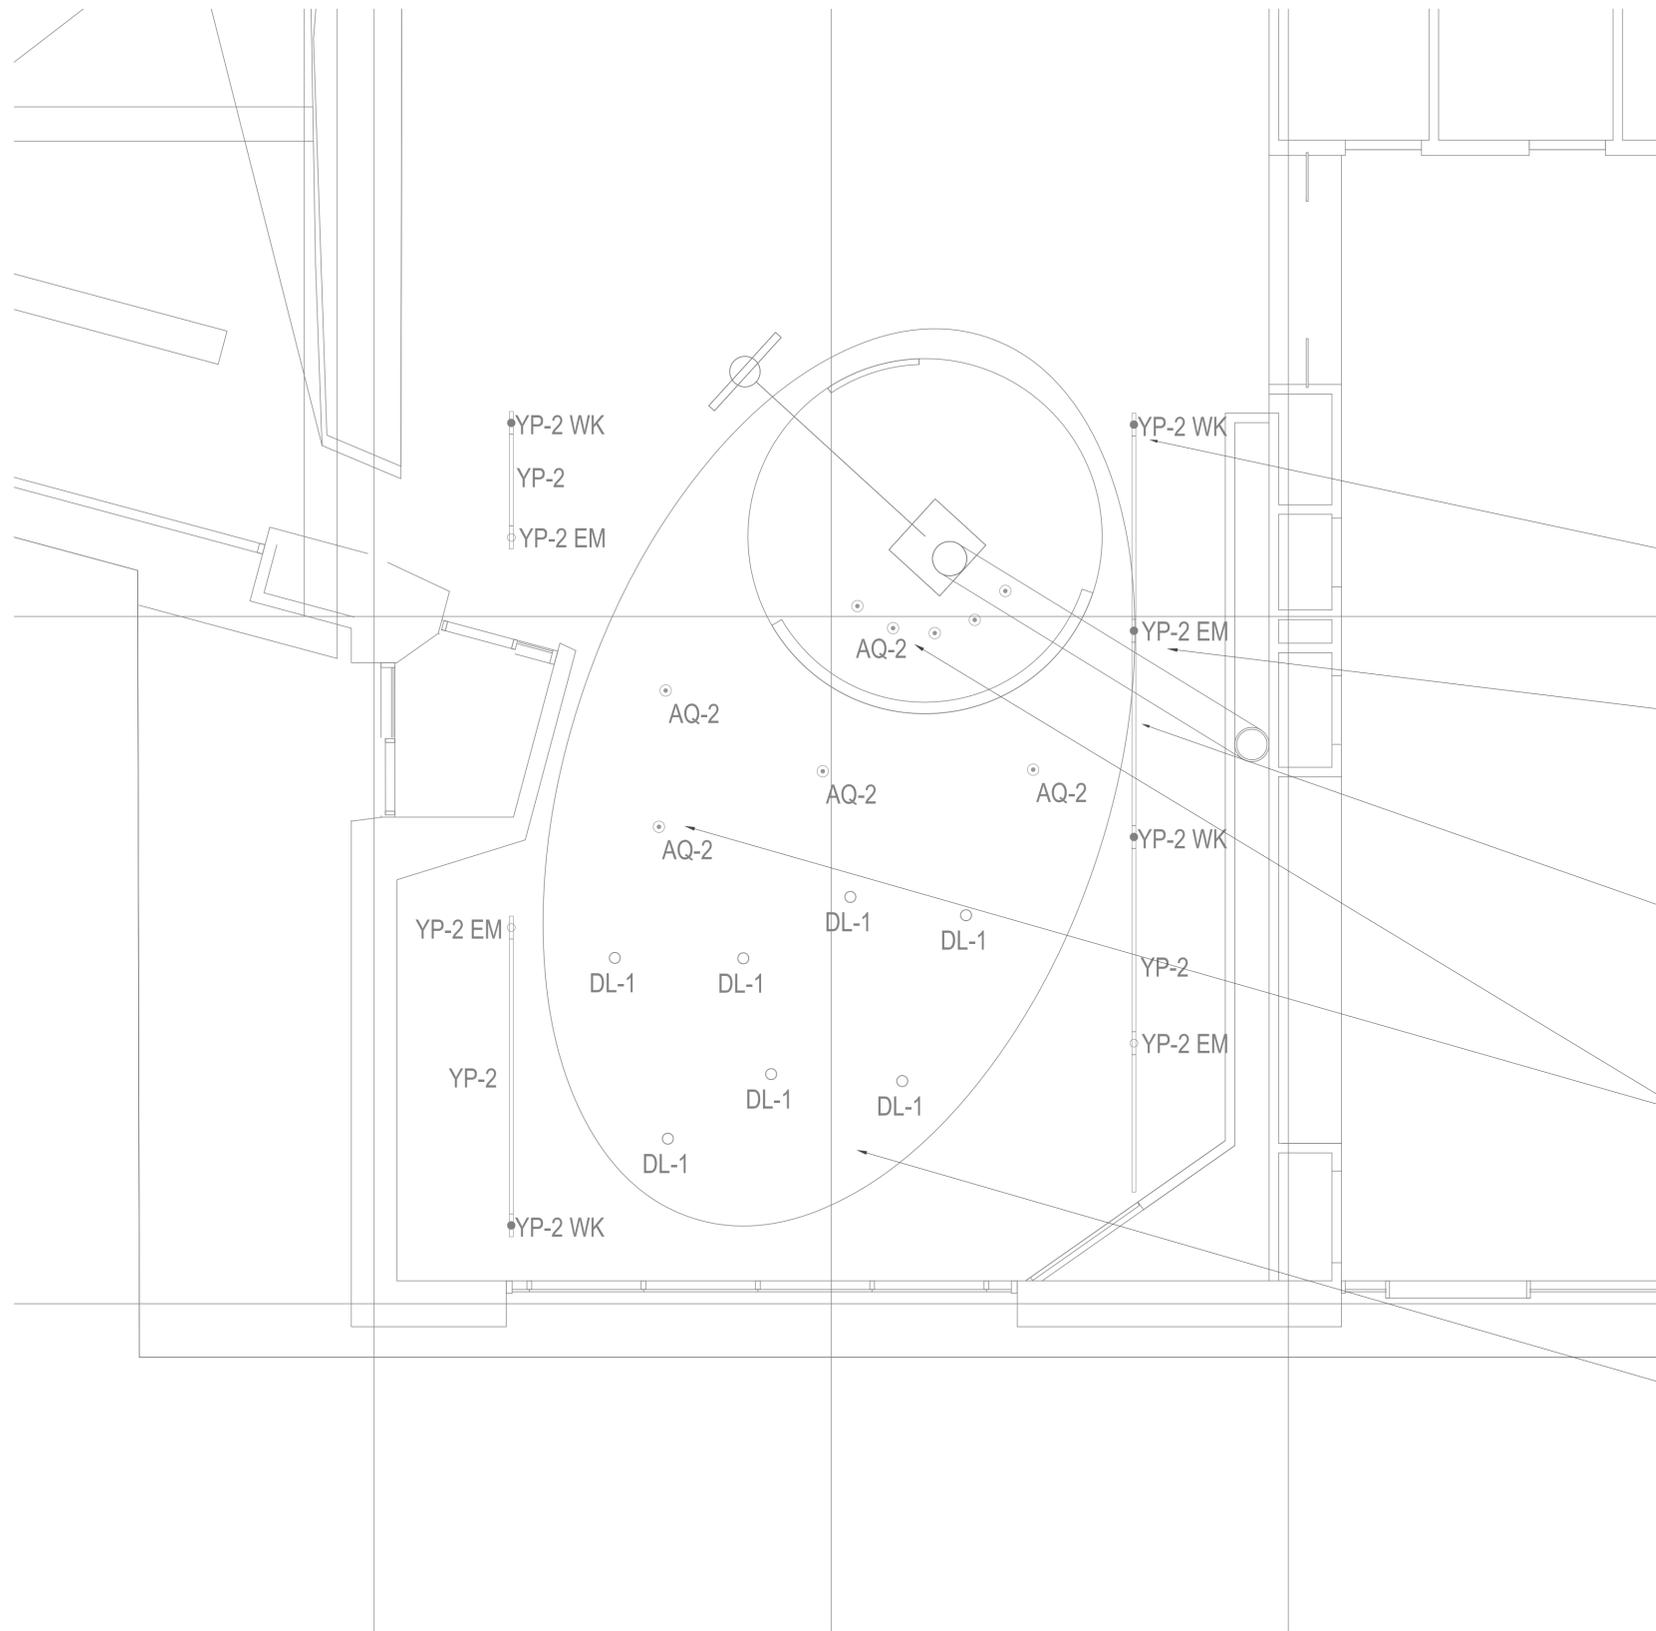

'YP2-WK' (YP-204)
 15 INCH SEGMENT TRACK WITH 150W MH FIXTURE FOR WORK LIGHT. TRACK TO BE AT THE END OR IN LINE WITH YP-2 TRACK AND MOUNTED ON UNI-STRUT
 PURCHASED AND INSTALLED BY GC

'YP2-EM' (YP-203)
 15 INCH SEGMENTED TRACK WITH 100W HALOGEN FIXTURE FOR EMERGENCY LIGHTING. TRACK TO BE AT THE END OR IN LINE WITH YP-2 TRACK AND MOUNTED ON UNI-STRUT
 PURCHASED AND INSTALLED BY GC

'YP-2' (YP-201)
 SINGLE CIRCUIT TRACKS MOUNTED ON CONTINUOUS UNI-STRUT
 PURCHASED AND INSTALLED BY GC

'AQ-1' (AQ-201)
 RECESSED ADJUSTABLE ACCENT LIGHT
 PURCHASED AND INSTALLED BY GC


'DL-1' (DL-201)
 RECESSED LOW VOLTAGE DOWNLIGHT
 PURCHASED AND INSTALLED BY GC

UTAH MUSEUM OF NATURAL HISTORY

UNIVERSITY OF UTAH, SALT LAKE CITY, UTAH

Owner UMNH 1300 East President's Circle Salt Lake City, Utah 84112 801.581.6927 tel.	Design Architect Polshak Partnership Architects LLP 320 West 13th Street New York, New York 212.807.7171 tel.	Architect of Record Gensler 375 West 200 South Salt Lake City, Utah 801.521.8600 tel.	Structural Engineer Leslie E. Robertson Associates 30 Broad Street New York, New York 10004 212.750.9000 tel.	Mechanical/Plumbing/Fire Protection Cognate Engineering Associates, Inc. 244 West 300 North Salt Lake City, Utah 84103 801.322.2400 tel.	Electrical/AV Engineer Spectrum Engineers 175 South Main Street Salt Lake City, Utah 84111 800.678.7077 tel.	Landscape Architect Design Workshop, Inc. 1796 Prospector Avenue Park City, Utah 84060 435.655.0915 tel.	Exhibition Planner and Brandenburg Associates 88 Pine Street New York, New York 10005 212.334.8200 tel.	Lighting Designer Brandston Partnership Inc 122 West 26th Street New York, New York 10001 212.924.4050 tel.
--	---	---	---	--	--	--	---	---

Exhibit Construction

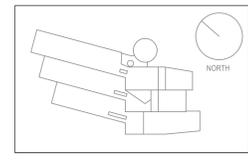

Key Plan

80% FD	Dec. 19, 2008
100% DD	June 2, 2008
XG 60% CD	May 5, 2008
WS9	March 26, 2008
WS8	Feb. 20, 2008
WS7	Dec. 18, 2007
50% DD	Sept. 18, 2007
WS6	July 11, 2007
WS5	May 23, 2007
WS4	April 12, 2007


No. / Issue Name / Date

_____	_____
_____	_____
_____	_____
_____	_____
_____	_____
_____	_____
_____	_____
_____	_____

No. / Issue Name / Date

Sheet Title Level 5 Partial RCP: Sky Observatory	
Date Dec. 19, 2008	Project No. 0275
Scale* 1/4"=1'-0"	Sheet No. LX5-SK-1.02

*Note: Scale Given for Full Size Drawing Sheet (22" x 34")

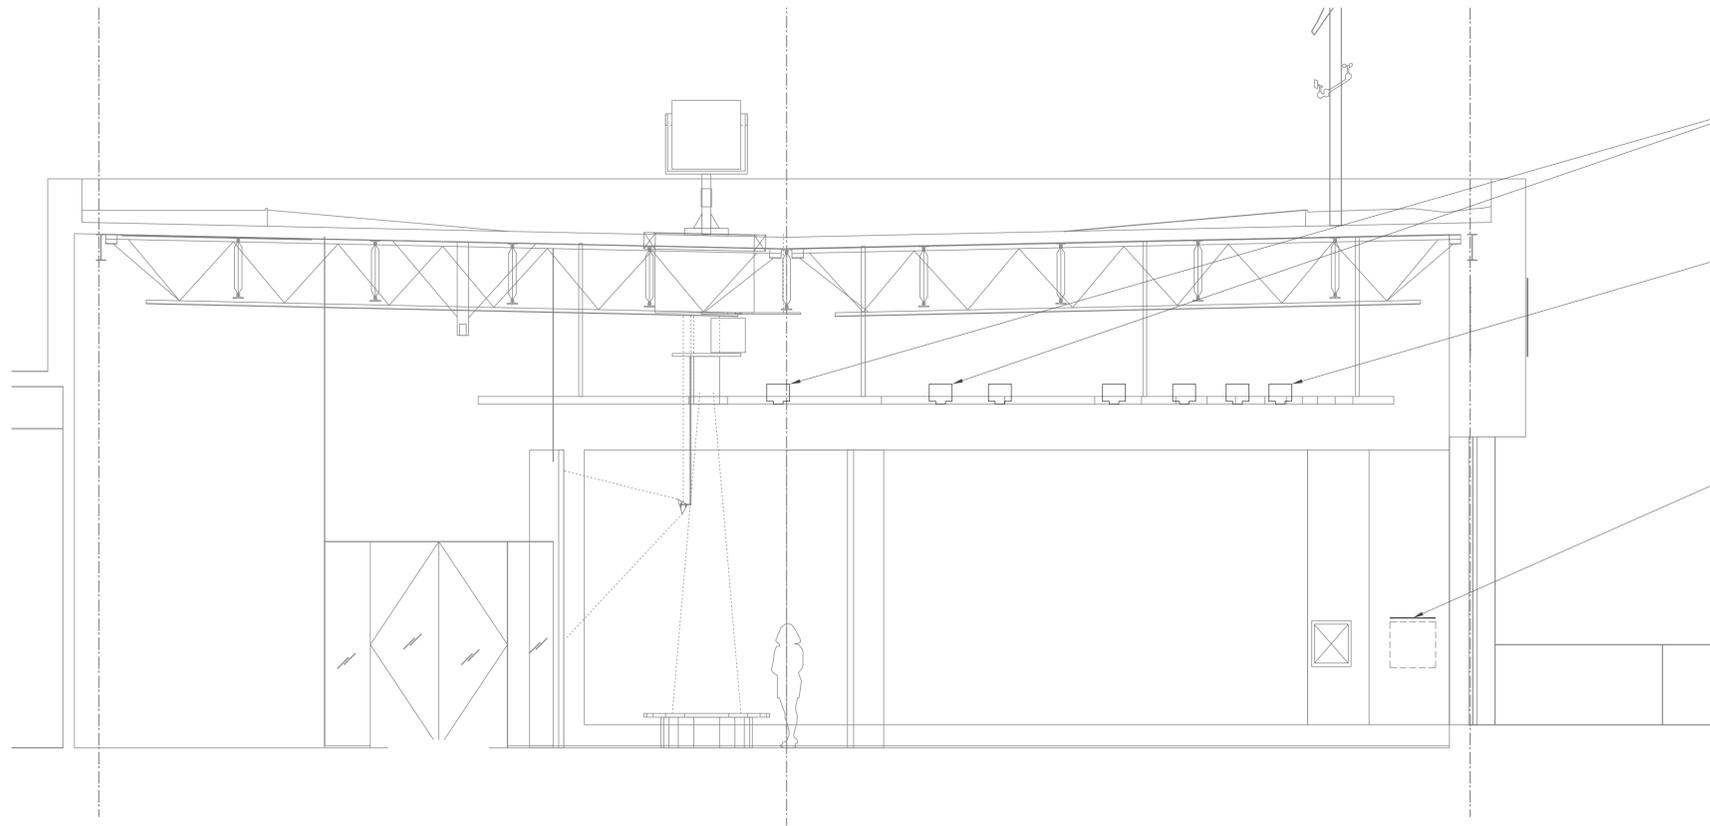

'AQ-1' (AQ-201)
RECESSED ADJUSTABLE ACCENT LIGHT
PURCHASED AND INSTALLED BY GC

'DL-1' (DL-201)
RECESSED LOW VOLTAGE DOWNLIGHT
PURCHASED AND INSTALLED BY GC



'C-LE-1'
LINEAR LED FIXTURE MOUNTED IN INSET CASE WITH REMOTE POWER SUPPLY REQUIRED.
PURCHASED AND INSTALLED BY XC

'YP-2' (YP-201)
SINGLE CIRCUIT TRACKS MOUNTED ON CONTINUOUS UNI-STRUT
'YP2-EM' (YP-203) & YP2-WK(YP-204)
EMERGENCY LIGHT & WORK LIGHTS ARE AT THE END OR IN LINE WITH YP-2 TRACK, MOUNTED ON CONTINUOUS UNI-STRUT
PURCHASED AND INSTALLED BY GC

'C-LE-1'
LINEAR LED FIXTURE MOUNTED IN INSET CASE WITH REMOTE POWER SUPPLY REQUIRED.
PURCHASED AND INSTALLED BY XC

'YP-2' (YP-201)
SINGLE CIRCUIT TRACKS MOUNTED ON CONTINUOUS UNI-STRUT
'YP2-EM' (YP-203) & YP2-WK(YP-204)
EMERGENCY LIGHT & WORK LIGHTS ARE AT THE END OR IN LINE WITH YP-2 TRACK, MOUNTED ON CONTINUOUS UNI-STRUT
PURCHASED AND INSTALLED BY GC

'DL-1' (DL-201)
RECESSED LOW VOLTAGE DOWNLIGHT
PURCHASED AND INSTALLED BY GC

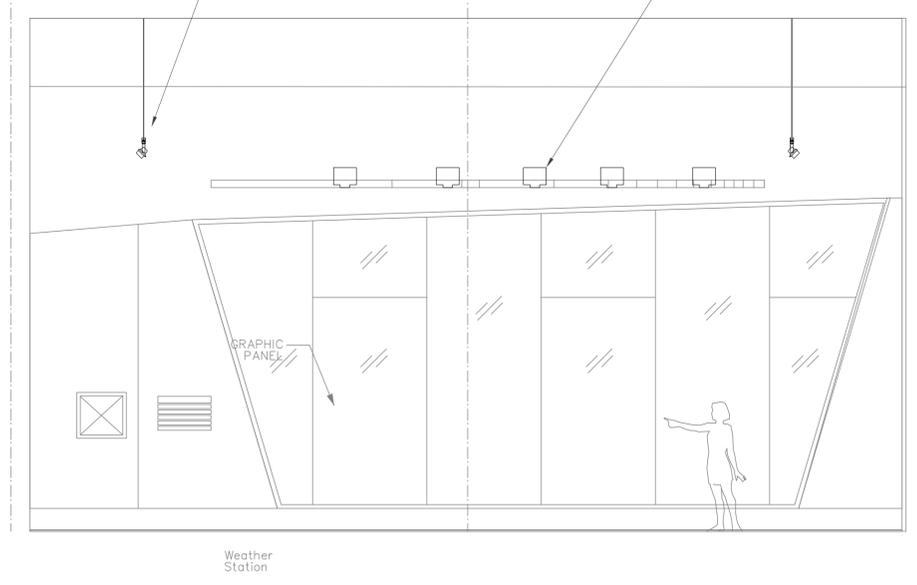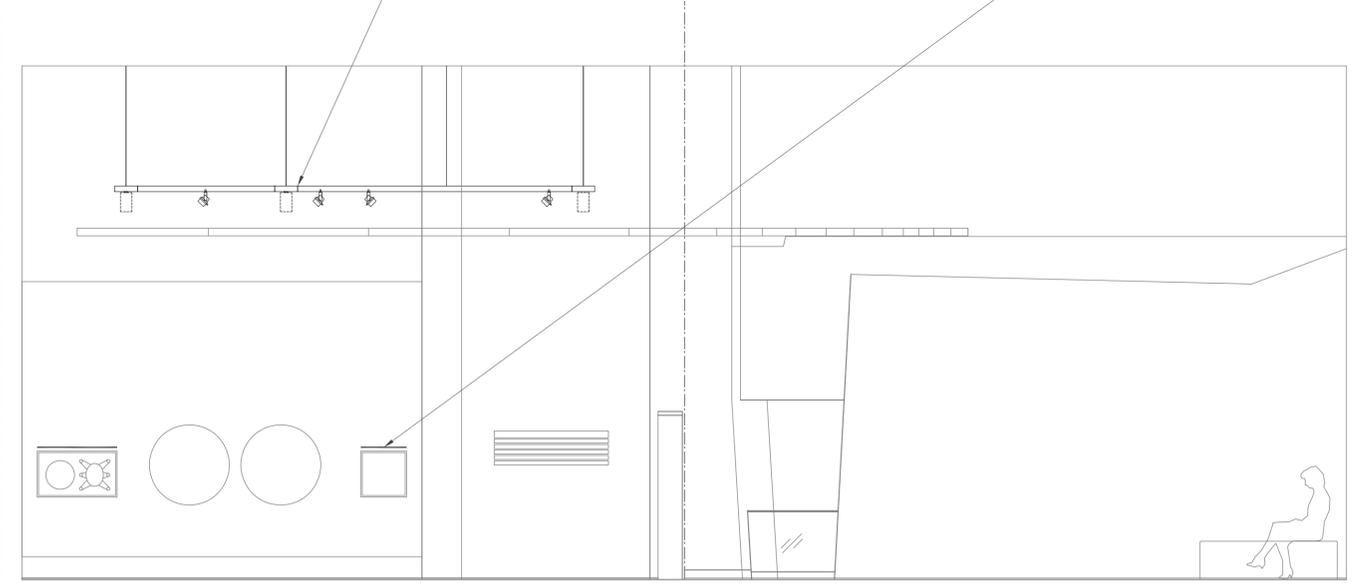


UTAH MUSEUM OF NATURAL HISTORY

UNIVERSITY OF UTAH, SALT LAKE CITY, UTAH

Exhibit Construction

Owner UMNH 1300 East President's Circle Salt Lake City, Utah 84112 801.581.6927 tel.	Design Architect Polshak Partnership Architects LLP 320 West 13th Street New York, New York 212.807.7171 tel.	Architect of Record Sternberg Architects 375 West 200 South Salt Lake City, Utah 801.521.8600 tel.	Structural Engineer Leslie E. Robertson Associates 30 Broad Street New York, New York 10004 212.750.9000 tel.	Mechanical/Plumbing/Fire Protection Engineering Associates, Inc. 244 West 300 North Salt Lake City, Utah 84103 801.322.2400 tel.	Electrical/AV Engineer Spectrum Engineers 175 South Main Street Salt Lake City, Utah 84111 800.678.7077 tel.	Landscape Architect Design Workshop, Inc. 1796 Prospector Avenue Park City, Utah 84060 435.655.0915 tel.	Exhibition Planner and Brandenburg Associates 88 Pine Street New York, New York 10005 212.334.8200 tel.	Lighting Designer Brandston Partnership Inc 122 West 26th Street New York, New York 10001 212.924.4050 tel.
---	--	---	--	---	---	---	--	--

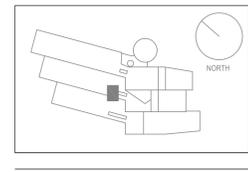

Key Plan

80% FD	Dec. 19, 2008
100% DD	June 2, 2008
XG 60% CD	May 5, 2008
WS9	March 26, 2008
WS8	Feb. 20, 2008
WS7	Dec. 18, 2007
50% DD	Sept. 18, 2007
WS6	July 11, 2007
WS5	May 23, 2007
WS4	April 12, 2007

No. / Issue Name / Date

No. / Issue Name / Date

Sheet Title	
Sections & Elevations Sky Observatory	
Date	Project No.
Dec. 19, 2008	0275
Scale*	Sheet No.
1/4"=1'-0"	X5-SK-2.00

*Note: Scale Given for Full Size Drawing Sheet (22" x 34")