

1

2

3

4

5

6

E

D

C

B

A

E

D

C

B

A

GENERAL NOTES

1. CONTRACTOR TO RESTORE ASPHALT AND CONCRETE DAMAGED DURING PROJECT TO ORIGINAL CONDITION.

SHEET KEYNOTES

- ① EXISTING PAD MOUNTED TRANSFORMER "TP". FIELD VERIFY EXACT LOCATION.
- ② NEW BRANCH PANEL "P". COORDINATE LOCATION IN FIELD WITH OWNER. SEE ONE-LINE DIAGRAM.
- ③ 2 #4 AND #8 GND RUN IN 1" CONDUIT.
- ④ 2 #3 AND #8 GND RUN IN 1" CONDUIT.

BNA CONSULTING
SALT LAKE ST. GEORGE

435 South State Street
Salt Lake City, Utah 84111
P: 801-532-2196
F: 801-532-2905
www.bnaconsulting.com

© 2007 BNA CONSULTING

Professional Stamp:

LICENSED PROFESSIONAL ENGINEER
No. 4816
GARY W. MESKER
STATE OF UTAH

CONSULTANTS:

LIBRARY SEAL OF THE STATE OF UTAH
1896

State of Utah - Department of Administration Services
DIVISION OF FACILITIES CONSTRUCTION AND MANAGEMENT
410 STATE OFFICE BUILDING / 2ND FLOOR / SALT LAKE CITY, UTAH 84103

Project Title:
**Utah National Guard
West Jordan
Site Lighting Upgrade**

Building Name:
West Jordan UT Facility


1	x	x

MARK	DATE	DESCRIPTION
ISSUE TYPE: CONSTRUCTION DOCUMENTS		
DATE: 08/03/2010		
DCFM PROJECT NO: 09130480		
STATE PROPERTY ID NO:		
CAD DWG FILE:		
DRAWN BY: BNA CHK'D BY: FGK		
SCALE: GRAPHIC		

Sheet Title:
ELECTRICAL SITE PLAN

Sheet Number:
ES100

SHEET: OF:

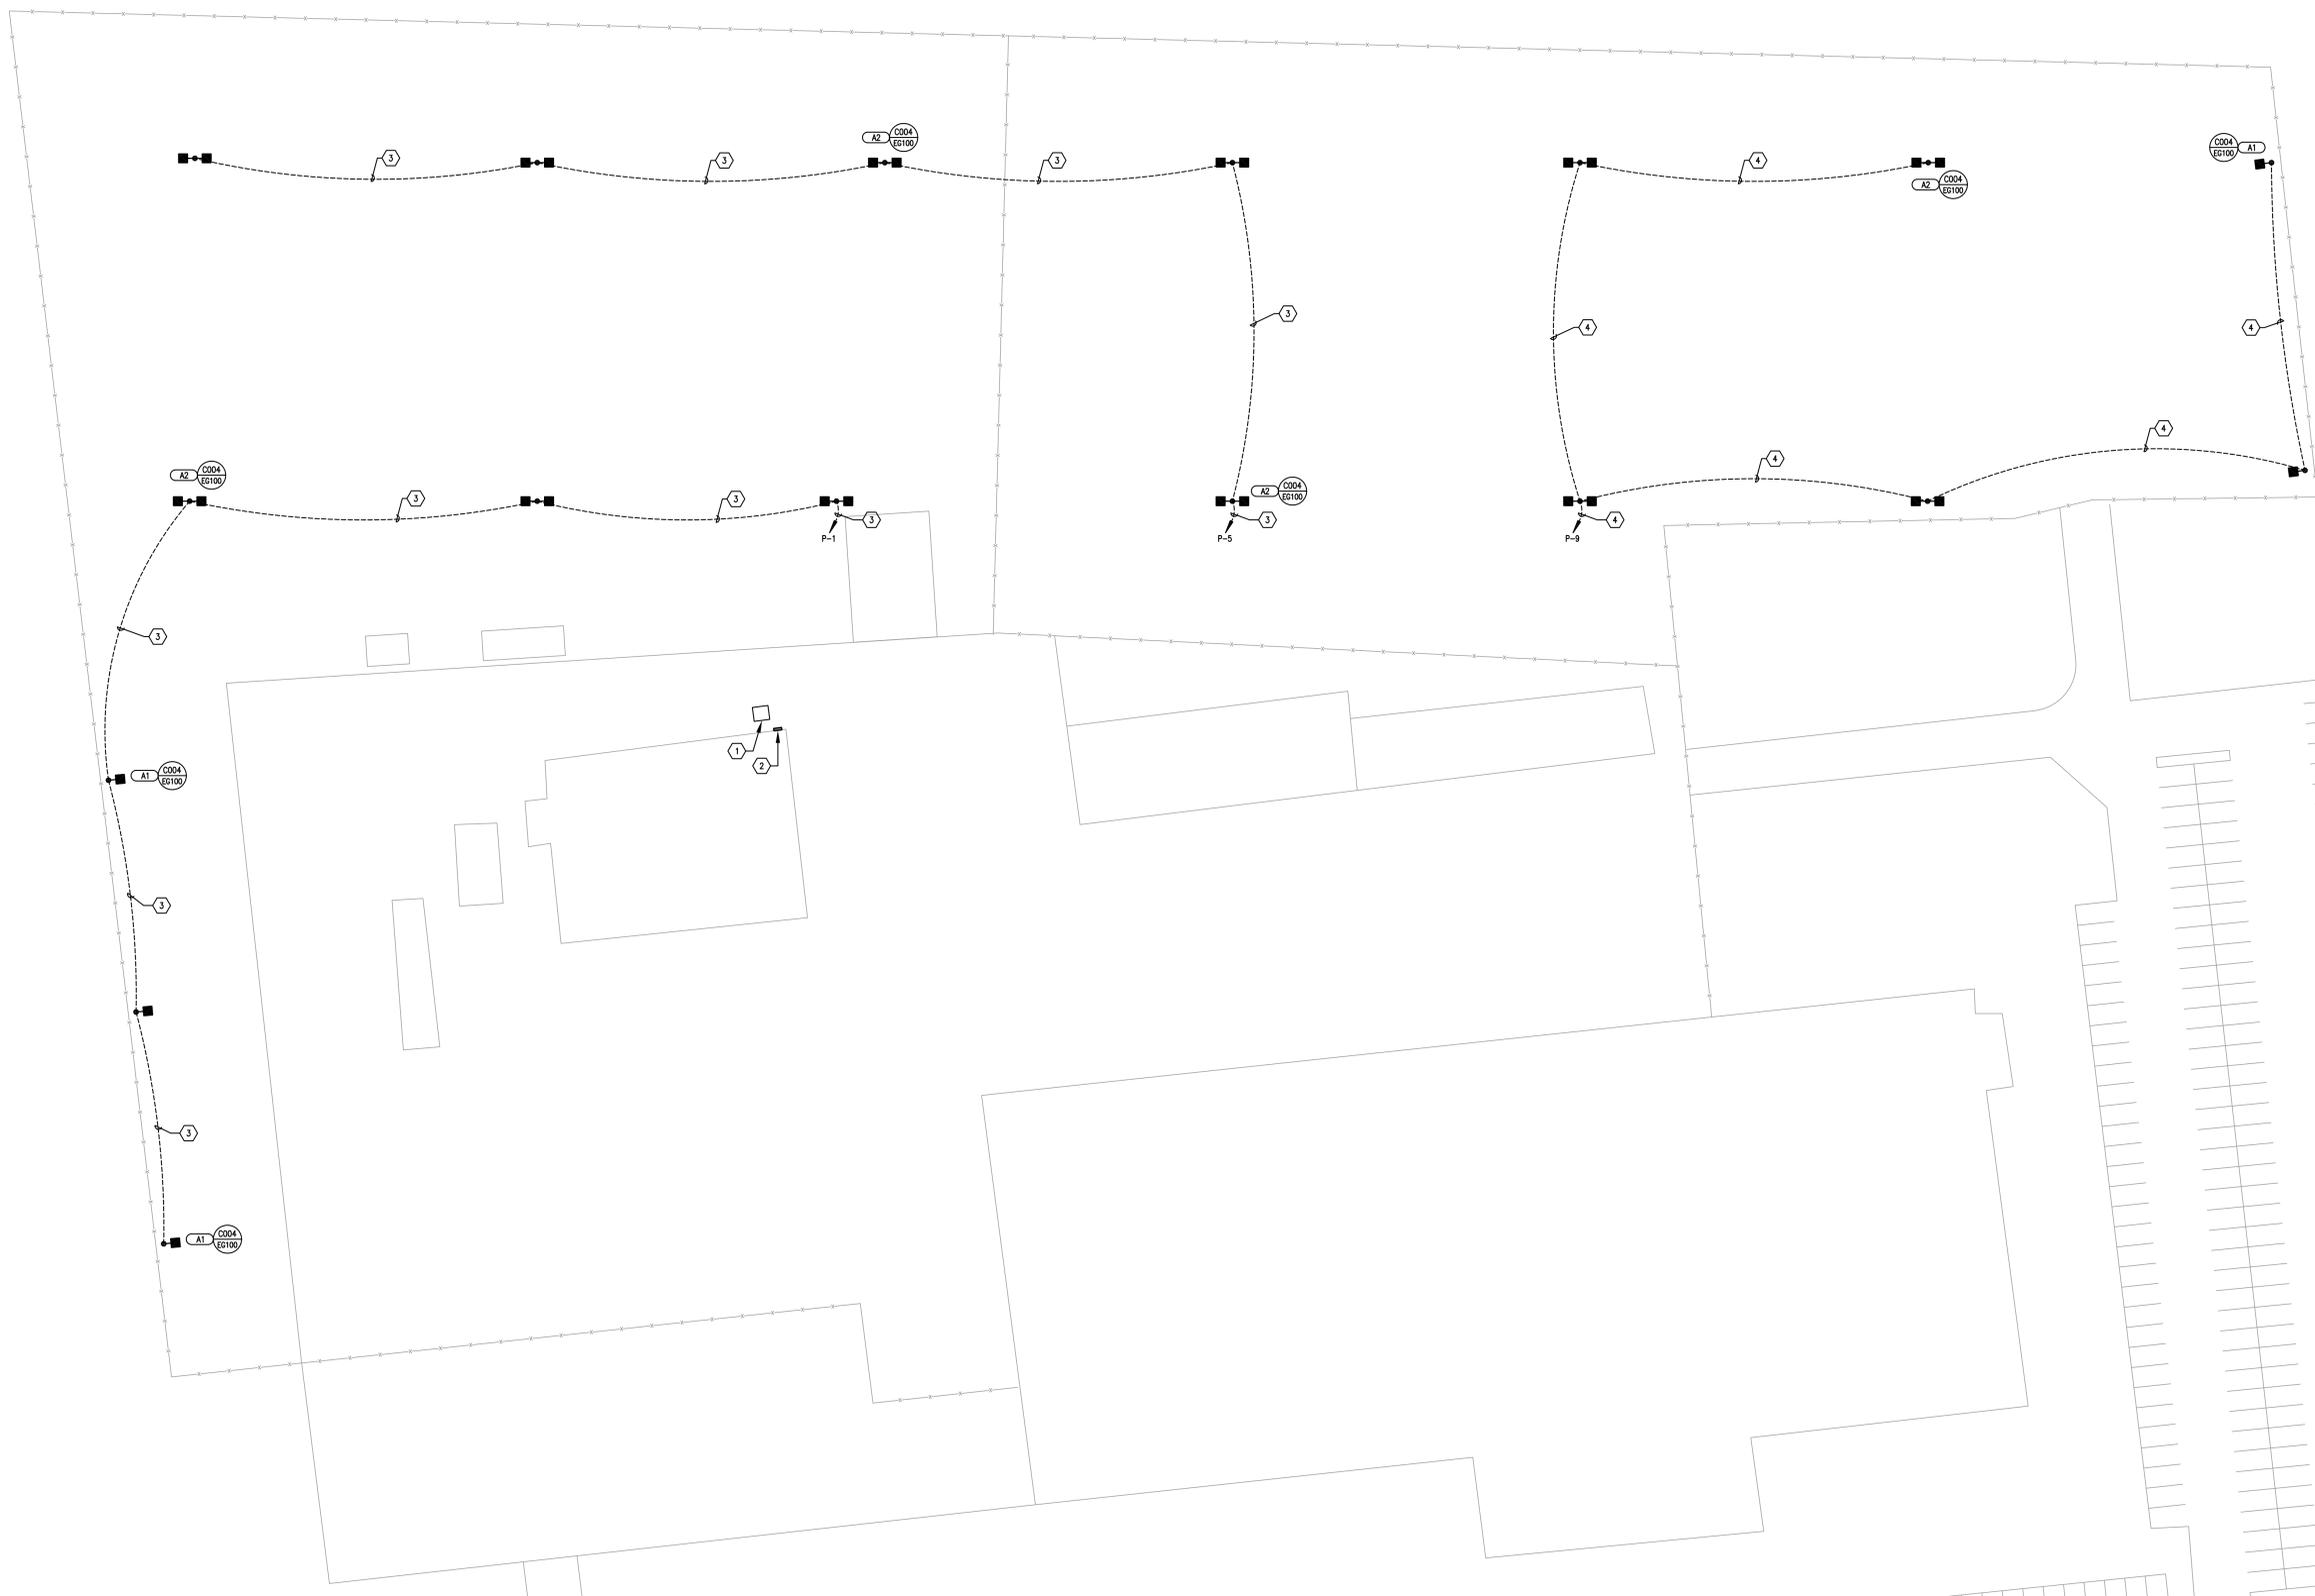

PLAN NORTH

ELECTRICAL SITE PLAN

1"=30'-0"

By: Frank Aug 03, 2010 - 10:44am
C:\2010\100480\100480.dwg