

1 2 3 4 5 6

SHEET KEYNOTES
 ① NO WORK REQUIRED IN THIS AREA, UNLESS NOTED.

GENERAL SHEET NOTES
 1. ALL LIGHT FIXTURES SHOWN ARE IN-PLACE REPLACEMENTS OF EXISTING LIGHT FIXTURES UNLESS NOTED OTHERWISE. CONTRACTOR TO PROVIDE ADDITIONAL SUPPORT AS REQUIRED TO MEET THE REQUIREMENTS OF THE SPECIFICATIONS.




Professional Stamp
 CONSULTANTS



State of Utah - Department of Administrative Services
DIVISION OF FACILITIES CONSTRUCTION AND MANAGEMENT
 400 STATE OFFICE BUILDING / 200 WEST 600 SOUTH, SUITE 2000 / SALT LAKE CITY, UT 84102

Project Title:
Department of Agriculture
Agriculture Administration Building
Lighting Upgrade

Building Name:
Agriculture Administration Building
Salt Lake City, UT 84116

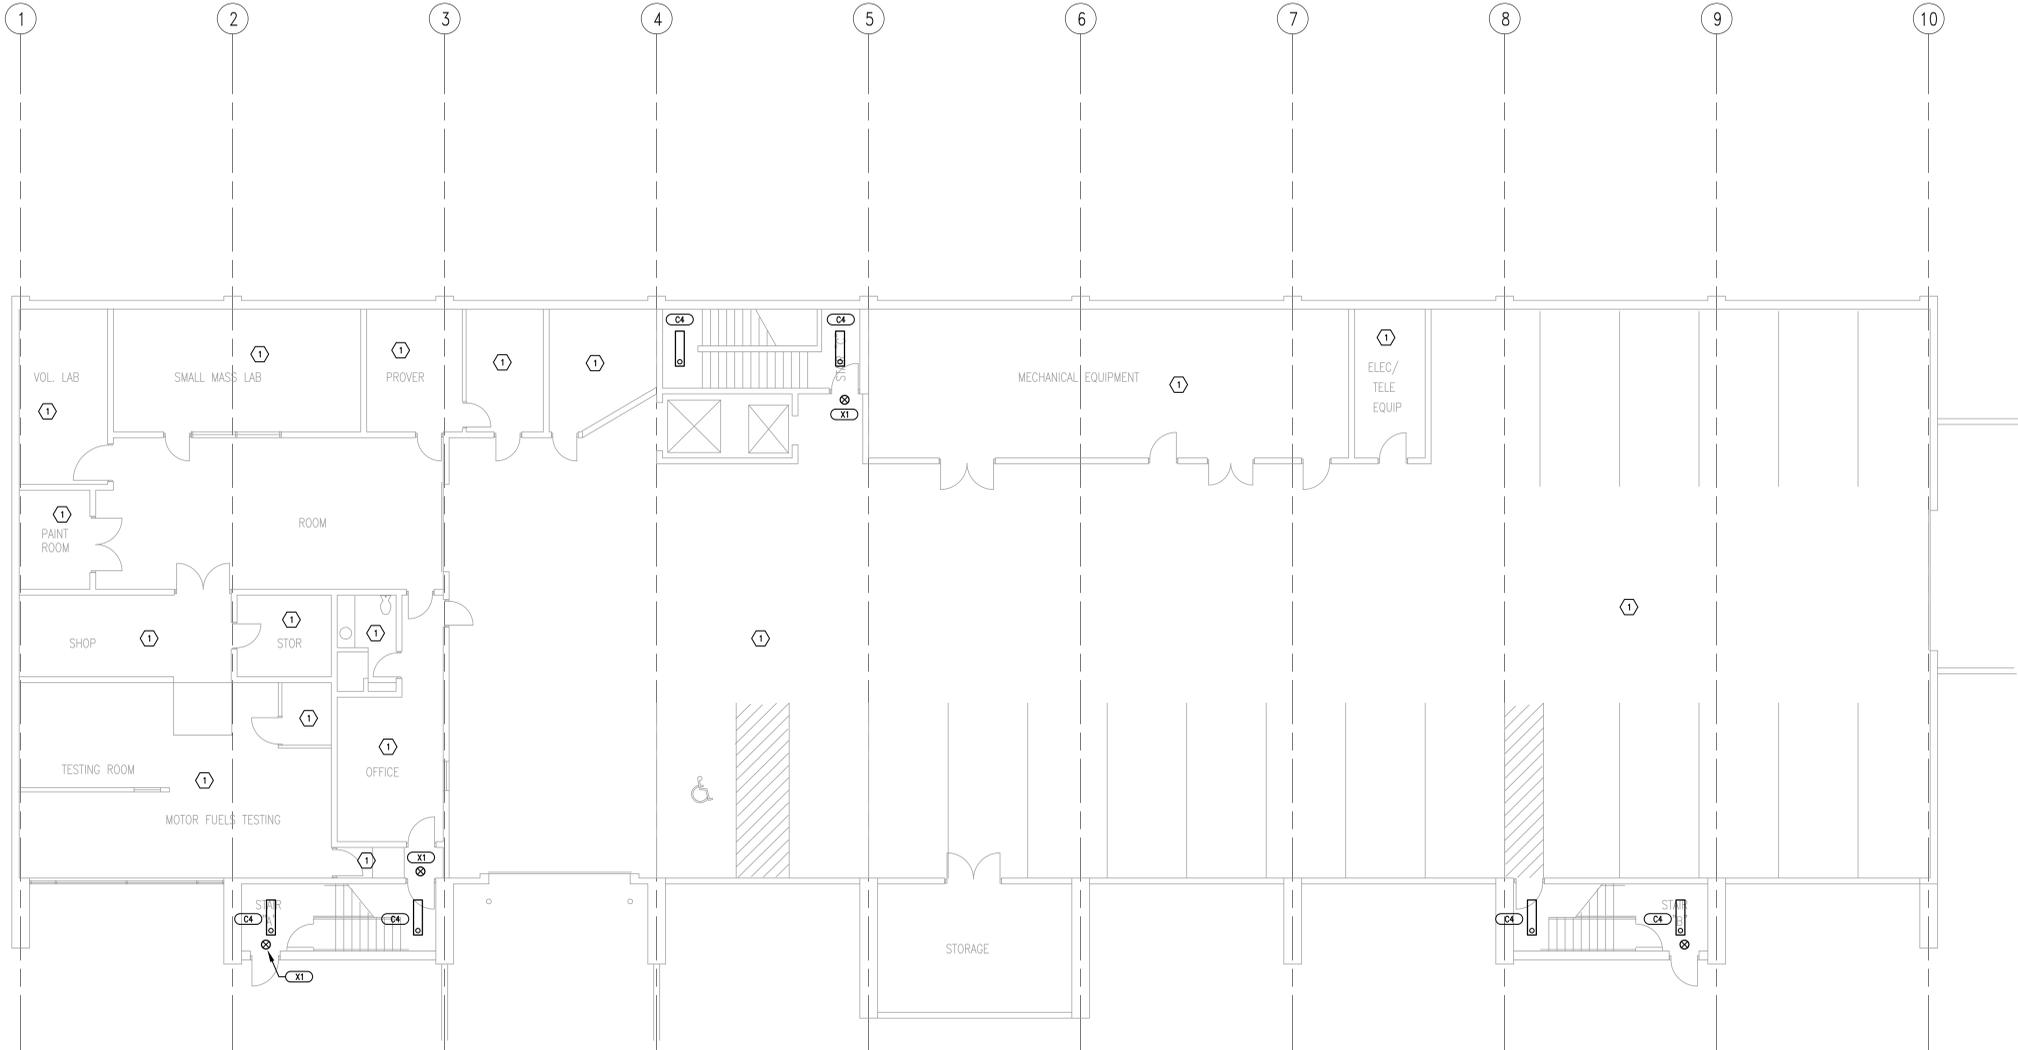

PLAN NORTH
BASEMENT LIGHTING PLAN
 1/8" = 1'-0" 0 4' 8' 16'

1	x	x

MARK	DATE	DESCRIPTION

ISSUE TYPE: CONSTRUCTION DOCUMENTS
 DATE: 06/22/2010
 DFCM PROJECT NO: 10119010
 STATE PROPERTY ID NO:
 CAD DWG FILE:
 DRAWN BY: BNA CHK'D BY: FGK
 SCALE: GRAPHIC

Sheet Title:
 BASEMENT ELECTRICAL PLAN

Sheet Number:
EE001

SHEET: OF:

1 2 3 4 5 6

B:\proj\118A\DWG\118A-EE001.dwg
 2010.06.22 10:58 AM
 118A-EE001.dwg

1 2 3 4 5 6

E
D
C
B
A

GENERAL SHEET NOTES
 1. ALL LIGHT FIXTURES SHOWN ARE IN-PLACE REPLACEMENTS OF EXISTING LIGHT FIXTURES UNLESS NOTED OTHERWISE. CONTRACTOR TO PROVIDE ADDITIONAL SUPPORT AS REQUIRED TO MEET THE REQUIREMENTS OF THE SPECIFICATIONS.

SHEET KEYNOTES
 ① ALL TYPE 'X1' AND 'X2' LIGHT FIXTURES ARE TO BE PROVIDED UNDER THE BASE BID.
 ② LIGHT FIXTURE REPLACEMENTS IN THIS AREA PROVIDED UNDER ALTERNATE #2, UNLESS NOTED OTHERWISE.



PLAN NORTH
LEVEL 3 LIGHTING PLAN
 1/8" = 1'-0" 0 4' 8' 16'



Professional Stamp
 CONSULTANTS



State of Utah - Department of Agriculture
DIVISION OF FACILITIES CONSTRUCTION AND MANAGEMENT
 400 STATE OFFICE BUILDING / 500 WEST 600 SOUTH / SALT LAKE CITY, UT 84143

Project Title:
Department of Agriculture

Agriculture Administration Building

Lighting Upgrade

Building Name:
**Agriculture Administration Building
 Salt Lake City, UT 84116**

1	x	x

MARK	DATE	DESCRIPTION

Issue Type: CONSTRUCTION DOCUMENTS
 DATE: 06/22/2010
 DFCM PROJECT NO: 10119010
 STATE PROPERTY ID NO:
 CAD DWG FILE:
 DRAWN BY: BNA CHK'D BY: FGK
 SCALE: GRAPHIC

Sheet Title:
 LEVEL 3 LIGHTING PLAN

Sheet Number:
EL301

1 2 3 4 5 6

By: frank_aub_28_2010 - 2:58pm
 F:\2010\118A\Drawings\118A-EL301.dwg