

Professional Stamp

CONSULTANTS



State of Utah - Department of Administrative Services
DIVISION OF FACILITIES CONSTRUCTION AND MANAGEMENT
400 STATE OFFICE BUILDING / 500 WEST 600 SOUTH / SALT LAKE CITY / UT 84103

Project Title:

Department of Agriculture
Agriculture Administration Building

Electrical System Trace

Building Name:

Agriculture Administration Building
Salt Lake City, UT 84116

1	x	x

MARK	DATE	DESCRIPTION
		ISSUE TYPE: CONSTRUCTION DOCUMENTS
	DATE: 06/22/2010	
	DFCM PROJECT NO: 10120010	
	STATE PROPERTY ID NO:	
	CAD DWG FILE:	
	DRAWN BY: BNA	CHK'D BY: FGK
	SCALE: GRAPHIC	


Sheet Title:

BASEMENT ELECTRICAL PLAN

Sheet Number:

EE001

SHEET: OF:

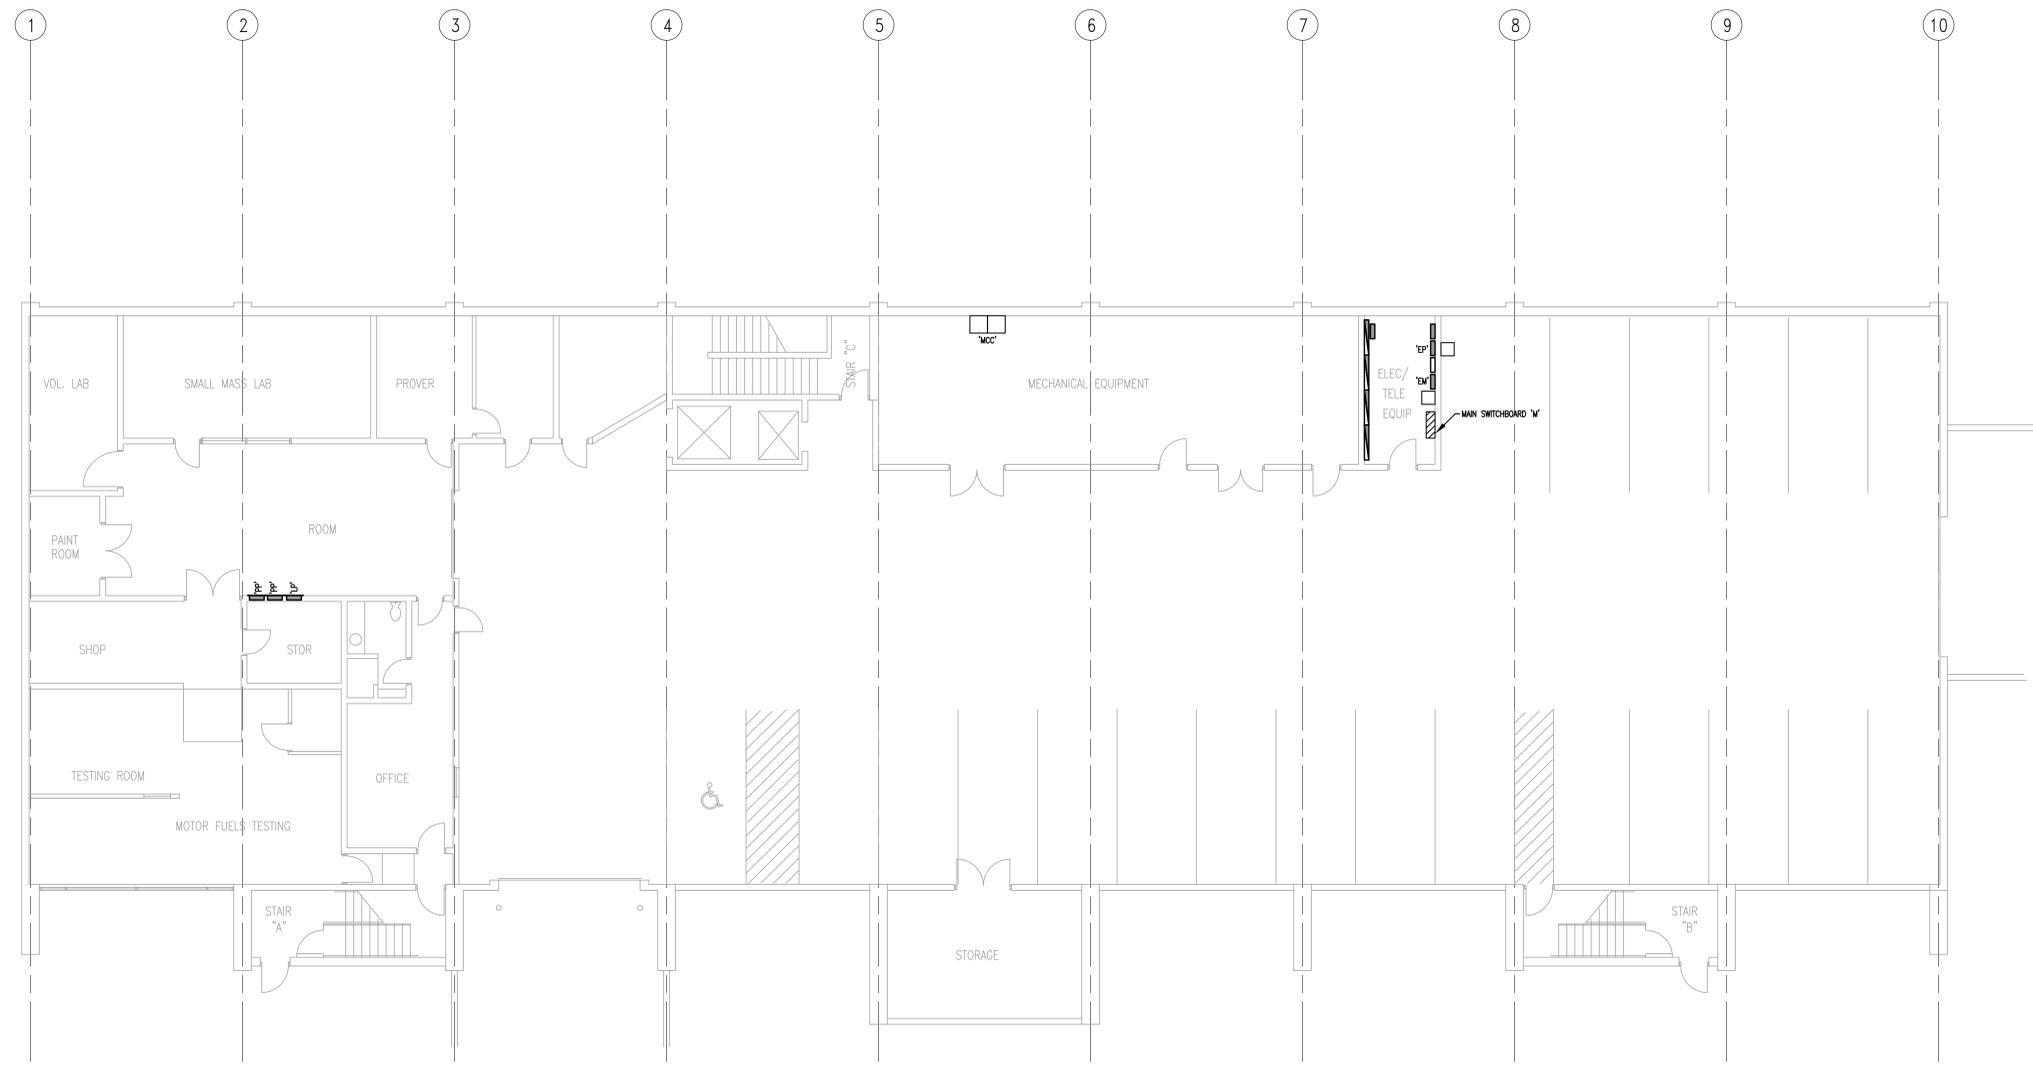

PLAN NORTH
BASEMENT ELECTRICAL PLAN
1/8" = 1'-0"
0 4' 8' 16'

Professional Stamp

CONSULTANTS



State of Utah - Department of Administration
DIVISION OF FACILITIES CONSTRUCTION AND MANAGEMENT
400 STATE OFFICE BUILDING / 500 WEST GATEWAY AVENUE / SALT LAKE CITY, UT 84103

Project Title:
Department of Agriculture
Agriculture Administration Building
Electrical System Trace

Building Name:
Agriculture Administration Building
Salt Lake City, UT 84116

1	x	x

MARK	DATE	DESCRIPTION

ISSUE TYPE: CONSTRUCTION DOCUMENTS
DATE: 06/22/2010
DFCM PROJECT NO: 10120010
STATE PROPERTY ID NO:
CAD DWG FILE:
DRAWN BY: BNA CHK'D BY: FGK
SCALE: GRAPHIC

Sheet Title:
LEVEL 1 ELECTRICAL PLAN

Sheet Number:
EE101

SHEET: OF:



PLAN NORTH
LEVEL 1 ELECTRICAL PLAN
1/8" = 1'-0"
0 4' 8' 16'

By: frank-ahm-28_2010_ - 3.01pm
F:\2010\117A\DWG\117A-EE101.dwg

